

FARMERS & MERCHANTS REISTERSTOWN


25 WESTMINSTER PIKE
REISTERSTOWN, MD 21136

PARTIAL CHANGE OF OCCUPANCY / USE, ALTERATION LEVEL 2 / MODIFICATION, ALTERATION LEVEL 1 / RENOVATION PERMIT SET: 29 SEPTEMBER 2026

ABBREVIATIONS

@	AT	GA	GAUGE	PROP	PROPERTY LINE
ACM	ALUMINUM COMPOSITE MATERIAL	GALV	GALVANIZED	PLAM	PLASTIC LAMINATE
ADJ	ADJACENT	GB	GYPSUM BOARD	PLY, PLYWD	PLYWOOD
AED	AUTOMATED EXTERNAL DEFIBRILLATOR	GWB	GYPSUM WALL BOARD	POLY	POLYETHYLENE
AFF	ABOVE FINISHED FLOOR	GENL	GENERAL	PREFAB	PREFABRICATED
AHJ	AUTHORITY HAVING JURISDICTION	HM	HOLLOW METAL	PREP	PREPARATION
AHU	AIR HANDLING UNIT	HB	HOSE BIBB	PT	PAINT
ANOD	ANODIZED	HC	HANDICAPPED	PUR	POLYURETHANE
ALUM	ALUMINUM	HCWD	HOLLOW-CORE WOOD	PVC	POLYVINYL CHLORIDE
APC	ACOUSTICAL PANEL CEILING	HDPE	HIGH-DENSITY POLYETHYLENE	QT	QUARRY TILE
		HO	HOLD OPEN		
BD	BOARD	HORIZ	HORIZONTAL	R	RISER
BGE	BALTIMORE GAS & ELECTRIC	HP	HIGH POINT	RA	RETURN AIR
BLDG	BUILDING	HR	HANDRAIL, HOUR	RAD	RADIUS
BIT	BITUMINOUS	HSS	HOLLOW STRUCTURAL SECTION	RCP	REFLECTED CEILING PLAN
BLK	BLOCK	HT	HEIGHT	RD	ROOF DRAIN
BM	BEAM			REF	REFERENCE
BO, BOT	BOTTOM OF	ID	INSIDE DIAMETER	REFRIG	REFRIGERATOR
BOD	BASIS OF DESIGN	INSUL	INSULATION	REINF	REINFORCING
BR	BRICK	INT, INTR	INTERIOR	REQD	REQUIRED
BUR	BUILT-UP ROOF	ISO	POLYISOCYANURATE	REQT(S)	REQUIREMENT(S)
		JO	JAMB OPENING	RL	RAIN LEADER
C	COURSES	JT	JOINT	RM	ROOM
CAB	CABINET			RO	ROUGH OPENING
CB	CHALKBOARD	KD	KNOCK DOWN	RTU	ROOF TOP UNIT
CL	CENTERLINE, COLUMN LINE			Rx, RX	REMOVE
CLG	CEILING	LF	LINEAR FEET	SA	SUPPLY AIR
CJ	CONTROL JOINT	LAM	LAMINATE	SAN	SANITARY
CMU	CONCRETE MASONRY UNIT	LAV	LAVATORY	SCHED	SCHEDULE
COL	COLUMN	LED	LIGHT-EMITTING DIODE	SCWD	SOLID-CORE WOOD
CONC	CONCRETE	LEED	LEADERSHIP IN ENERGY AND ENVIRONMENTAL DESIGN	SECT	SECTION
CONST	CONSTRUCTION	LLH	LONG LEG HORIZONTAL	SHGC	SOLAR HEAT-GAIN COEFFICIENT
CONT	CONTINUOUS	LLV	LONG LEG VERTICAL	SHT	SHEET
CPT	CARPET	LOD	LEASE OUTLINE DRAWING	SIM	SIMILAR
CT	CERAMIC TILE		LEVEL OF DISCHARGE	SP	STANDPIPE
			LIMIT OF DISTURBANCE	SPECS	SPECIFICATIONS
DIA, Ø	DIAMETER	LP	LOW POINT	SQ	SQUARE
DISP	DISPENSER	LVL	LEVEL	S/S	STAINLESS STEEL
DIM	DIMENSION	LVL	LAMINATED VENEER LUMBER	STC	SOUND TRANSMISSION CLASS
DN	DOWN			STL	STEEL
DS	DOWNSPOUT			STRUCT	STRUCTURAL
DTL(S)	DETAIL(S)	MACH	MACHINE	SURR	SURROUNDED
DWG	DRAWING	MANUF, MFR	MANUFACTURER	SUSP	SUSPENDED
DW	DISHWASHER	MAS	MASONRY	SW	STORM WATER
		MATL	MATERIAL	SWM	STORM WATER MANAGEMENT
		MAX	MAXIMUM		
EF	EXHAUST FAN	MB	MARKERBOARD	T	TREAD
EJFS	EXTERIOR INSULATION FINISH SYSTEM	MDF	MEDIUM DENSITY FIBERBOARD	T&G	TONGUE & GROVE
EJ	EXPANSION JOINT	MECH	MECHANICAL	TB	TACKBOARD
ELEC	ELECTRICAL	MIN	MINIMUM	TBD	TO BE DETERMINED
ELEV	ELEVATOR	MISC	MISCELLANEOUS	TD	TRENCH DRAIN
EL	ELEVATION	MO	MASONRY OPENING	TEL	TELEPHONE
EO	EDGE OF	MTG	MOUNTING	TH	THRESHOLD
EPDM	ETHYLENE PROPYLENE DIENE MONOMER	MTL	METAL	TO	TOP OF
EPS	EXPANDED POLYSTYRENE	MULL	MULLION	TPO	THERMOPLASTIC POLYOLEFIN
EQ	EQUAL			TRTD	PRESSURE TREATED
EQUIP	EQUIPMENT	NIC	NOT IN CONTRACT	TYP	TYPICAL
EW	ELECTRIC WATER COOLER	NO, #	NOMINAL	UL	UNDERWRITERS LABORATORIES
EW	ELECTRIC WATER HEATER	NOM	NOMINAL	UNO	UNLESS NOTED OTHERWISE
EX, EXIST	EXISTING	NRC	NOISE REDUCTION COEFFICIENT	UON	UNLESS OTHERWISE NOTED
EXP JT, EJ	EXPANSION JOINT	NTS	NOT TO SCALE		
EXT, EXTR	EXTERIOR				
		OC, O/C	ON CENTER	VAT	VINYL ASBESTOS TILE
FAAP	FIRE ALARM ANNUNCIATOR PANEL	OCC	OCCUPANT	VB	VAPOR BARRIER
FD	FIRE DEPARTMENT CONNECTION	OD	OUTSIDE DIAMETER	VCT	VINYL COMPOSITION TILE
FE	FIRE EXTINGUISHER	OH, OP HD	OPPOSITE HAND	VERT	VERTICAL
FEC	FIRE EXTINGUISHER CABINET	OPER	OPERABLE	VIF	VERIFY IN FIELD
FHC	FIRE HOSE CABINET	OPG	OPENING		
FIN	FINISHED, FINISH	OPP	OPPOSITE	WB	WHITEBOARD
FLASH, FLG	FLASHING			WD	WOOD
FL, FLR	FLOOR	PAF	POWER-ACTUATED FASTENER	WH	WALL HYDRANT
FO	FACE OF	PART	PARTITION	W/	WITH
FOS	FACE OF STUD	PDF	PORTABLE DOCUMENT FORMAT	W/O	WITHOUT
FP	FIRE PROOFING	PTD	PAINTED	WP	WATERPROOFING
FR, FRT	FIRE RETARDANT TREATED	PTN	PARTITION	WMF	WELDED WIRE FABRIC
FRP	FIBERGLASS REINFORCED PLASTIC	PERIM	PERIMETER	WWM	WELDED WIRE MESH
FT	FOOT, FEET	PL, PL	PLATE		
FTG	FOOTING			XPS	EXTRUDED POLYSTYRENE

SYMBOLS

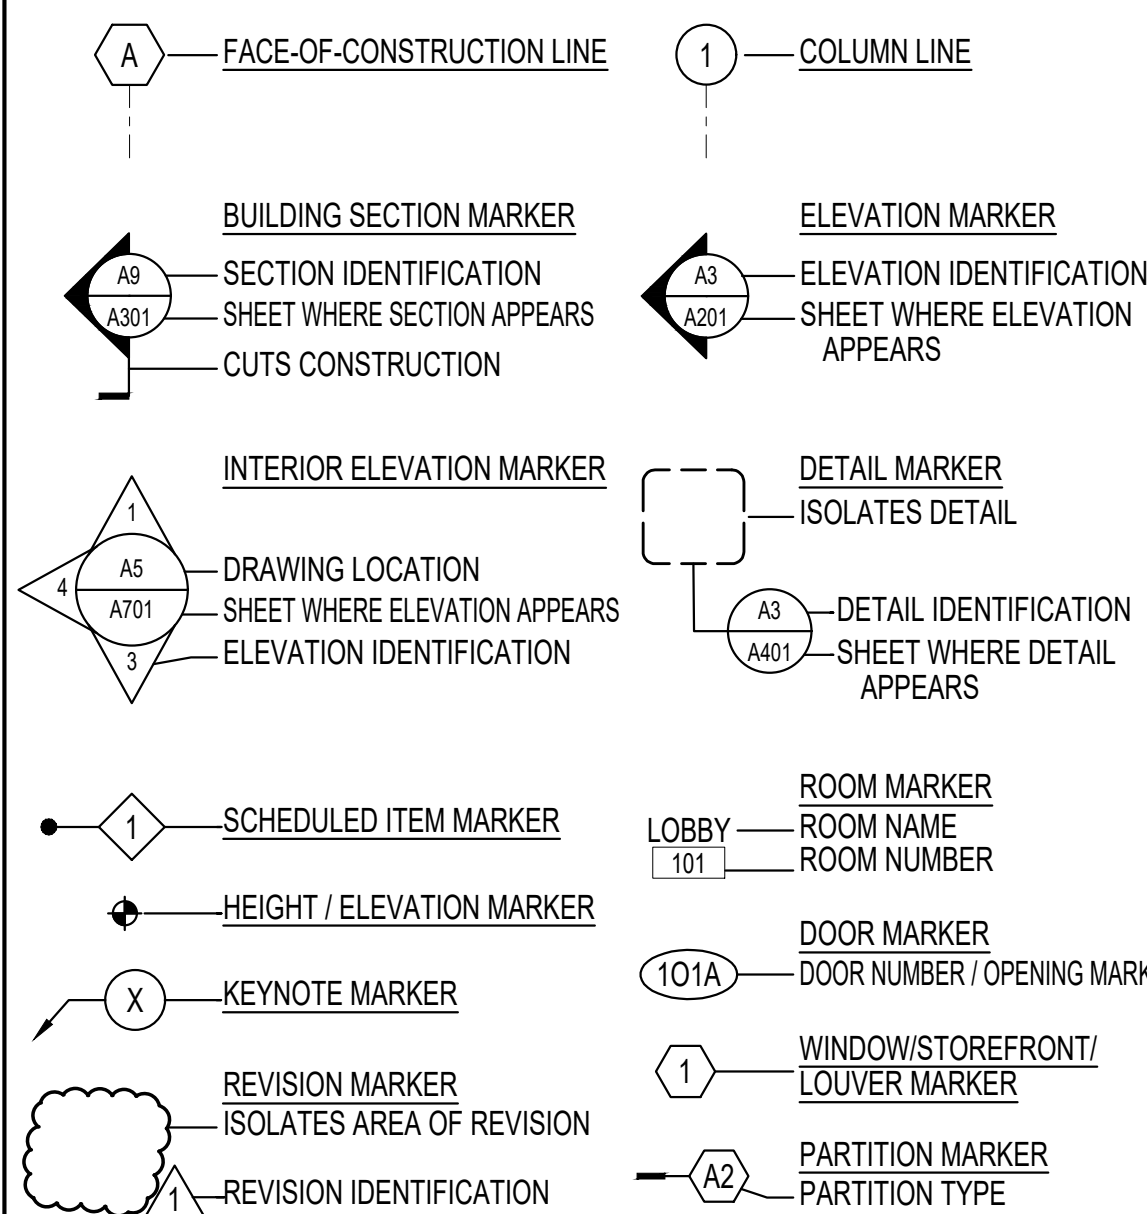

DRAWINGS SCHEDULE

GENERAL

G001 TITLE SHEET
G002 LIFE SAFETY PLAN & CODE ANALYSIS

ARCHITECTURAL

AD101 DEMOLITION FLOOR PLANS
AD111 DEMOLITION RCP's
A101 RENOVATION FLOOR PLANS
A111 RENOVATION RCP's
A131 FURN, FINISH & EQUIP. PLANS
A601 SCHEDULES AND DETAILS
A701 ENLARGED PLANS & MILLWORK DETAILS
A702 MILLWORK DETAILS
A801 ARCHITECTURAL SPECIFICATIONS

MECHANICAL

M-1 GENERAL NOTES AND LEGENDS
M-2 EXISTING AND DEMO FLOOR PLANS
M-3 EXISTING AND DEMO FLOOR PLANS
M-4 NEW WORK FLOOR AND PART PLANS
M-5 NEW WORK FLOOR AND PART PLANS
M-6 PLUMBING RISER DIAGRAMS
M-7 MECHANICAL SCHEDULES
M-8 MECHANICAL DETAILS
M-9 MECHANICAL SPECIFICATIONS

ELECTRICAL

E-1 NOTES AND SYMBOLS
E-2 DEMO BASEMENT & FIRST FLOOR - LIGHTING & POWER PLANS
E-3 DEMO SECOND FLOOR - LIGHTING & POWER PLANS
E-4 BASEMENT, FIRST, SECOND FLOOR - LIGHTING PLANS
E-5 BASEMENT & SECOND FLOOR - POWER PLANS
E-6 RISER DIAGRAM & PANEL SCHEDULES
E-7 ELECTRICAL SPECIFICATIONS & COMCHECK

PROPERTY INFORMATION

OWNER NAME: FARMERS & MERCHANTS BANK
MAILING ADDRESS: 15226 HANOVER PIKE
UPPERCO, MD 21155
PROPERTY ADDRESS: 25 WESTMINSTER PIKE
REISTERSTOWN, MD 21136
AUTHORITY HAVING JURISDICTION: BALTIMORE COUNTY
ACCOUNT NUMBER: 2200025789
ELECTION DISTRICT: 04TH
TAX MAP: 0048
GRID: 0010
PARCEL: 0112
LOT: 2
PLAT: 0069 / 0061
ZONING: BM-BL
LOT SIZE: 1.13 ACRES
USE: 06

VICINITY MAP



DESIGN TEAM

Architect: SANDERS DESIGNS, P.A.
9727 GREENSIDE DRIVE, SUITE 202
COCKEYSVILLE, MARYLAND 21030-5080
T: 410-560-2624 F: 410-560-2722
MEP Engineer: JLR DESIGN CONSULTANTS, INC.
1901 NORTH FOUNTAIN GREEN ROAD
BEL AIR, MARYLAND 21015-1411
T: 410-893-2822 F: 410-803-0442


APPLICABLE CODES

- MARYLAND ACCESSIBILITY CODE COMAR 09.12.53 (ADAAG 2010)*
 - NATIONAL ELECTRICAL CODE 2024*
 - INTERNATIONAL BUILDING CODE 2021*
 - MARYLAND BUILDING REHABILITATION CODE COMAR 09.12.58 (IEBC 2015)*
 - NATIONAL FIRE PROTECTION ASSOCIATION 101 2018
 - NATIONAL FIRE PROTECTION ASSOCIATION 1 2018
 - INTERNATIONAL MECHANICAL CODE 2021*
 - INTERNATIONAL ENERGY CONSERVATION CODE 2021*
 - INTERNATIONAL PLUMBING CODE 2021*
 - INTERNATIONAL FUEL GAS CODE 2021*
 - THE LIQUEFIED PETROLEUM GAS CODE (NFPA 54) 2020*
- * WITH LOCAL AMENDMENTS


DESCRIPTION OR WORK

THE ENTIRE BASEMENT WILL BE MODIFIED WITH A PARTIAL CHANGE OF OCCUPANCY TO PROVIDE SMALL ASSEMBLY BUSINESS AND BUSINESS OCCUPANCIES, INCLUDING RESTROOMS, IN A PREVIOUSLY STORAGE OCCUPANCY. THE FIRST FLOOR RESTROOMS WILL BE RENOVATED TO IMPROVE ACCESSIBILITY. THE SECOND FLOOR WILL BE RENOVATED WITH PARTIAL MODIFICATIONS AND A PARTIAL CHANGE OF USE TO PROVIDE NEW OPEN AND ENCLOSED OFFICE SPACES IN EXISTING BUSINESS OCCUPANCY SPACES. EXISTING EGRESS / EXITS WILL REMAIN UNCHANGED. NO WORK ON THE BUILDING EXTERIOR OR SHELL WILL OCCUR.

LOCATION MAP

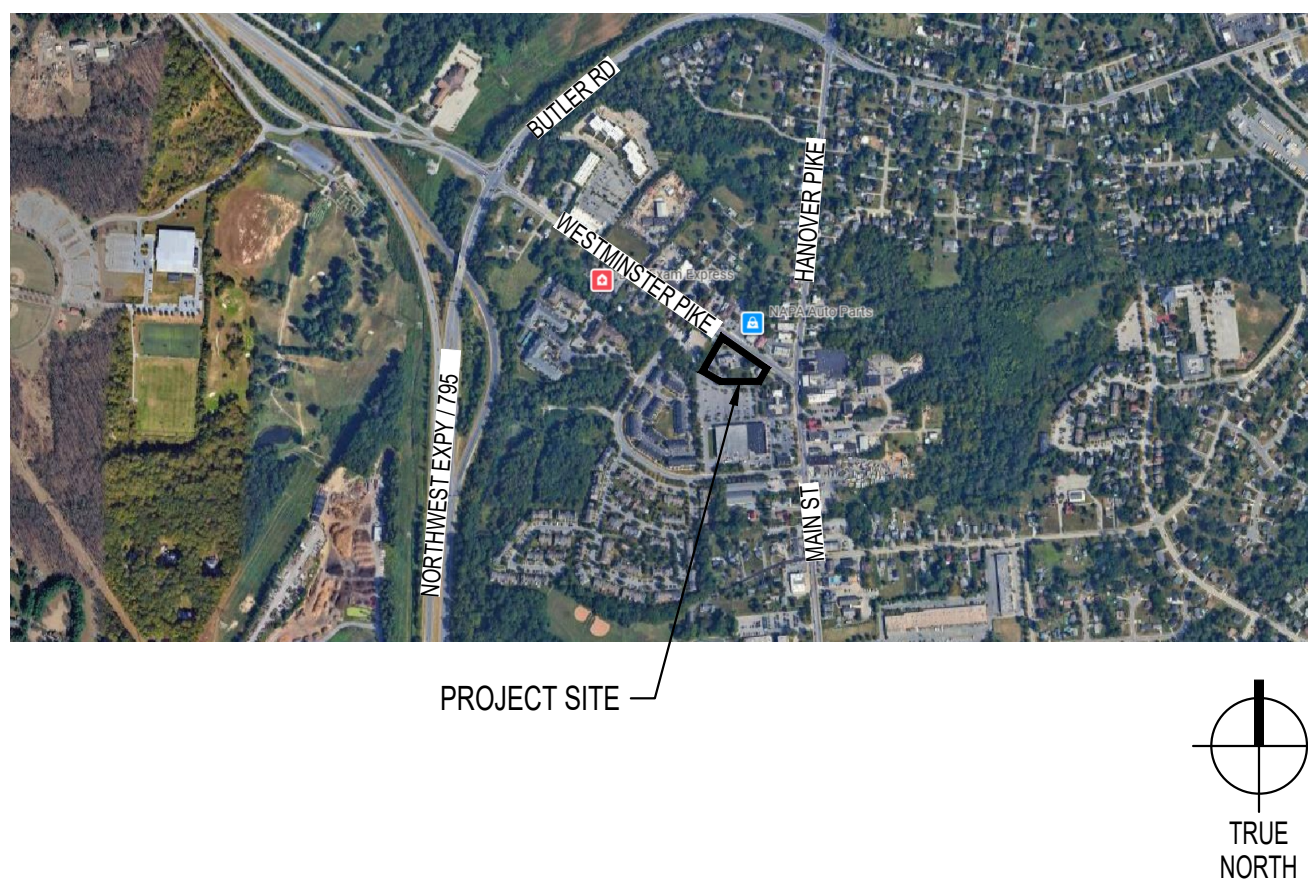

FARMERS & MERCHANTS
BANK
25 WESTMINSTER PIKE
REISTERSTOWN, MARYLAND, 21136
INTERIOR ALTERATION

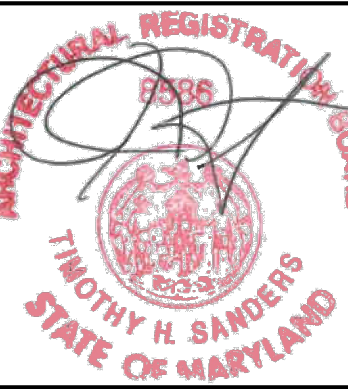

I CERTIFY THAT THESE DOCUMENTS WERE PREPARED OR APPROVED BY ME AND THAT I AM A DULY LICENSED ARCHITECT
UNDER THE LAWS OF THE STATE OF MARYLAND.

LICENSE NO.: 8586
EXP. DATE: 21 MAY 2027

THESE DRAWINGS ARE NOT PERMITTED TO BE COPIED OR REPRODUCED, EITHER WHOLLY OR PARTIALLY, UNLESS WRITTEN PERMISSION IS FIRST OBTAINED FROM SANDERS DESIGNS, P.A.

SANDERS | DESIGNS
ARCHITECTS PLANNERS
MAILBOX@SANDERSDESIGNS.COM
WWW.SANDERSDESIGNS.COM
9727 GREENSIDE DRIVE, SUITE 202, COCKEYSVILLE, MARYLAND 21030
T: (410) 560 2624

No.	Date	Revision

Project No.: 26.102
Date: 29 SEPTEMBER 2026
Scale: NONE
Edition:
PERMIT SET

Drawing Name:
Drawing Number:

TITLE SHEET
G001

G01. OWNER WILL OCCUPY PORTIONS OF BUILDING. CONDUCT WORK TO AVOID DISRUPTING OPERATIONS.

G02. MAINTAIN ALL WARRANTIES FOR SYSTEMS AND ASSEMBLIES AFFECTED BY THE WORK. REMOVE, REPLACE, PATCH AND REPAIR MATERIALS CUT OR DAMAGED. COORDINATE W/ MFRS.

G03. SURVEY EXISTING CONDITIONS AND RECORD FINDINGS VIA NOTES AND PHOTOS.

G04. PROVIDE TEMPORARY DUST CONTROL MEASURES USING 10 MIL POLYETHYLENE SHEETS AND DUST-CONTROL ADHESIVE WALK-OFF MATS. COMPLY WITH ASTM E84.

G05. MAINTAIN ACCESS TO ALL STAIRS, ELEVATORS, AND EXITS FROM OCCUPIED PORTIONS OF THE BUILDING.

G06. MAINTAIN FUNCTIONALITY AND CODE COMPLIANCE OF ALL

FIRE SUPPRESSION AND FIRE ALARM SYSTEMS ACTIVE IN THE BUILDING. SCHEDULE ALL REQUIRED SHUT-DOWNS WITH THE OWNER AND LIMIT THEM TO THE SHORTEST TIME FRAME POSSIBLE.

7. PROTECT ALL SYSTEMS AND FINISHES NOT SCHEDULED FOR DEMOLITION OR REMOVAL. PATCH AND REPAIR TO LIKE NEW CONDITION ANY DAMAGE TO EXISTING MATERIALS TO REMAIN.

8. SALVAGE DOOR, FRAME, AND HARDWARE FOR REINSTALLATION WHERE COMPATIBLE WITH LOCK FUNCTION AND SWING DIRECTION OF NEW DOORS, AND APPROVED BY THE OWNER.

9. ONE HEAT PUMP (HP) SERVING THE IT OFFICE MUST BE OPERATIONAL AT ALL TIMES. NEW HP MUST BE OPERATIONAL PRIOR TO WORK RELATED TO EXISTING HP BEGINNING.

D01. DEMOLISH ALL RESTROOM FIXTURES, PLUMBING, MILLWORK, S
AND ACCESSORIES.

D02. DEMOLISH FLOOR FINISH AND WALL BASE TO SUBSTRATE.

D03. DEMOLISH GYPSUM WALL BOARD DOWN TO STUDS TO THE
EXTENTS REQUIRED TO INSTALL NEW TILE BACKING PANELS.

D04. REMOVE ALL WALL PAPER FINISH THROUGHOUT.

D05. REMOVE WINDOW TREATMENTS AND VALANCES.

D06. DEMOLISH H.M. FRAMED GLAZED SIDE LITES.

D07. DEMOLISH BASE CABINETS, WORK SURFACES, AND WALL
MOUNTED MILLWORK.

D08. DEMOLISH COUNTER MOUNTED FIXTURES AND PLUMBING
BACK TO WALL.

D09. EX. SPRINKLER SYSTEM ANNUNCIATOR PANEL AND

ACTIVATION SWITCH.

D10. EX. SPRINKLER MANIFOLD.

D11. EX. MAIN ELEC PANEL.

D12. EX. LOW VOLTAGE / COMMUNICATION BOARD.

D13. EX. SUMP PUMP BELOW SLAB.

D14. EX. AIR HANDLER.

D15. EX. RTU.

D16. EX. EXHAUST FAN.

D17. EX. VENT PIPE.

D18. EX. SCREEN ENCLOSURE.

D19. DEMOLISH BUR AS NECESSARY TO INSTALL NEW EQUIPMENT
RAILS, APPROXIMATE LOCATION. COORDINATE W/ MEP.

D20. EX. ROOF ACCESS HATCH.

D21. EX. ROOF DRAIN & COVER.

D22. EX. CONDENSING UNIT, TO REMAIN.

D23. EX. EXIT SIGN, WALL MOUNTED FIRE ALARM SIGNAL, LIGHT SWITCH, AND WALL MOUNTED OCCUPANCY SENSOR TO BE REMOVED AND SALVAGED. PREPARE TO EXTEND ANY SYSTEMS FOR REINSTALLATION.

D24. EX. EXIT SIGN, WALL MOUNTED FIRE ALARM PULL STATION AND SIGNAL, THERMOSTAT, AND LIGHT SWITCH TO BE REMOVED AND SALVAGED. PREPARE TO EXTEND ANY SYSTEMS FOR REINSTALLATION.

D25. EX. ELEVATOR CALL BUTTONS / PANEL AND SAFETY SIGN TO BE REMOVED AND SALVAGED. PREPARE TO EXTEND ANY SYSTEMS FOR REINSTALLATION.

D26. EX. SANITARY STUB-UP IN SLAB. VERIFY SIZE AND LOCATION IN FIELD.

D27. EX. VENT PIPE. VERIFY SIZE AND LOCATION IN FIELD.

D28. SALVAGE COMBINATION LOCK AND LEVER HARDWARE FOR REINSTALLATION.

D29. DEMOLISH FURRED WALL SYSTEM TO THE EXTENTS INDICATED.

D30. REMOVE AND STORE EX HEAT PUMP FOR REINSTALLATION AND RECONNECTION IN THE SAME LOCATION. DEMOLISH HOUSEKEEPING PAD. DEMOLISH BUR AS NECESSARY TO INSTALL NEW EQUIPMENT RAILS.

D31. EXISTING BUILT-UP ROOF AND GRAVEL TO REMAIN. UNO.

D32. EXISTING PITCH POCKET PENETRATION. PREPARE TO RECEIVE NEW EQUIPMENT PENETRATIONS. COORDINATE WITH MEP


 EXISTING WALLS/PARTITIONS TO BE DEMOLISHED
 EXISTING WALLS/PARTITIONS TO REMAIN
 EXISTING DOOR & FRAME TO BE DEMOLISHED
 EXISTING DOOR & FRAME TO REMAIN

B6

A6



SCALE: 1/8" = 1'-0"

ROOF PLAN | D3



SCALE: $1/8" = 1'-0"$

FIRST FLOOR PLAN | A3 |



SCALE: 1/8" = 1'-0"


SECOND FLOOR PLAN | D1



SCALE: 1/8" = 1'-0"

BASEMENT FLOOR PLAN | A1

INTERIOR ALTERATION

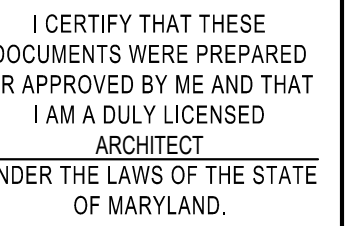

CENSE NO.: 8586

KP. DATE: 21 MAY 2027

THESE DRAWINGS ARE NOT
ERMITTED TO BE COPIED OR
EPRODUCED, EITHER WHOLLY
OR PARTIALLY, UNLESS
WRITTEN PERMISSION IS FIRST
OBTAINED FROM SANDERS
DESIGNS, P.A.

ARCHITECTS PLANNERS

Date	Revision

Project No.:	26.102
Due:	29 SEPTEMBER 2026
Scale:	1/8" = 1'-0"
Description:	
PERMIT SET	

Wing Name:
**DEMOLITION
 FLOOR PLANS**
 Wing Number:

AD101

RCP DEMOLITION GENERAL NOTES:

- G01. OWNER WILL OCCUPY PORTIONS OF BUILDING. CONDUCT WORK TO AVOID DISRUPTING OPERATIONS.
G02. MAINTAIN ALL WARRANTIES FOR SYSTEMS AND ASSEMBLIES AFFECTED BY THE WORK. REMOVE, REPLACE, PATCH AND REPAIR MATERIALS CUT OR DAMAGED. COORDINATE W/ MFRS.
G03. SURVEY EXISTING CONDITIONS AND RECORD FINDINGS VIA NOTES AND PHOTOS.
G04. PROVIDE TEMPORARY DUST CONTROL MEASURES USING 10 MIL. POLYETHYLENE SHEETS AND DUST-CONTROL ADHESIVE WALK-OFF MATS. COMPLY WITH ASTM E84.
G05. MAINTAIN ACCESS TO ALL STAIRS, ELEVATORS, AND EXITS FROM OCCUPIED PORTIONS OF THE BUILDING.
G06. SPACES SHOWN AS BLANK EITHER HAVE NO CEILING OR ARE

EXISTING TO REMAIN.

- G07. MAINTAIN FUNCTIONALITY AND CODE COMPLIANCE OF ALL FIRE SUPPRESSION AND FIRE ALARM SYSTEMS ACTIVE IN THE BUILDING. SCHEDULE ALL REQUIRED SHUT-DOWNS WITH THE OWNER AND LIMIT THEM TO THE SHORTEST TIME FRAMES POSSIBLE.
G08. REMOVE AND SALVAGE ALL CEILING MOUNTED EQUIPMENT NOT SPECIFICALLY NOTED FOR DEMOLITION FOR REINSTALLATION IN SIMILAR LOCATION.
G09. SALVAGE REMOVED CEILING PANELS IN BASEMENT, IN GOOD CONDITION, FOR USE IN REPLACING DAMAGED PANELS WHERE GRID IS TO REMAIN. FIELD VERIFY NUMBER OF DAMAGED PANELS TO BE REPLACED AND COORDINATE WITH DEMOLITION.

G10. PROVIDE SUPPORT FOR GRID TO REMAIN AS NECESSARY DURING DEMOLITION OF ADJACENT GRID AND PANELS

- G11. REMOVE CEILING PANELS ON THE FIRST FLOOR WHERE REQUIRED TO ACCESS THE ABOVE CEILING SPACE FOR MEP WORK, WHETHER INDICATED ON THE DRAWINGS OR NOT. SALVAGE AND STORE FOR REINSTALLATION. RETAIN GRID SYSTEM WHERE POSSIBLE.

RCP DEMOLITION KEY NOTES:

- D01. APPROXIMATE LIMITS OF CEILING GRID DEMOLITION. COORDINATE WITH NEW WORK LAYOUT.
D02. DEMOLISH CEILING MOUNTED CHANDELIER.
D03. DEMOLISH WALL SCONCE BELOW BULKHEAD.
D04. DEMOLISH SPOT LIGHT MOUNTED ON BULKHEAD.
D05. EXISTING BULKHEAD TO REMAIN.
D06. DEMOLISH WALL MOUNTED VANITY LIGHT FIXTURE.
D07. OPEN TO GYPSUM CEILING ABOVE.

NOTES: DEMOLITION RCP

 
A6

- ACOUSTIC CEILING GRID & PANEL TO REMAIN
MECHANICAL EQUIPMENT TO REMAIN
DEMOLISHED ACOUSTIC CEILING GRID & PANEL
REMOVED MECHANICAL EQUIPMENT SALVAGE FOR REINSTALLATION
DEMOLISHED LIGHT FIXTURE
REMOVED EXIT SIGN SALVAGE FOR REINSTALLATION
DEMOLISHED SPOT LIGHT
DEMOLISHED WALL SCONCE

LEGEND: DEMOLITION RCP


D3

SCALE: 1/8" = 1'-0"



FIRST FLOOR RCP


A3

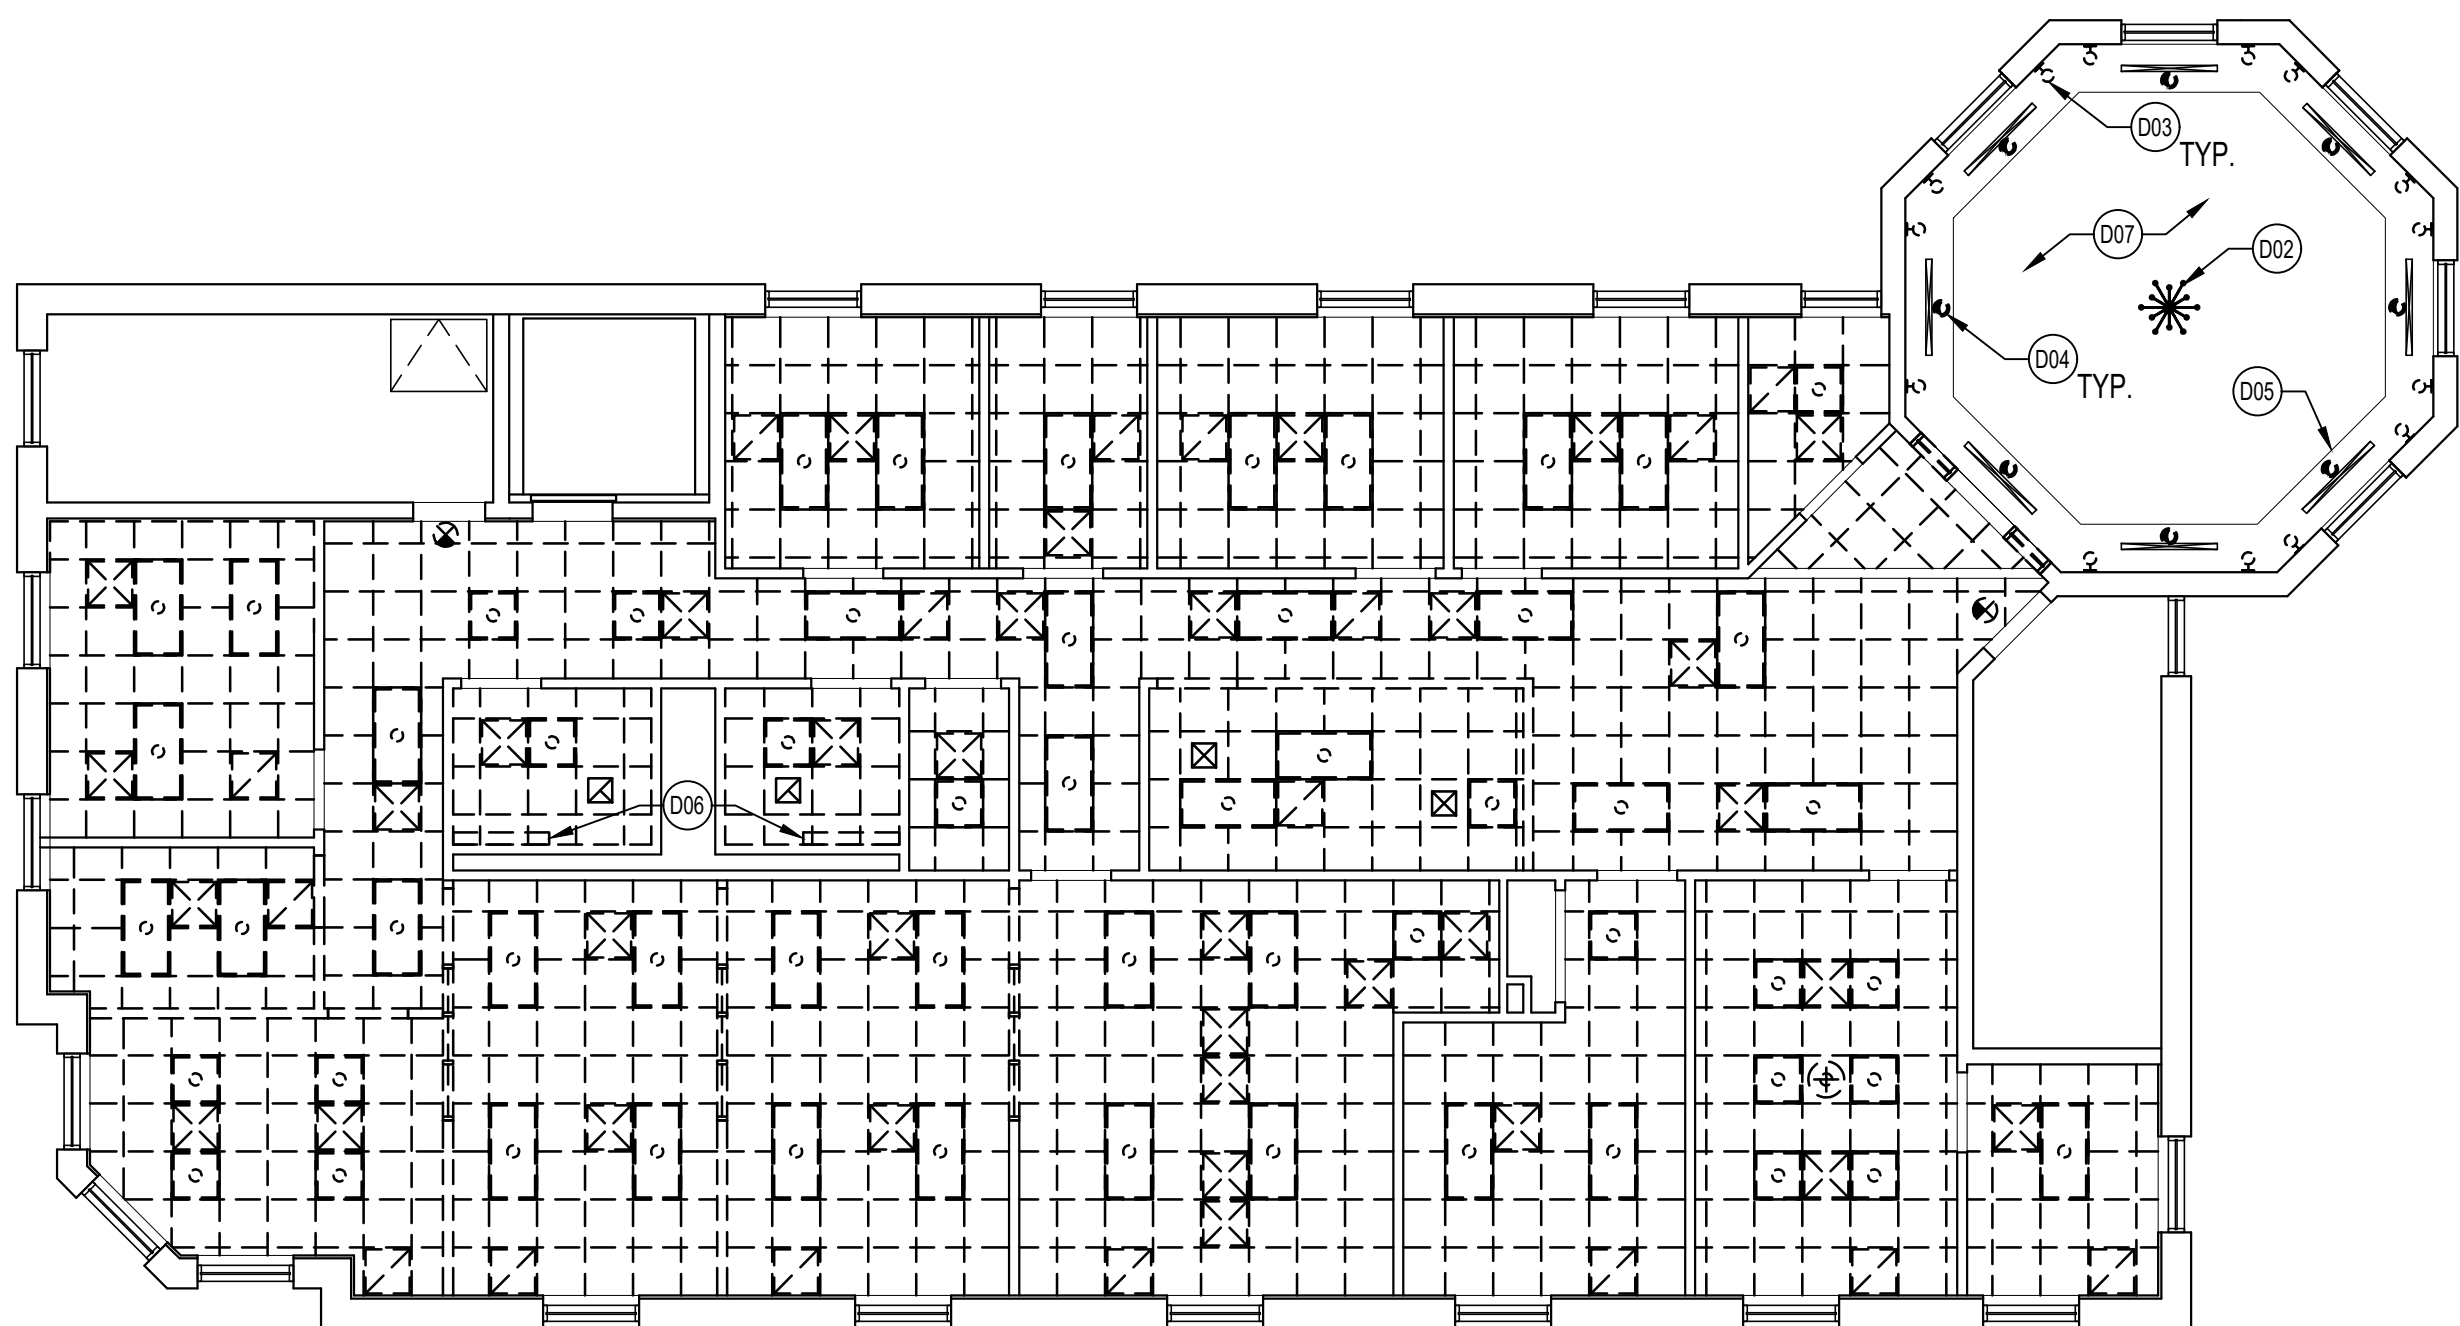

SECOND FLOOR RCP


D1

 SCALE: 1/8" = 1'-0"



BASEMENT RCP


A1

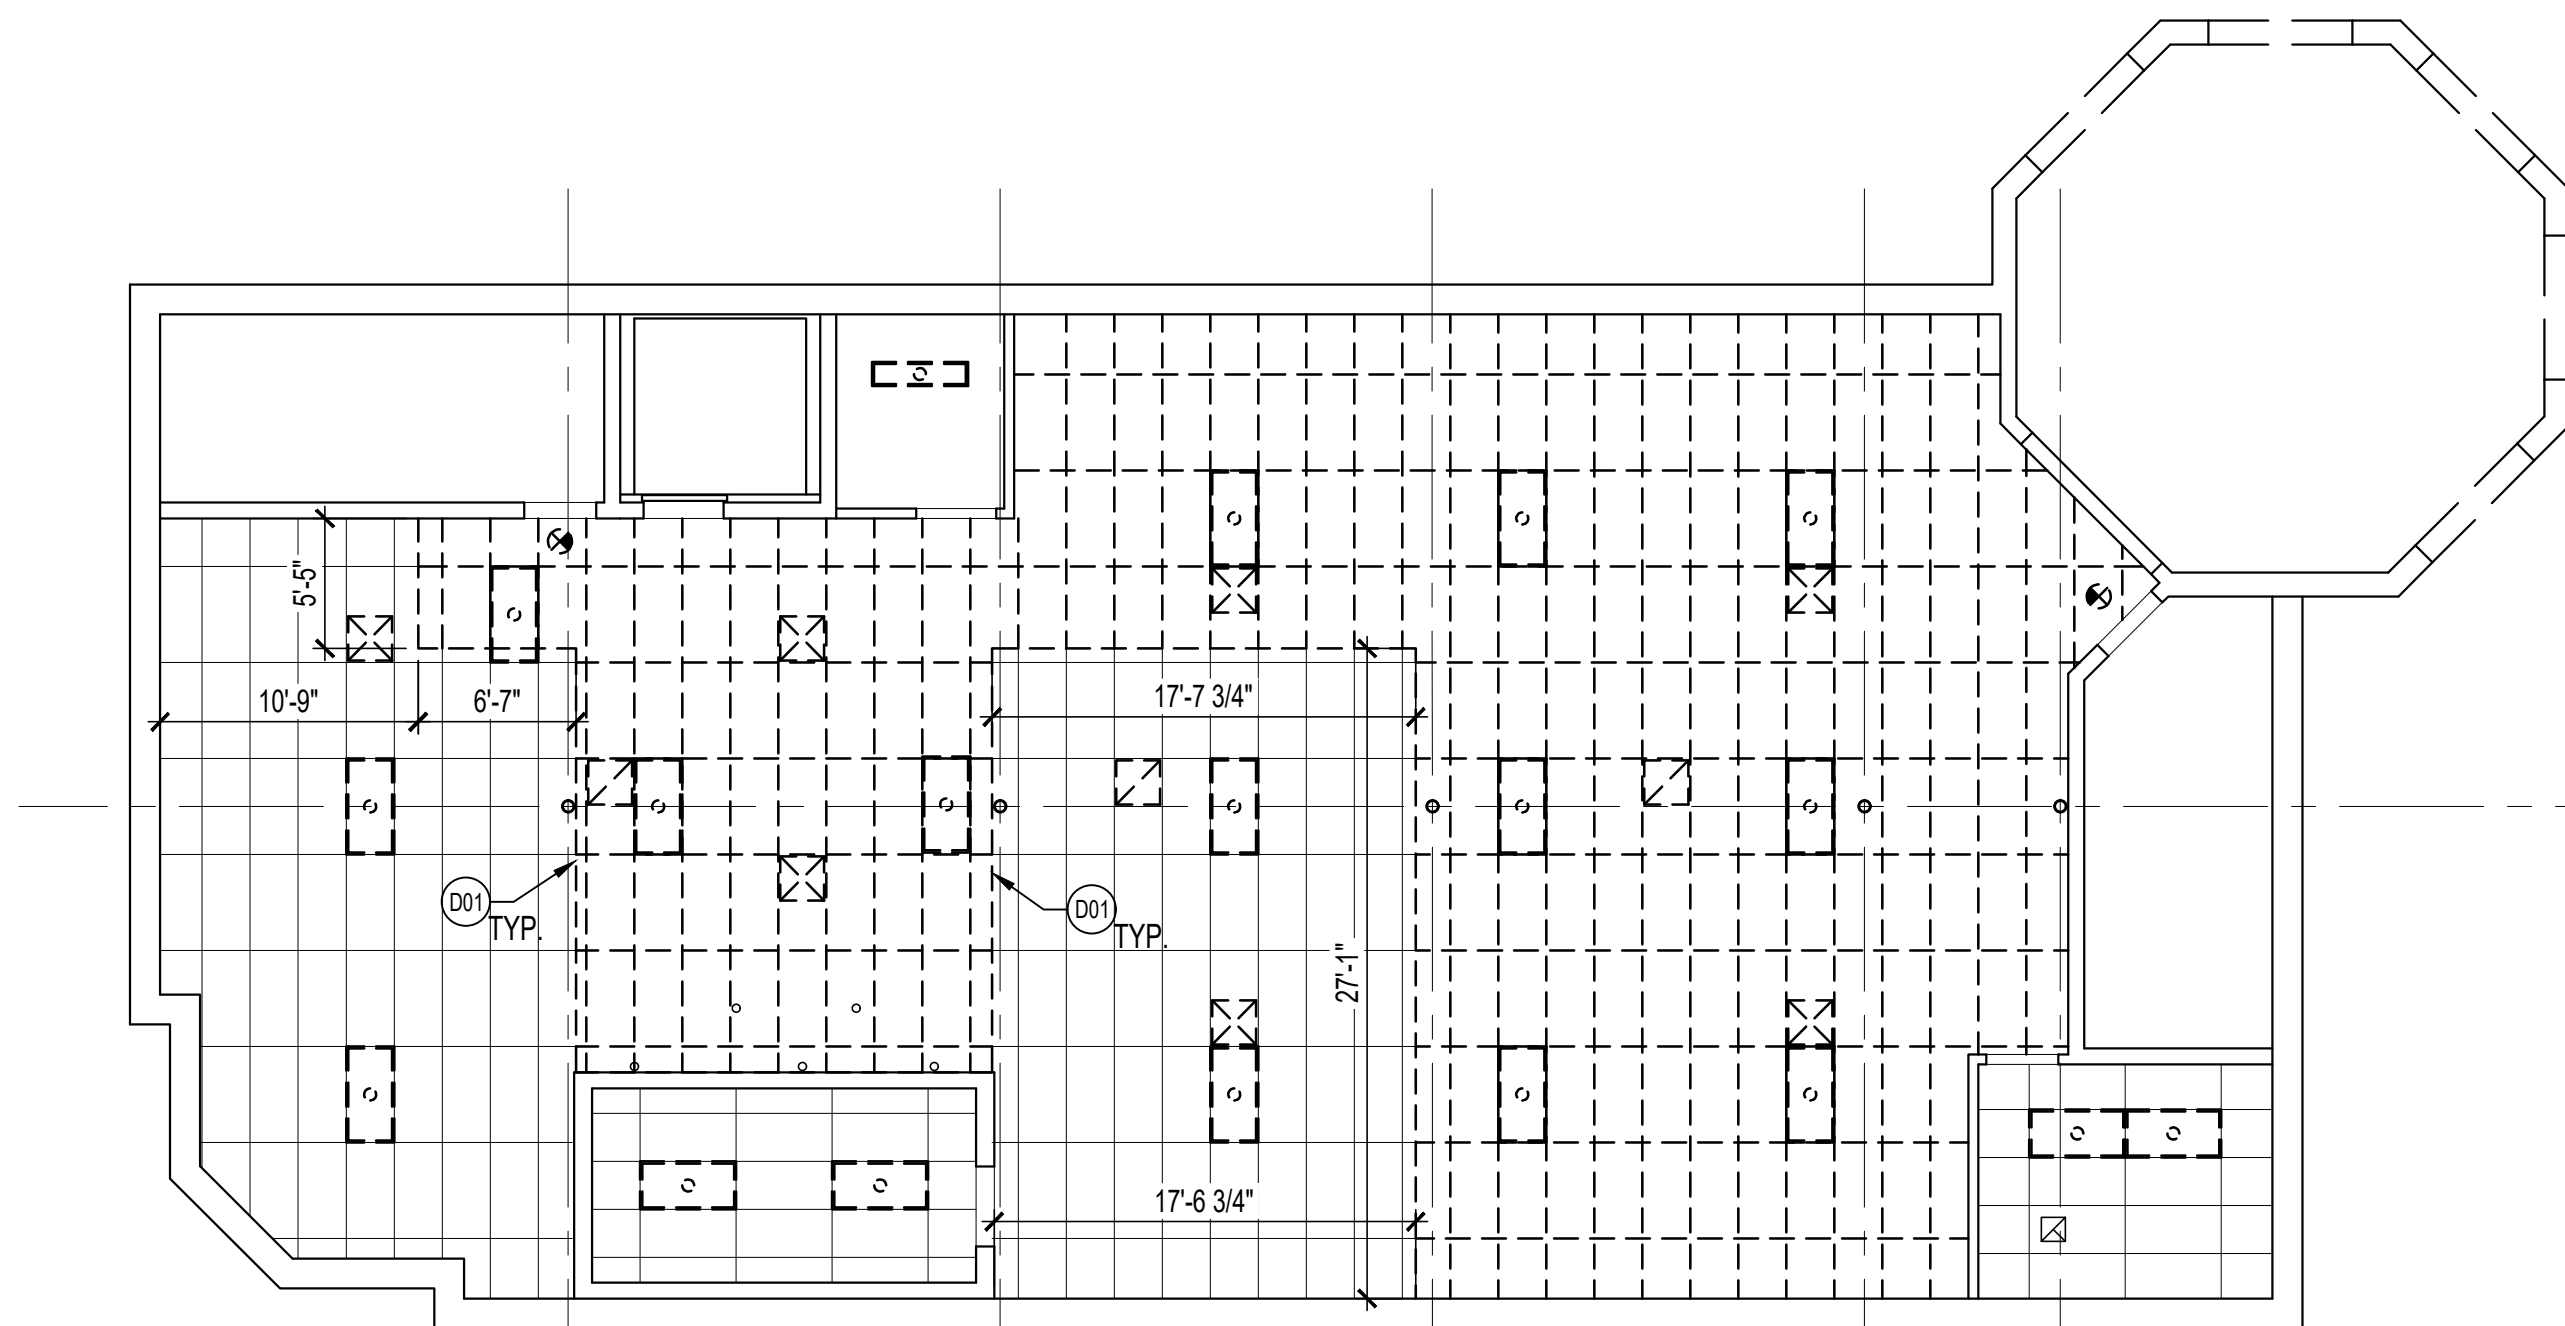

FARMERS & MERCHANTS
BANK

25 WESTMINSTER PIKE
REISTERTOWN, MARYLAND, 21136

INTERIOR ALTERATION

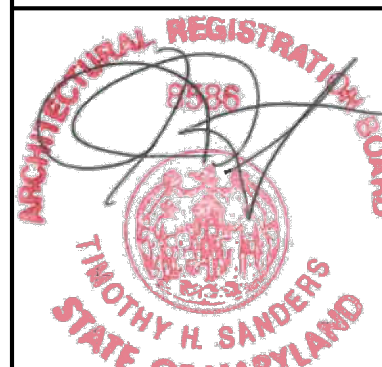

I CERTIFY THAT THESE DOCUMENTS WERE PREPARED OR APPROVED BY ME AND THAT I AM A DULY LICENSED ARCHITECT UNDER THE LAWS OF THE STATE OF MARYLAND.

LICENSE NO.: 8586

EXP. DATE: 21 MAY 2027

THESE DRAWINGS ARE NOT PERMITTED TO BE COPIED OR REPRODUCED, EITHER WHOLLY OR PARTIALLY, UNLESS WRITTEN PERMISSION IS FIRST OBTAINED FROM SANDERS DESIGNS, P.A.

SANDERS | DESIGNS
ARCHITECTS PLANNERS

WWW.SANDERSDESIGNS.COM
MAILBOX@SANDERSDESIGNS.COM
977 GREENSIDE DRIVE, SUITE 202, COCKEYSVILLE, MARYLAND 21030
T: (410) 560 2624

No.	Date	Revision

Project No.: 26.102

Date: 29 SEPTEMBER 2026

Scale: 1/8" = 1'-0"

Edition:

PERMIT SET

Drawing Name:

DEMOLITION
RCPs

Drawing Number:

AD111

PLAN GENERAL NOTES:

- G01. OWNER WILL OCCUPY PORTIONS OF BUILDING. CONDUCT WORK TO AVOID DISRUPTING OPERATIONS.
- G02. MAINTAIN ALL WARRANTIES FOR SYSTEMS AND ASSEMBLIES AFFECTED BY THE WORK. REMOVE, REPLACE, PATCH AND REPAIR MATERIALS CUT OR DAMAGED. COORDINATE W/ MFRS.
- G03. PROVIDE TEMPORARY DUST CONTROL MEASURES USING 10 MIL POLYETHYLENE SHEETS AND DUST-CONTROL ADHESIVE WALK-OFF MATS. COMPLY WITH ASTM E84.
- G04. MAINTAIN ACCESS TO ALL STAIRS, ELEVATORS, AND EXITS FROM OCCUPIED PORTIONS OF THE BUILDING.
- G05. PROVIDE REVISED FIRE SUPPRESSION SYSTEM DESIGN AND PERMITS UTILIZING THE EXISTING SYSTEM BASED ON THE REVISED BUILDING LAYOUT.

- G06. PROVIDE REVISED FIRE ALARM SYSTEM DESIGN AND PERMITS UTILIZING THE EXISTING SYSTEM BASED ON THE REVISED BUILDING LAYOUT. MATCH EXISTING EQUIPMENT AND MOUNTING TYPE.
- G07. THE OWNER REQUESTS THE USE OF THE SUB-CONTRACTORS LISTED AS A PREFERRED VENDOR FOR THE PROJECT.
- G08. ONE HEAT PUMP (HP) SERVING THE IT OFFICE MUST BE OPERATIONAL AT ALL TIMES. NEW HP MUST BE OPERATIONAL PRIOR TO WORK RELATED TO EXISTING HP BEGINNING.
- G09. INSTALL NEW AND EXISTING CONDENSATE LINES, ELECTRICAL CONDUIT, AND COOLANT LINES ON EQUIPMENT SUPPORTS. SEE DETAIL G3/A702. PROVIDE SUPPORTS AT MANUFACTURER RECOMMENDED INTERVALS.

PLAN KEY NOTES:

01. REINSTALL EXIT SIGN, WALL MOUNTED FIRE ALARM SIGNAL, LIGHT SWITCH, AND WALL MOUNTED OCCUPANCY SENSOR ON NEW FINISHED WALL SURFACE. EXTEND ANY SYSTEMS FOR REINSTALLATION AS REQUIRED.
02. REINSTALL EXIT SIGN, WALL MOUNTED FIRE ALARM PULL STATION AND SIGNAL, THERMOSTAT, AND LIGHT SWITCH ON NEW FINISHED WALL SURFACE. EXTEND ANY SYSTEMS FOR REINSTALLATION AS REQUIRED.
03. REINSTALL ELEVATOR CALL BUTTONS / PANEL AND SAFETY SIGN ON NEW FINISHED WALL SURFACE. EXTEND ANY SYSTEMS FOR REINSTALLATION AS REQUIRED.
04. INSTALL SALVAGED COMBINATION LOCK AND LEVER HARDWARE. COORDINATE WITH DOOR SCHEDULE.

05. INSTALL TILE BACKING PANELS OVER FRAMING AND PREPARE TO RECEIVE NEW FINISH. COORDINATE WITH FINISH SCHEDULE AND ELEVATIONS.
06. COORDINATE INSTALLATION OF WINDOW TREATMENTS AT ALL WINDOWS WITH OWNER'S PREFERRED VENDOR.
07. PROVIDE BLOCKING AND / OR FRT STUDS WITHIN THE METAL FRAMING AS REQUIRED FOR ATTACHMENT OF CONCEALED SUPPORT BRACKETS AT VANITY.
08. PROVIDE 5/8" SOUNDBREAK XP BY NATIONAL GYPSUM, OR EQUAL, ON BOTH SIDES OF CONFERENCE ROOM WALL; STC-45 MINIMUM.
09. NEW HEAT PUMP INSTALLED ON NEW EQUIPMENT RAILS. SEE DETAIL G5/A702. COORDINATE RAIL SIZE AND LOCATION WITH SPECIFIED EQUIPMENT REQUIREMENTS.

10. REINSTALL EXISTING HEAT PUMP ON NEW EQUIPMENT RAILS. SEE DETAIL G5/A702. COORDINATE RAIL SIZE AND LOCATION WITH EQUIPMENT REQUIREMENTS.
11. PATCH AND REPAIR EXISTING PITCH POCKET AFTER INSTALLING NEW EQUIPMENT PENETRATIONS. SEE DETAIL G4/A702.

WINDOW TREATMENTS: TIRALLA'S INC. ADDRESS: 2 WOLF AVE, REISTERSTOWN, MD 21136, PHONE: 410-833-2107

HVAC: FLO-TRON CONTRACTING INC, ADDRESS: 220 COCKEYSVILLE RD, COCKEYSVILLE, MD 21030, PHONE: 410-527-0060

PAINTING: PRIDE PAITING, ADDRESS: 1940 BETHEL RD, FINKSBURG, MD 21048, PHONE: 410-876-8322

SIGNAGE: STRATEGIC FACTORY, ADDRESS: 10324 S DOLFIELD RD, OWINGS MILLS, MD 21117, PHONE: 443-548-3500

- EXISTING WALL / PARTITION
- EXISTING DOOR
- NEW WALL/PARTITION
- NEW DOOR
- NEW INTERIOR GLAZED WALL
- FIRE EXTINGUISHER AND CABINET LARSEN'S 2409-R4 AND MP5

NOTES: PLAN


C6

PREFERRED VENDORS LIST

B6


LEGEND: PLAN

A6

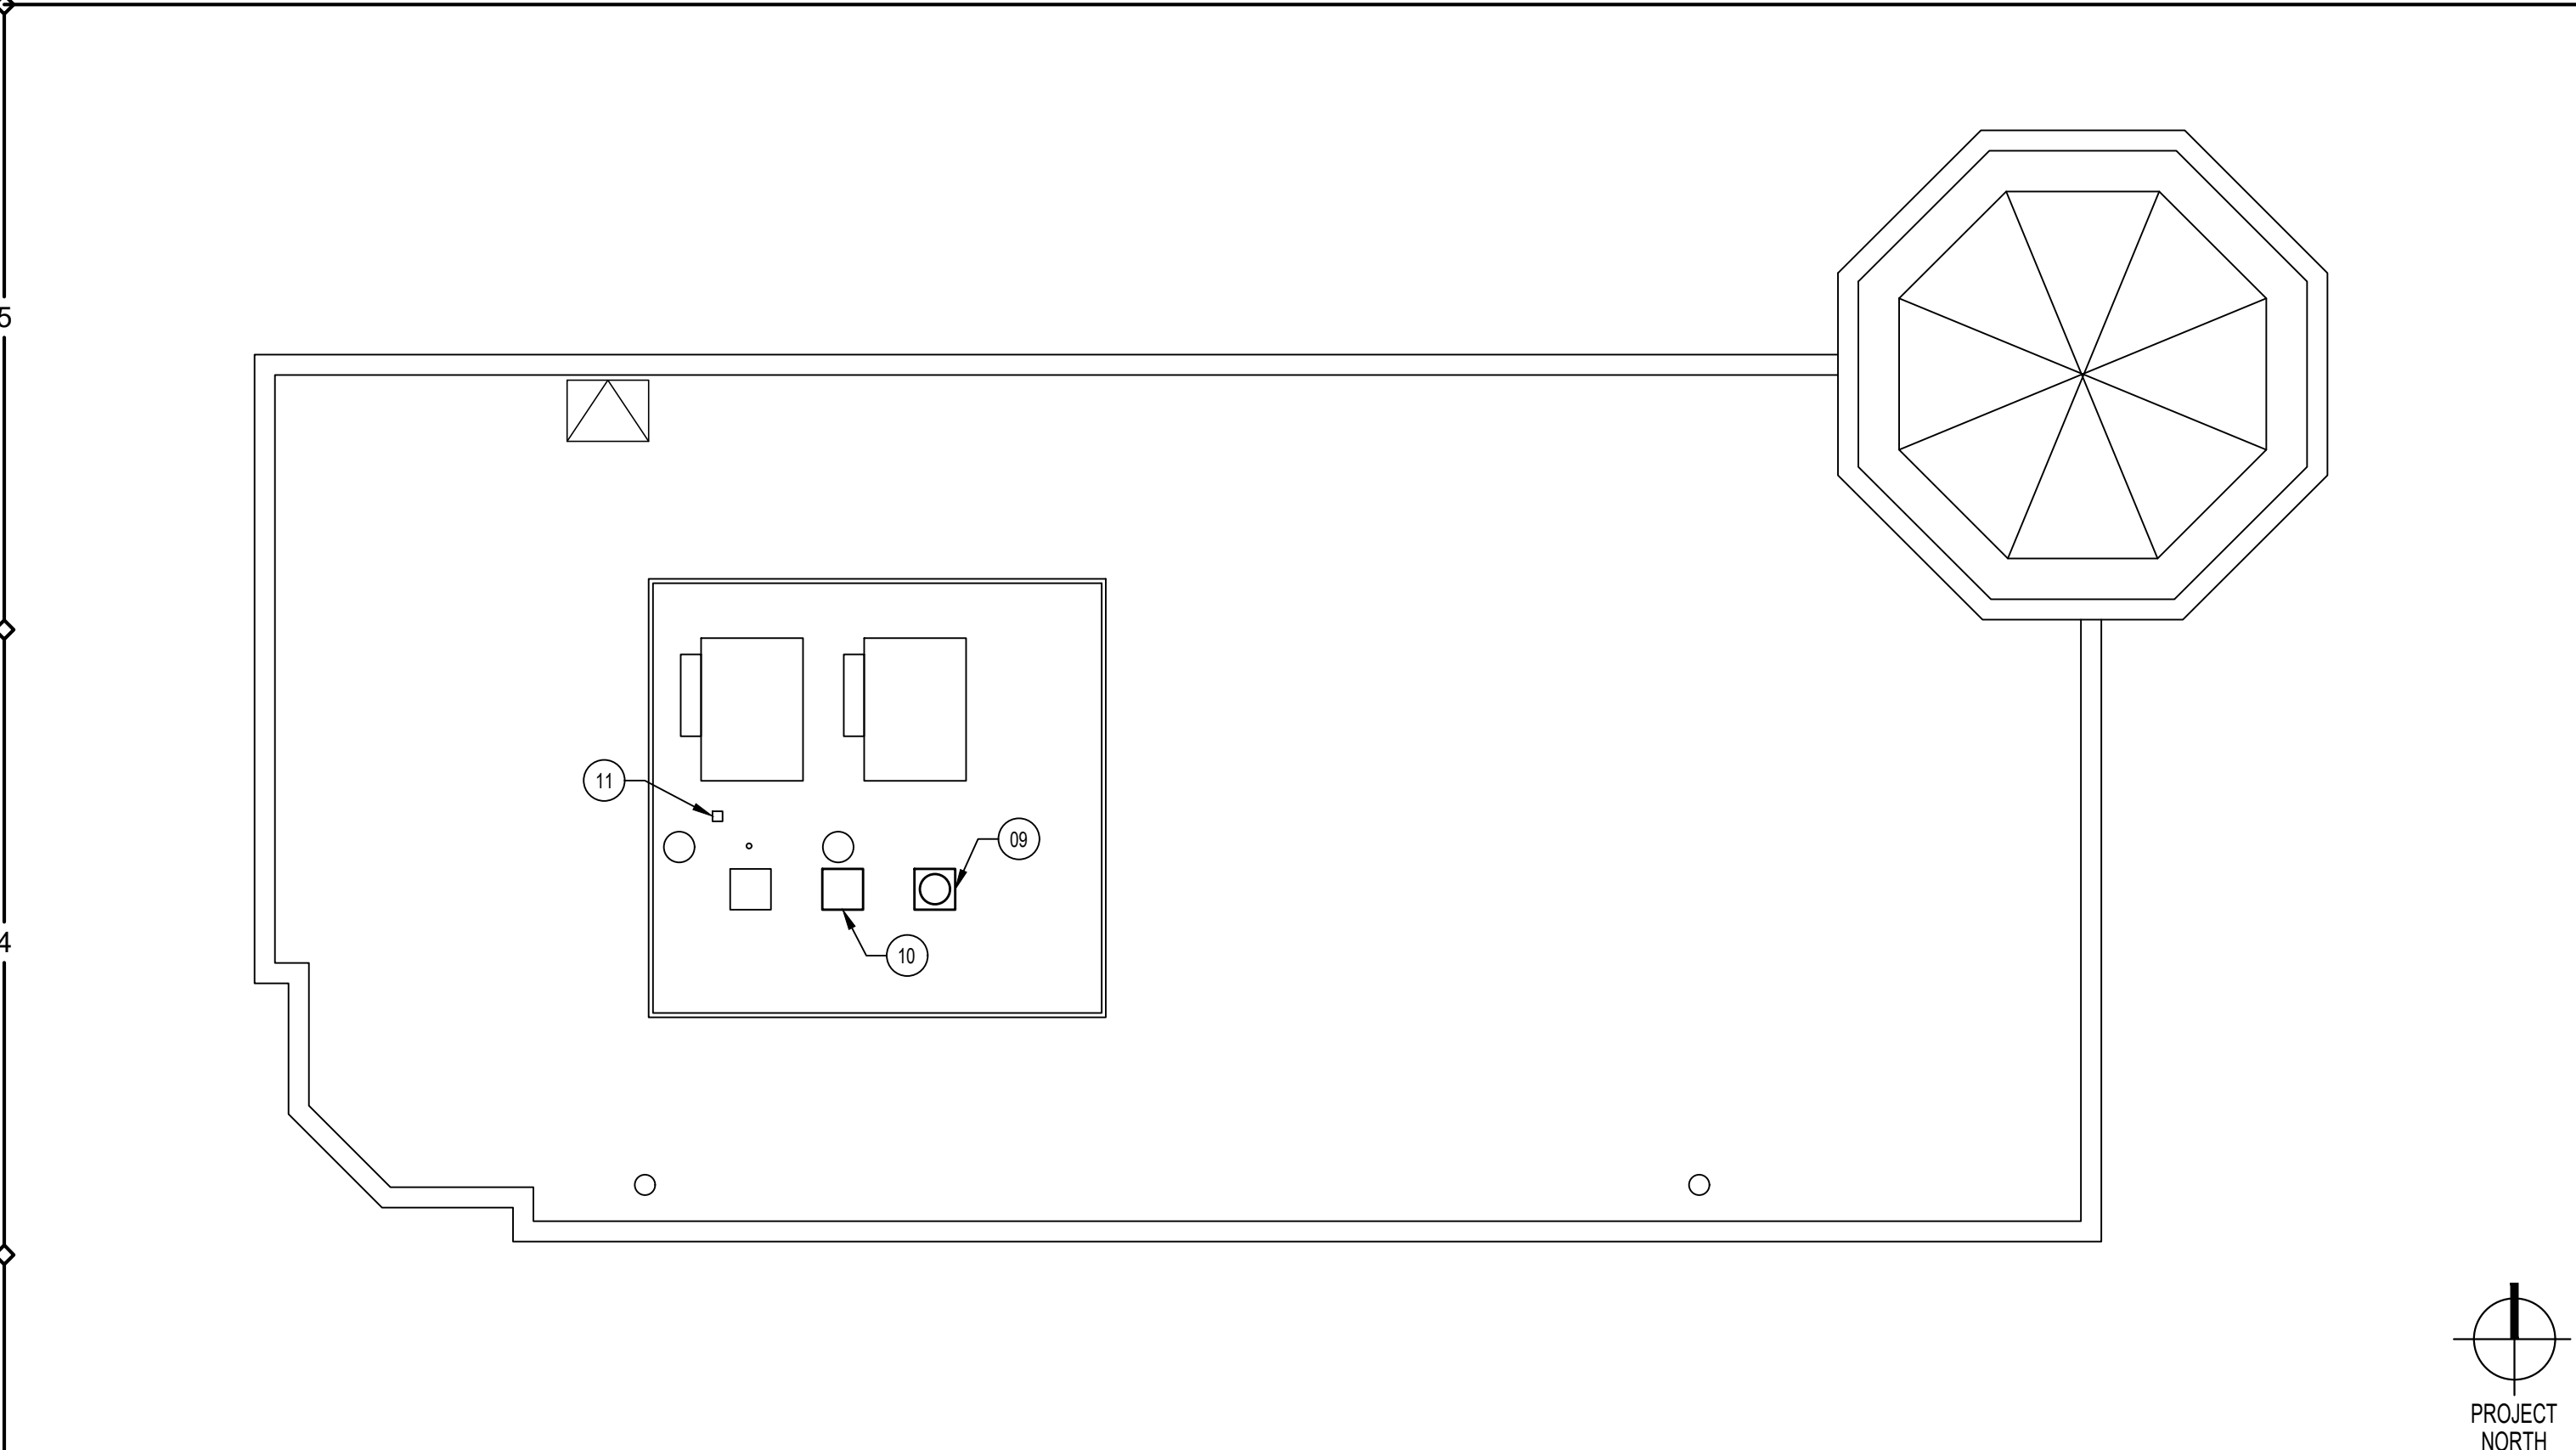


ROOF PLAN

D3

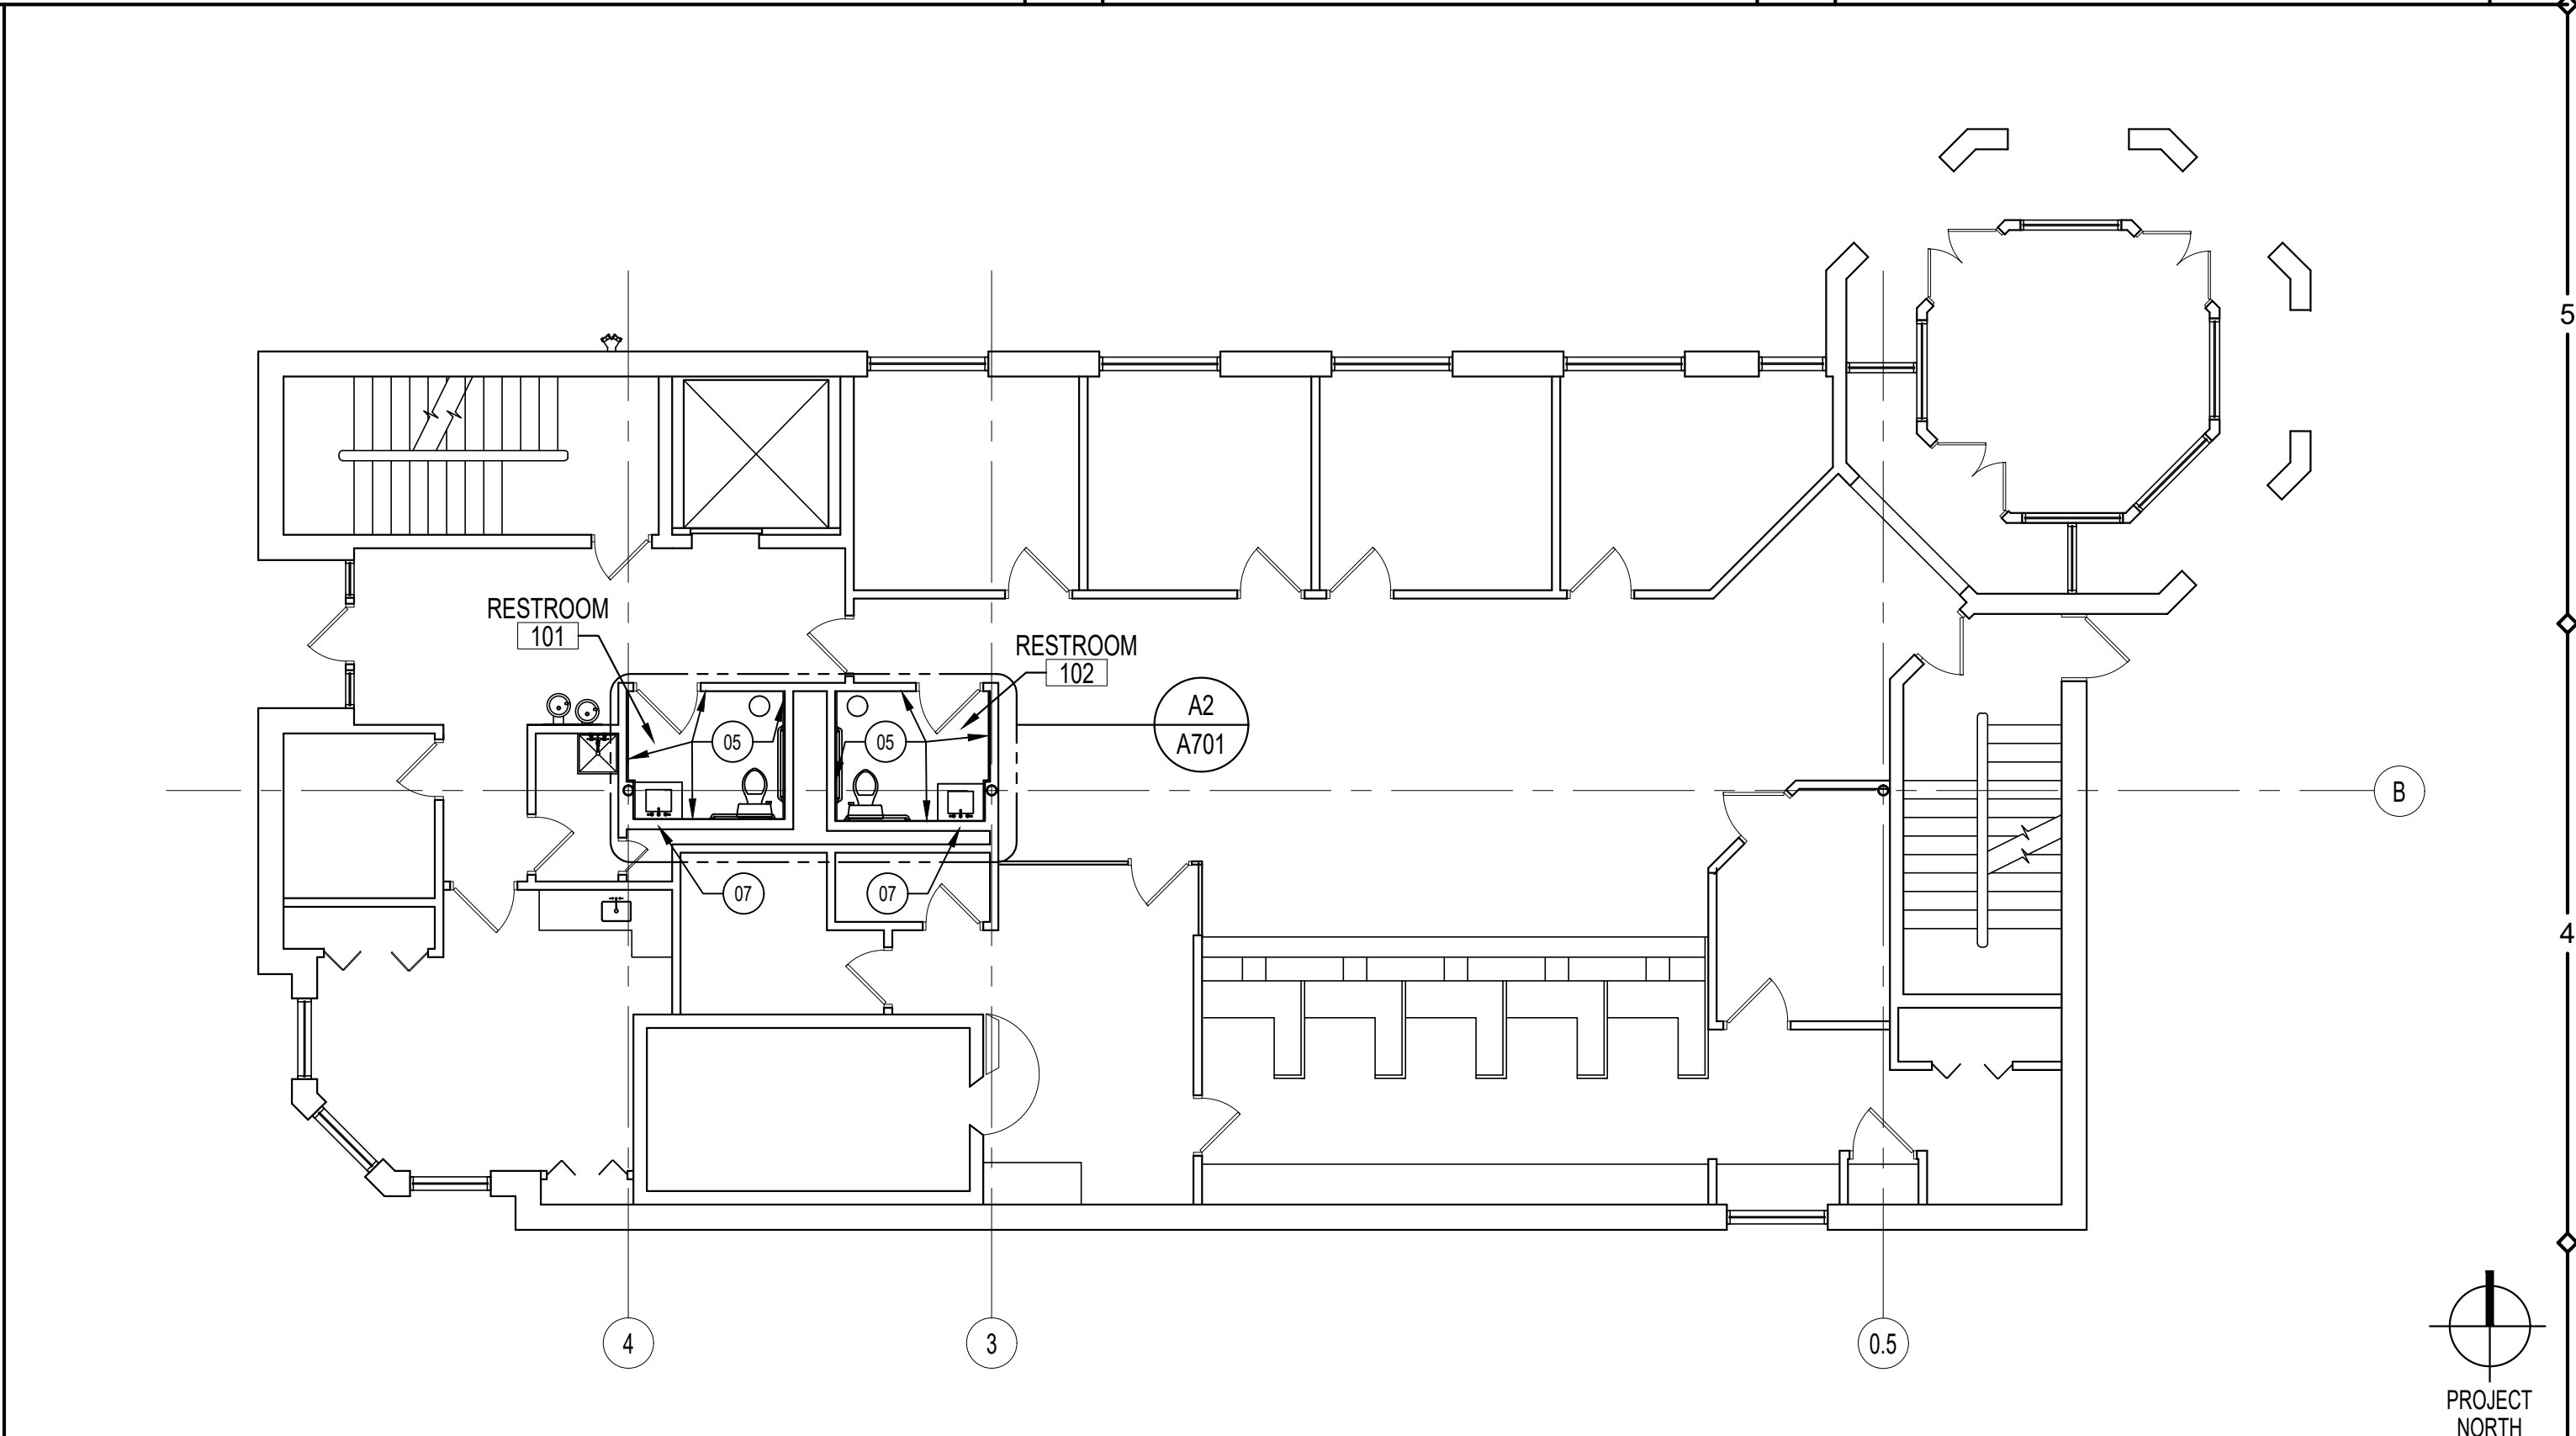


FIRST FLOOR PLAN

A3

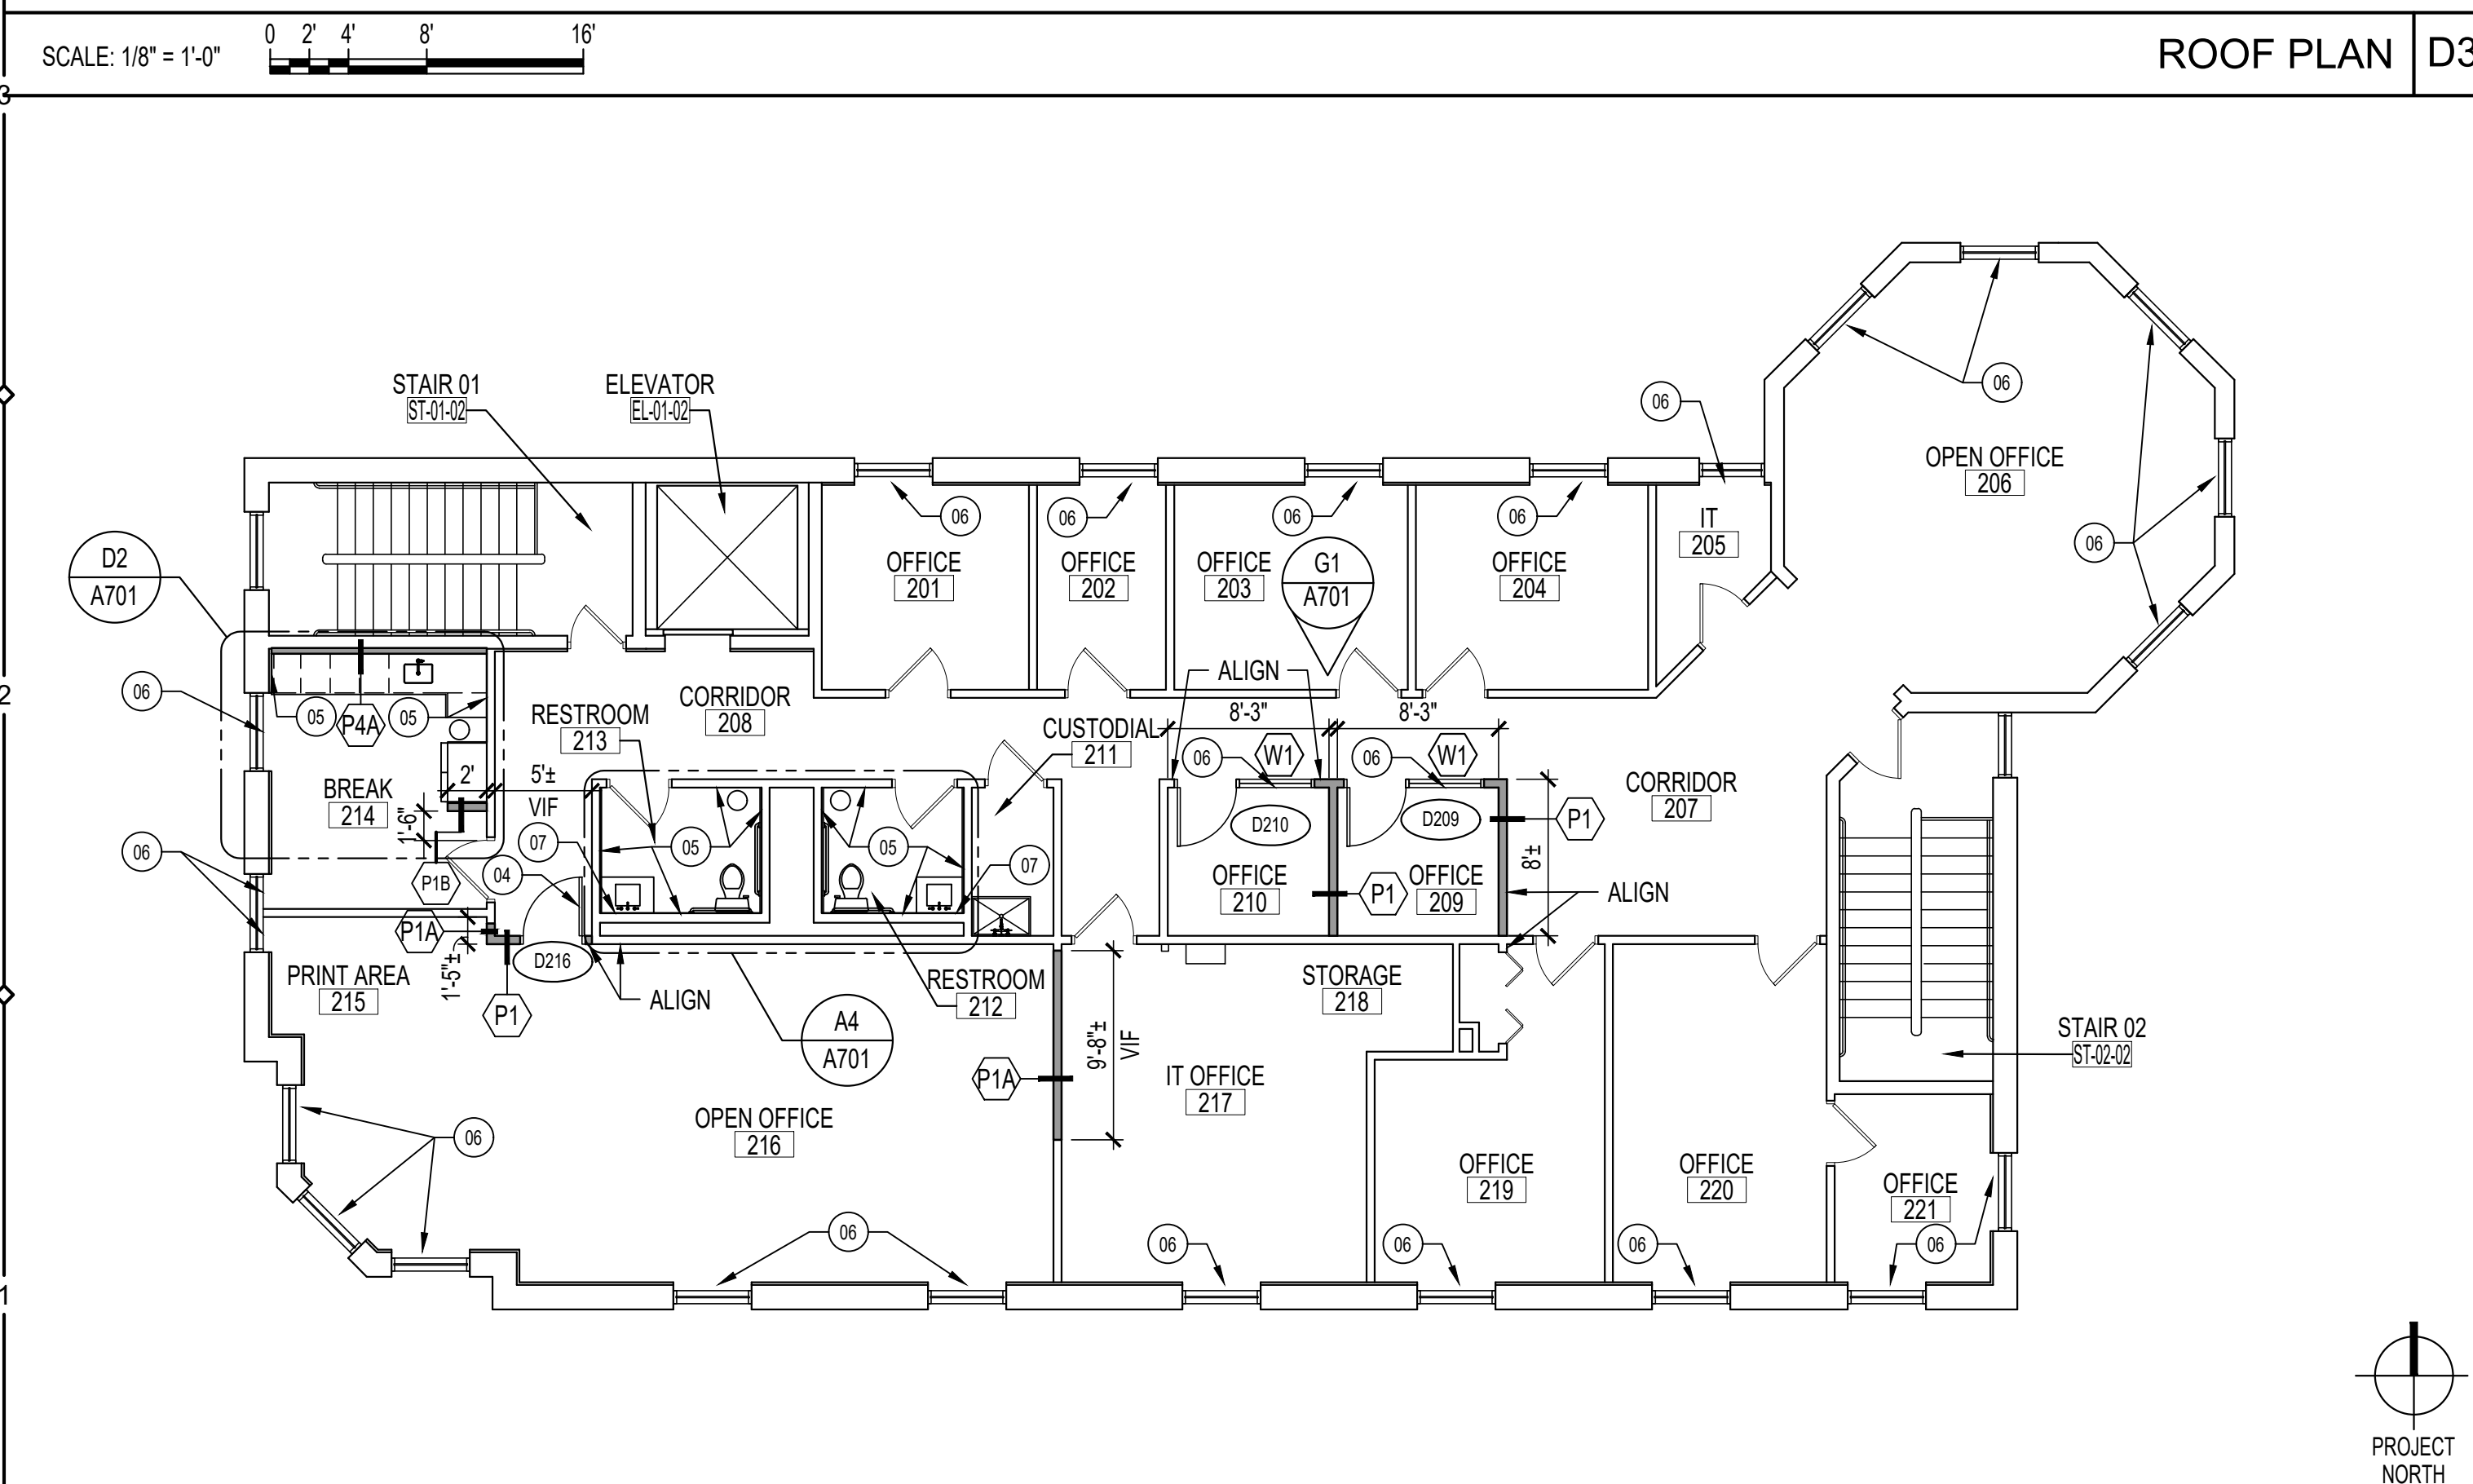

SECOND FLOOR PLAN

D1

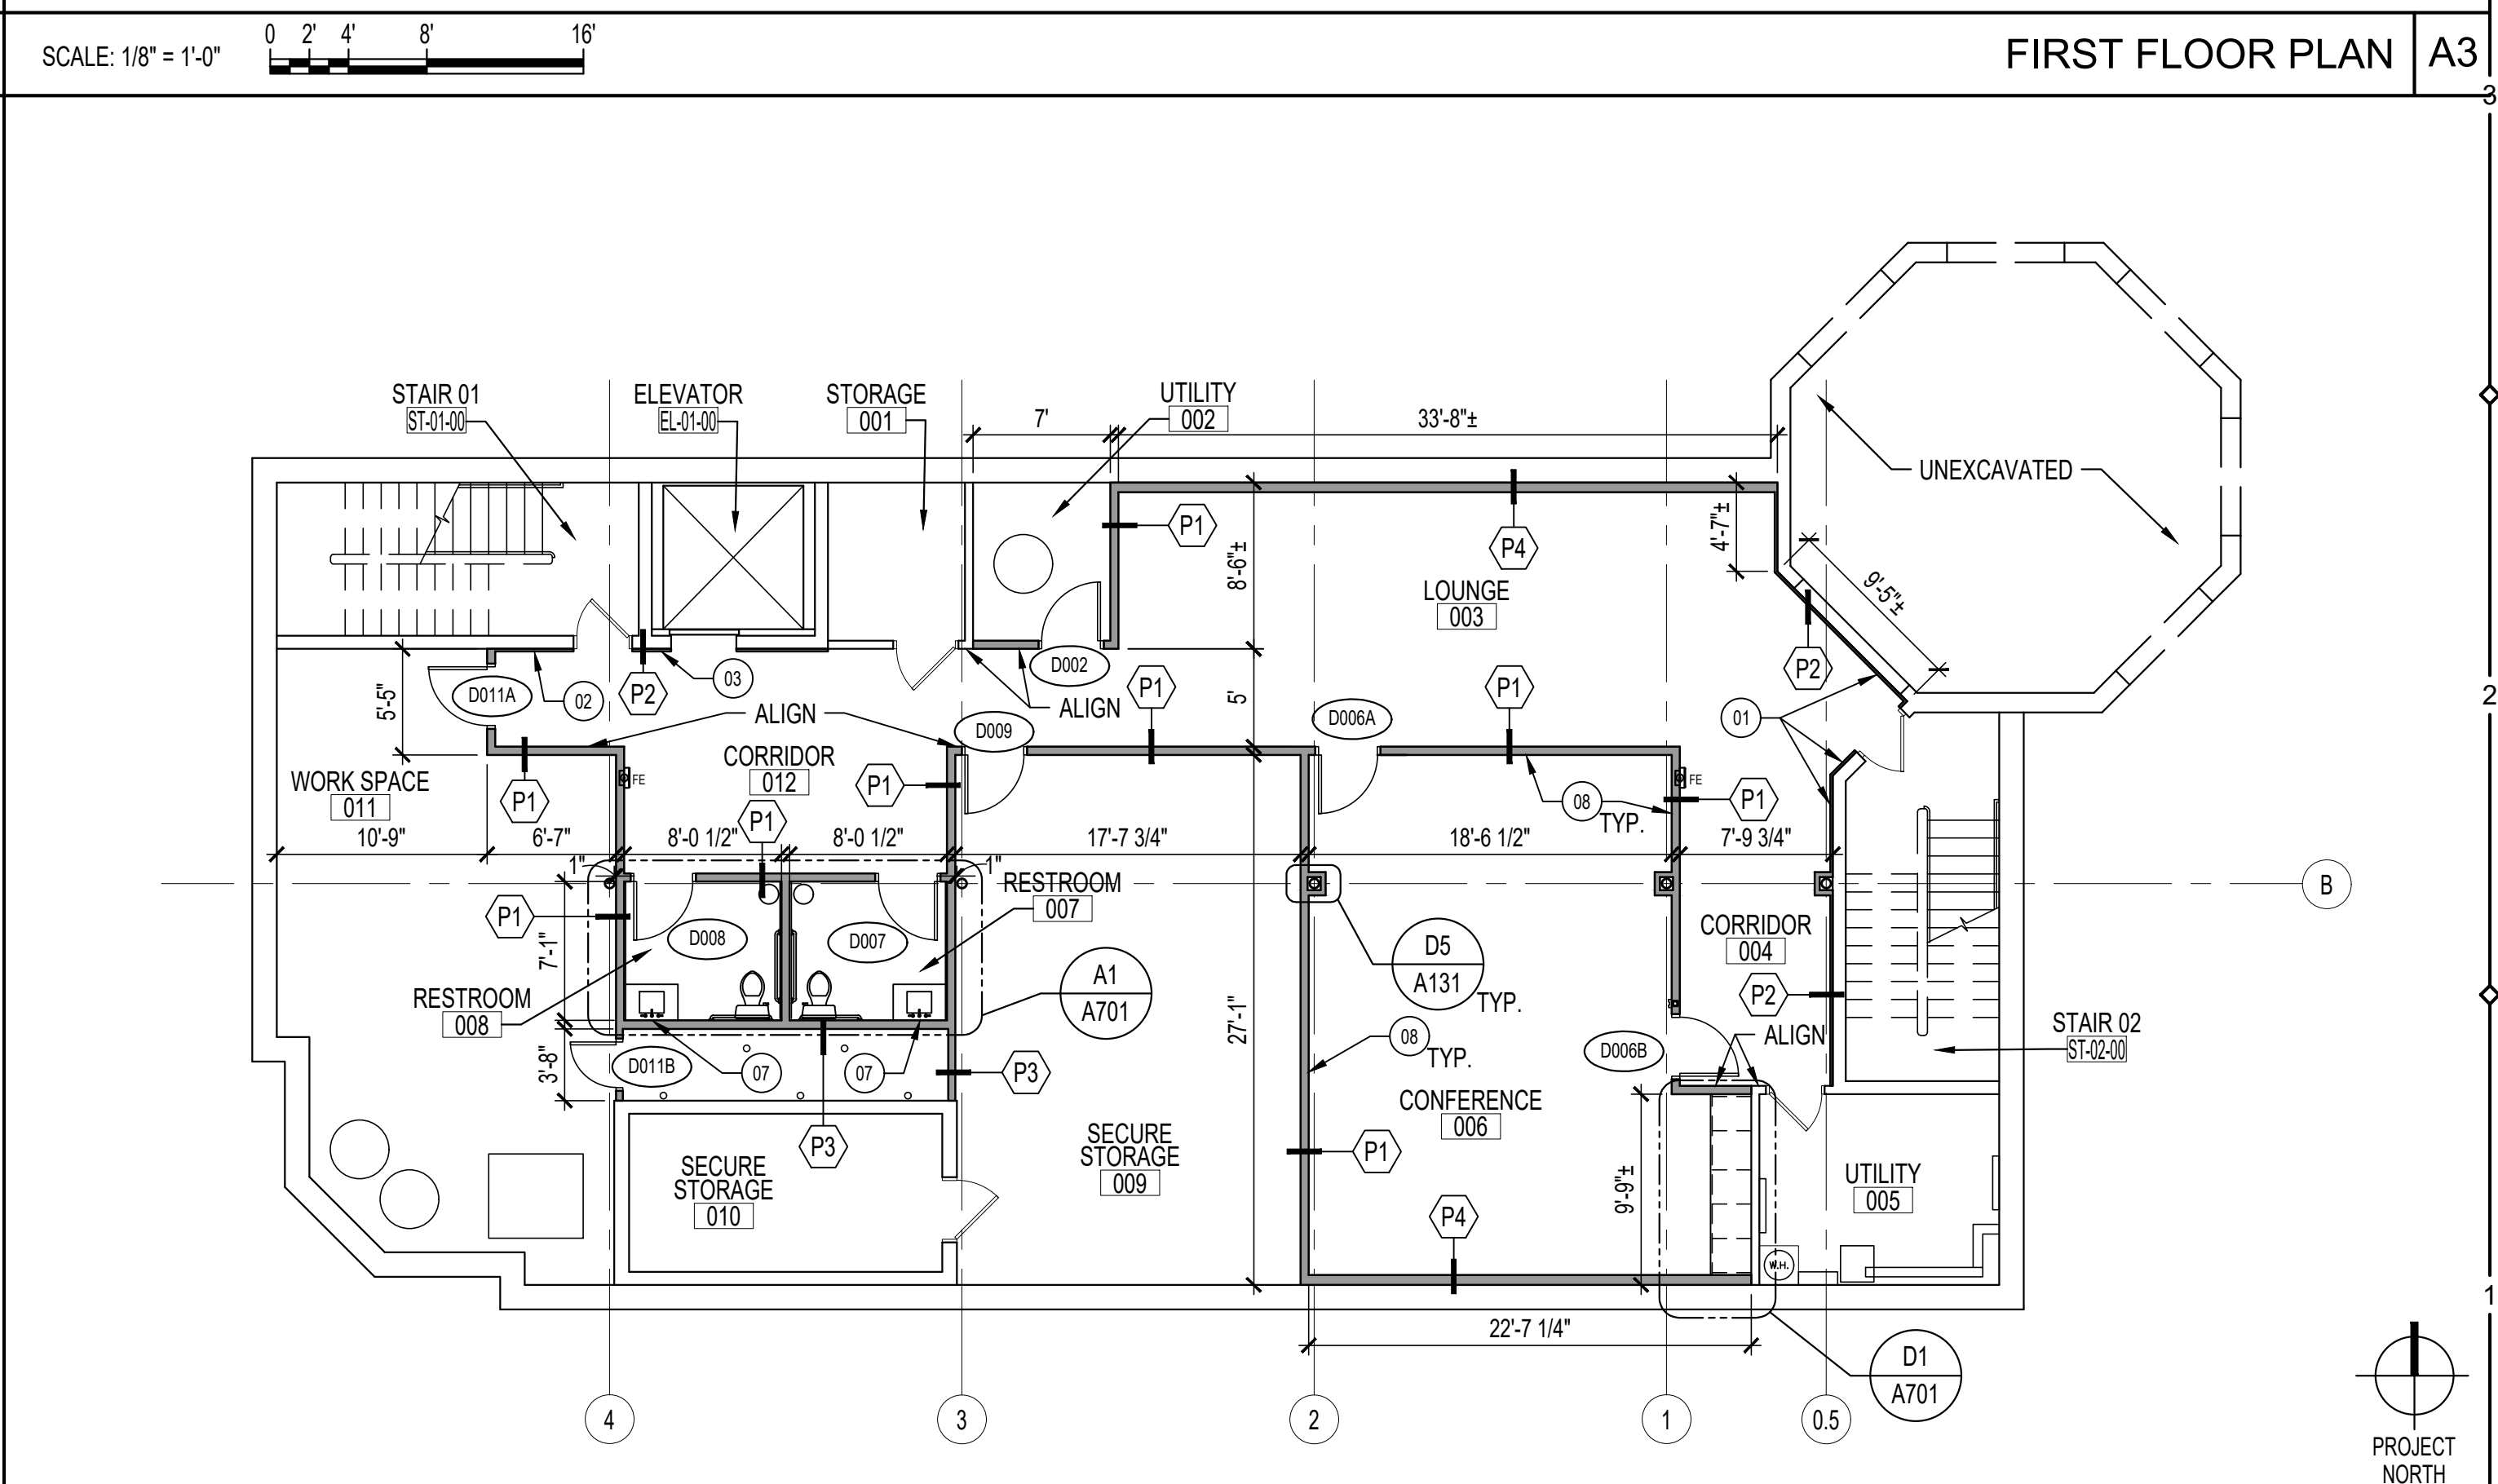

BASEMENT FLOOR PLAN

A1

FARMERS & MERCHANTS BANK

25 WESTMINSTER PIKE
REISTERSTOWN, MARYLAND, 21136

INTERIOR ALTERATION



I CERTIFY THAT THESE DOCUMENTS WERE PREPARED OR APPROVED BY ME AND THAT I AM A DULY LICENSED ARCHITECT UNDER THE LAWS OF THE STATE OF MARYLAND.

LICENSE NO.: 8586

EXP. DATE: 21 MAY 2027

THESE DRAWINGS ARE NOT PERMITTED TO BE COPIED OR REPRODUCED, EITHER WHOLLY OR PARTIALLY, UNLESS WRITTEN PERMISSION IS FIRST OBTAINED FROM SANDERS DESIGNS, P.A.

SANDERS | DESIGNS ARCHITECTS PLANNERS






WWW.SANDERSDESIGNS.COM
MAILBOX@SANDERSDESIGNS.COM
9727 GREENSIDE DRIVE, SUITE 202, COCKEYSVILLE, MARYLAND 21030
T: (410) 560 2624


No.	Date	Revision

Project No.: 26.102
Date: 29 SEPTEMBER 2026
Scale: 1/8" = 1'-0"
Edition:
PERMIT SET

Drawing Name:
RENOVATION FLOOR PLANS
Drawing Number:

A101

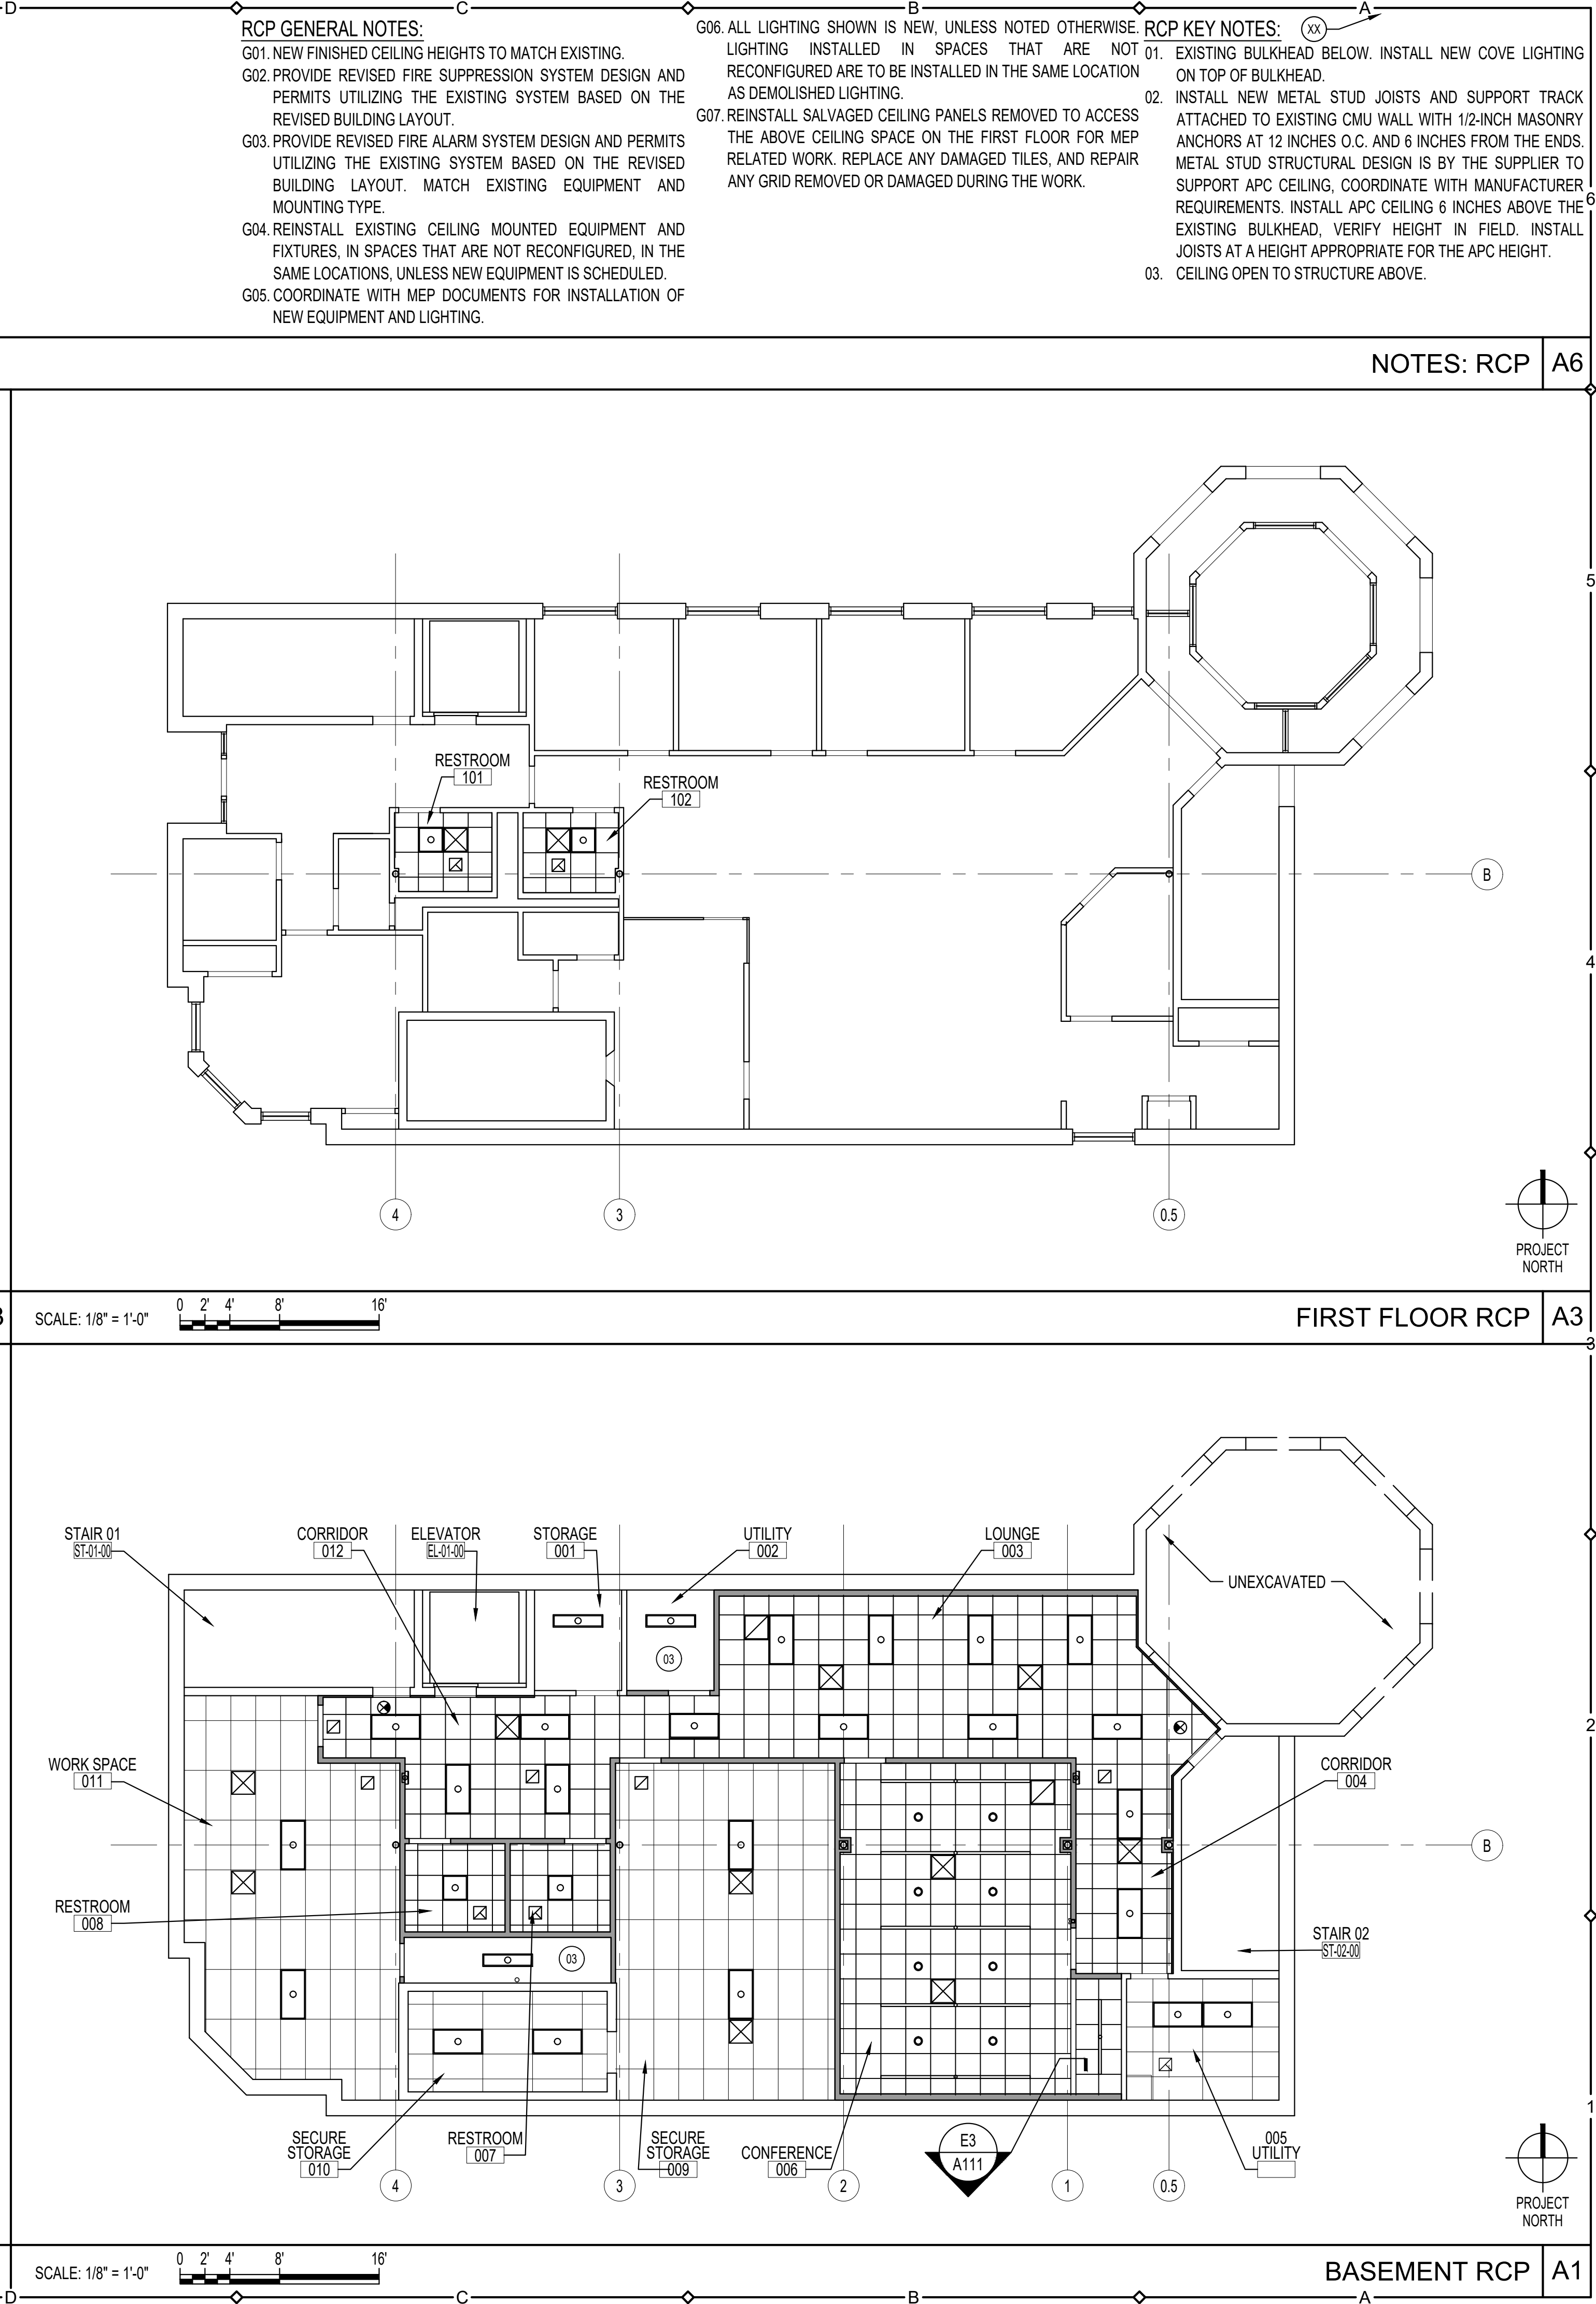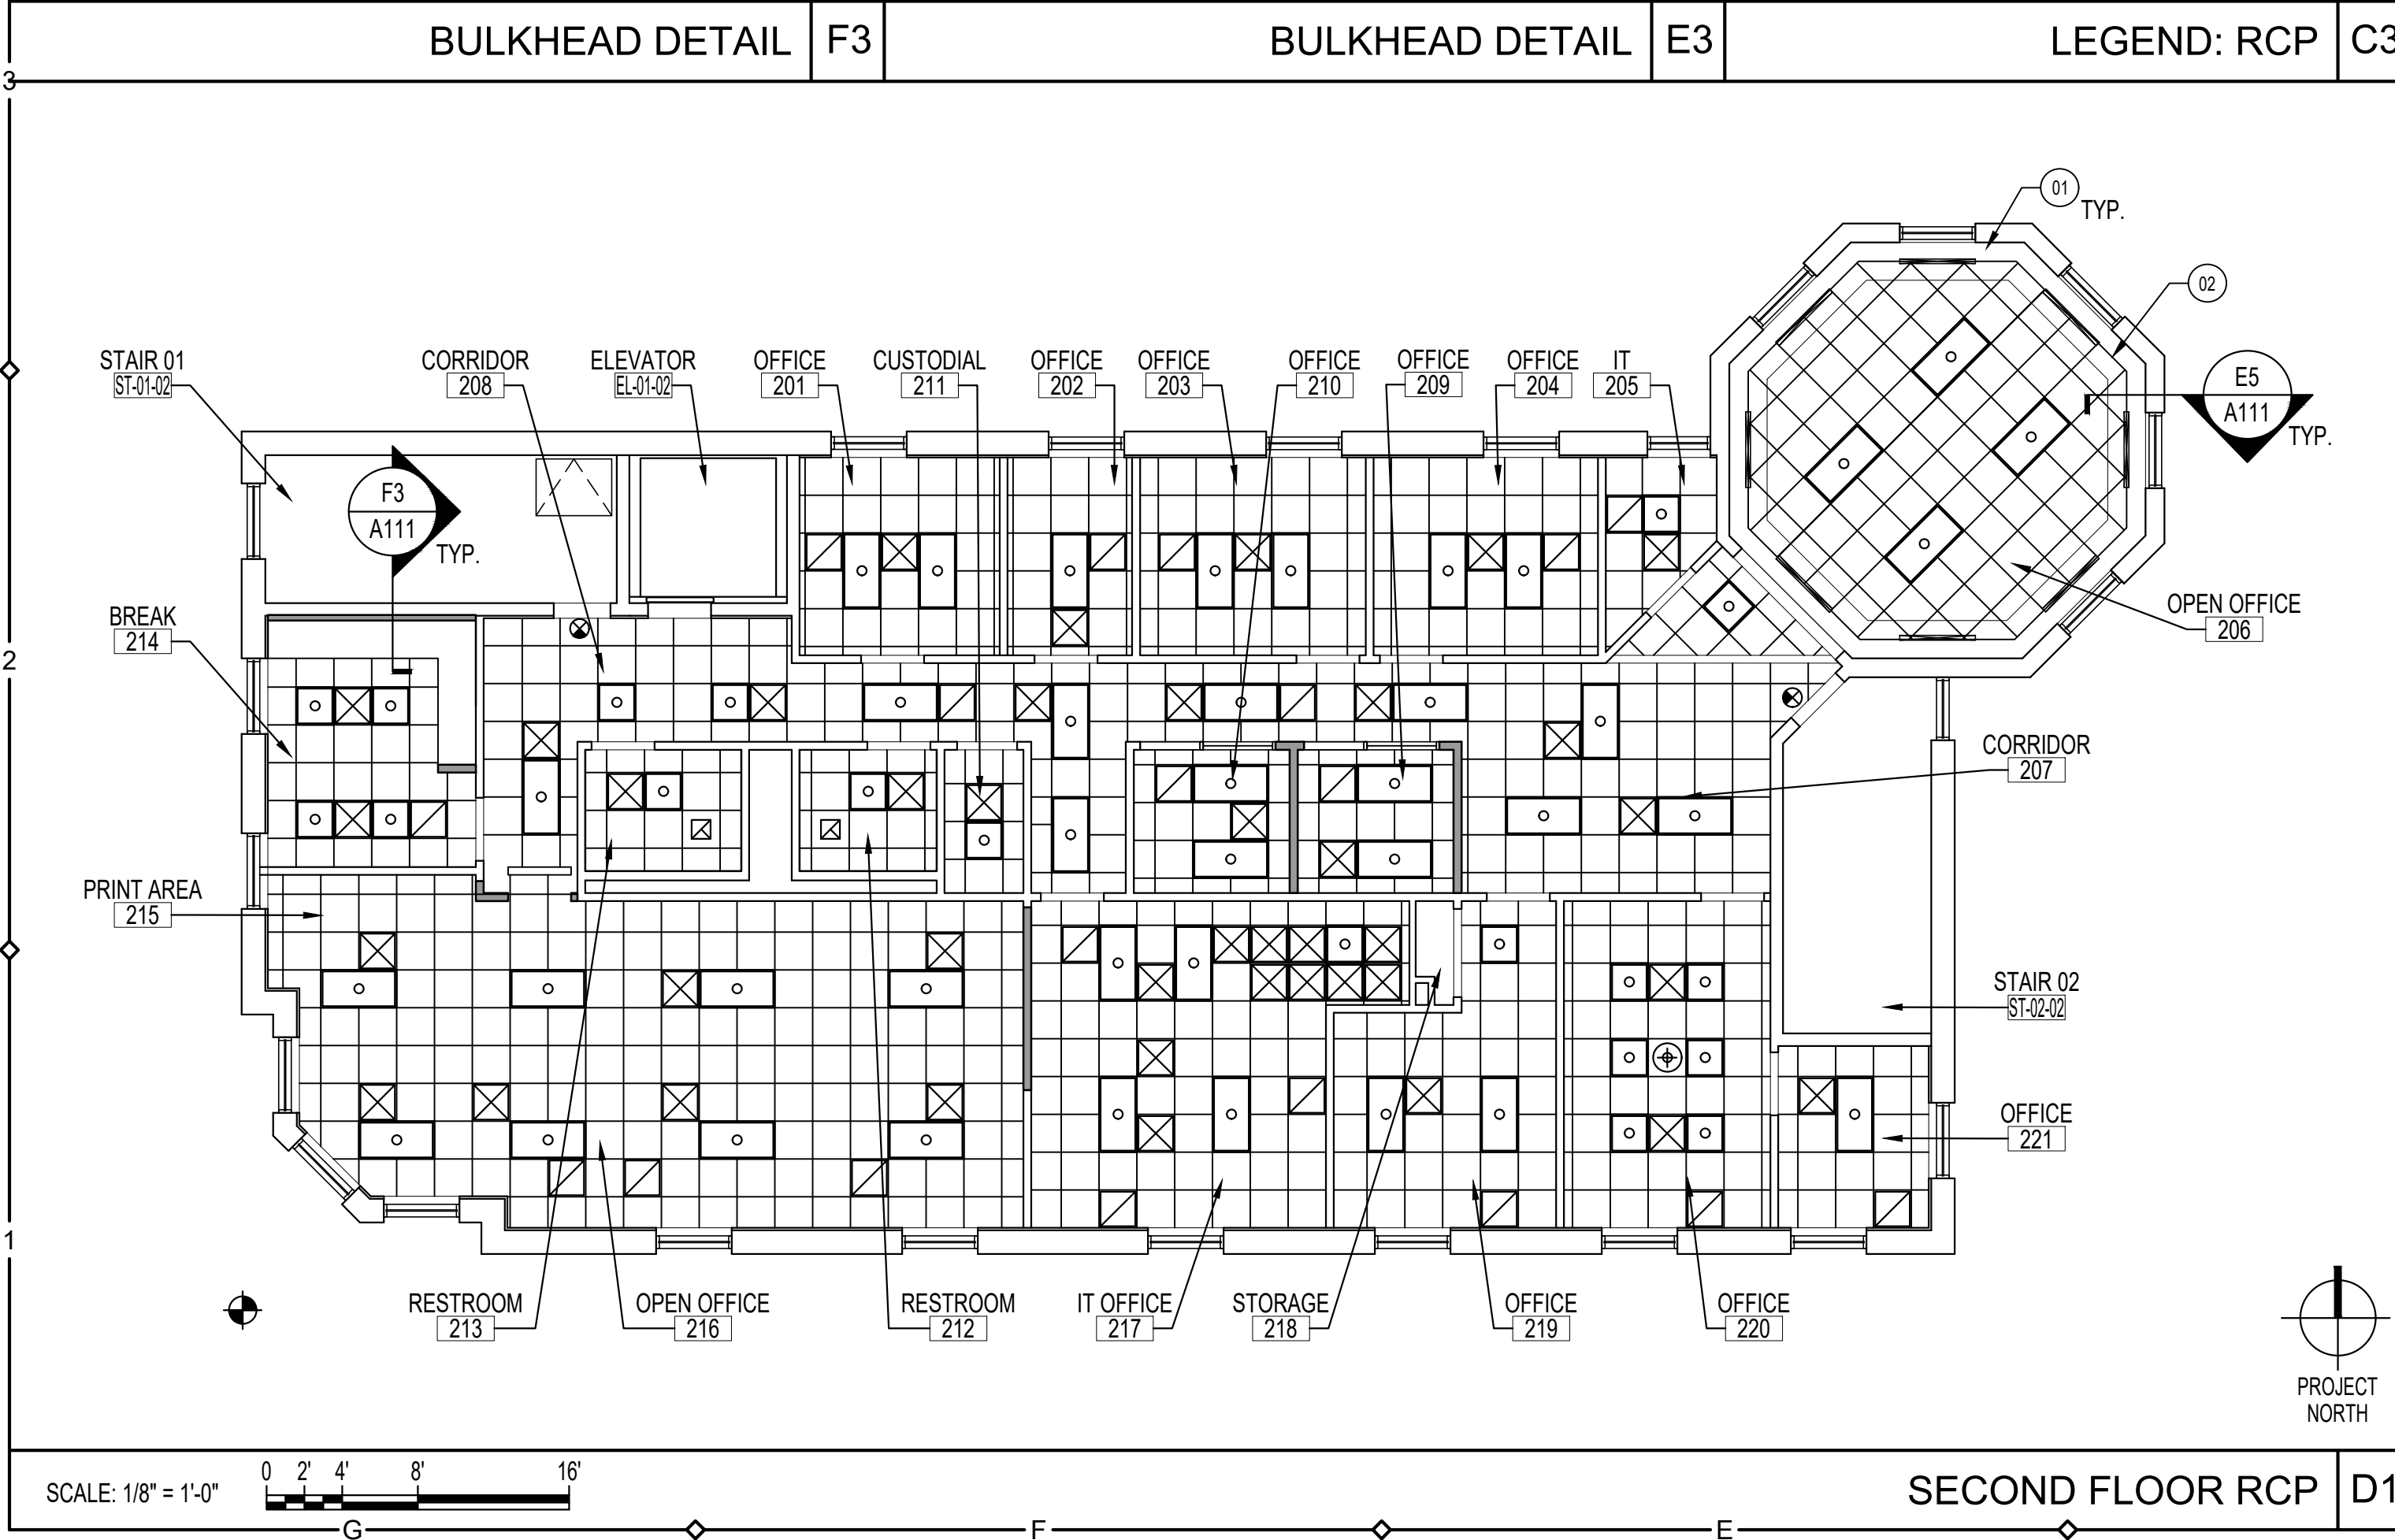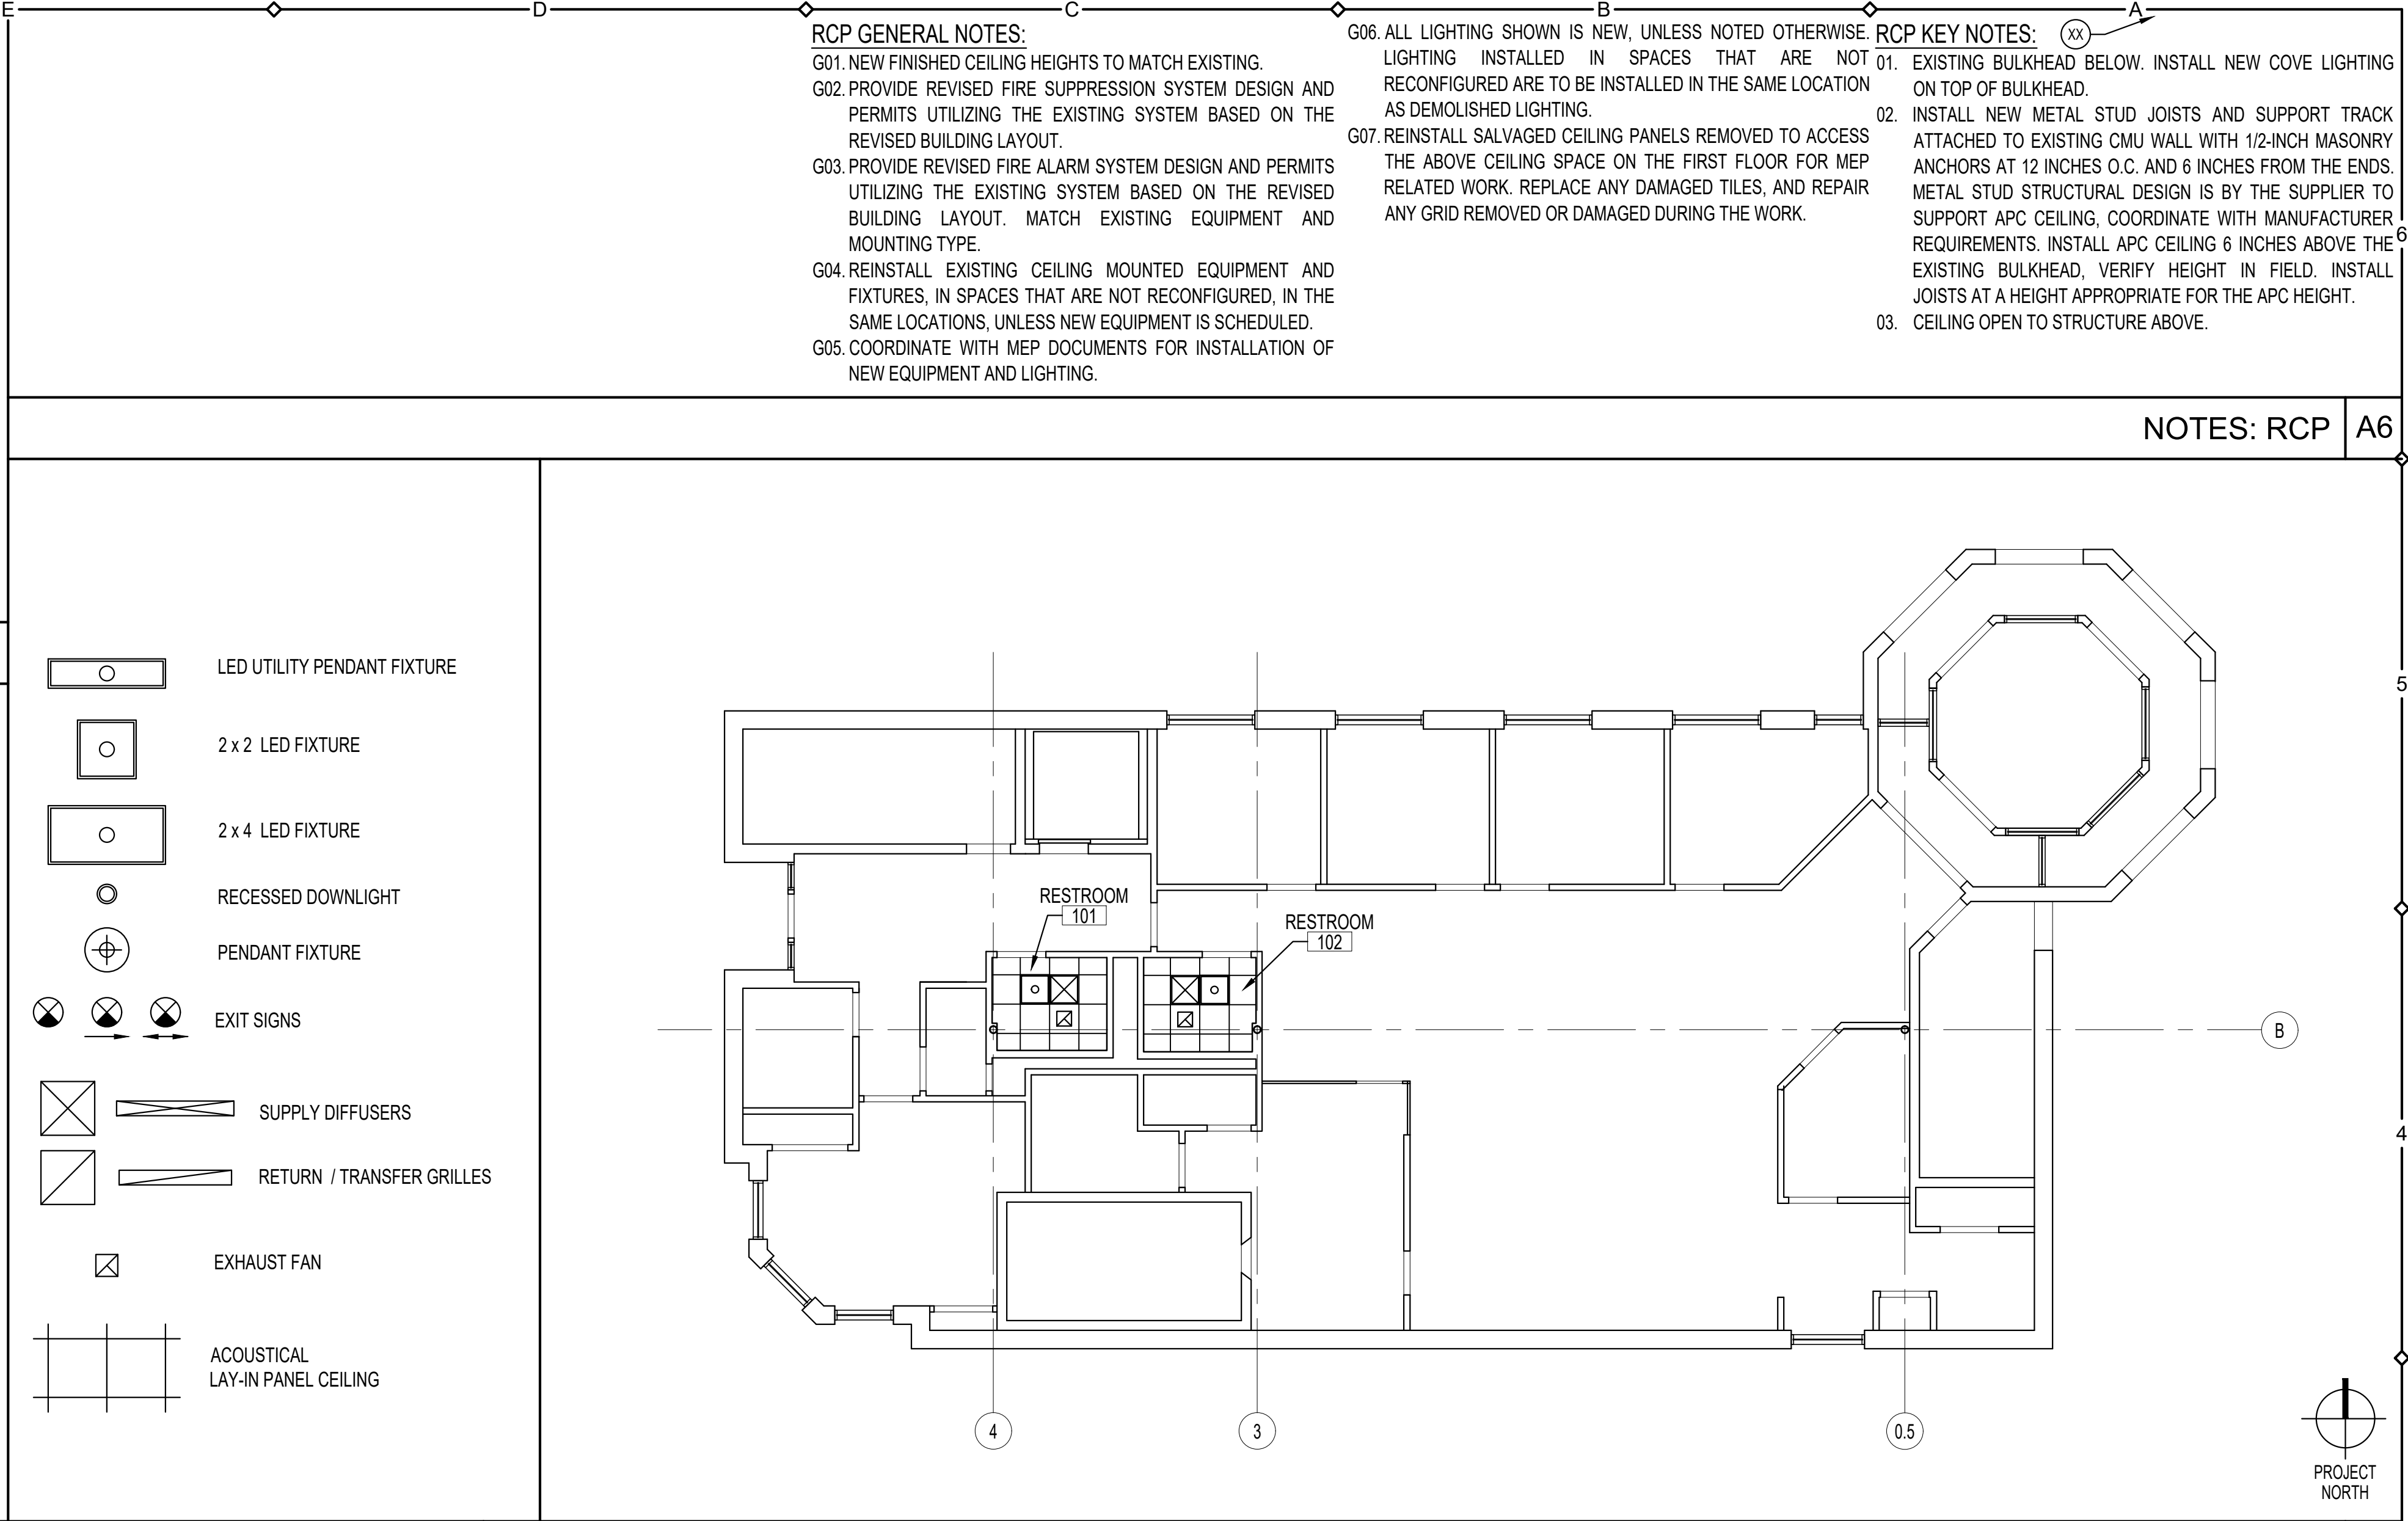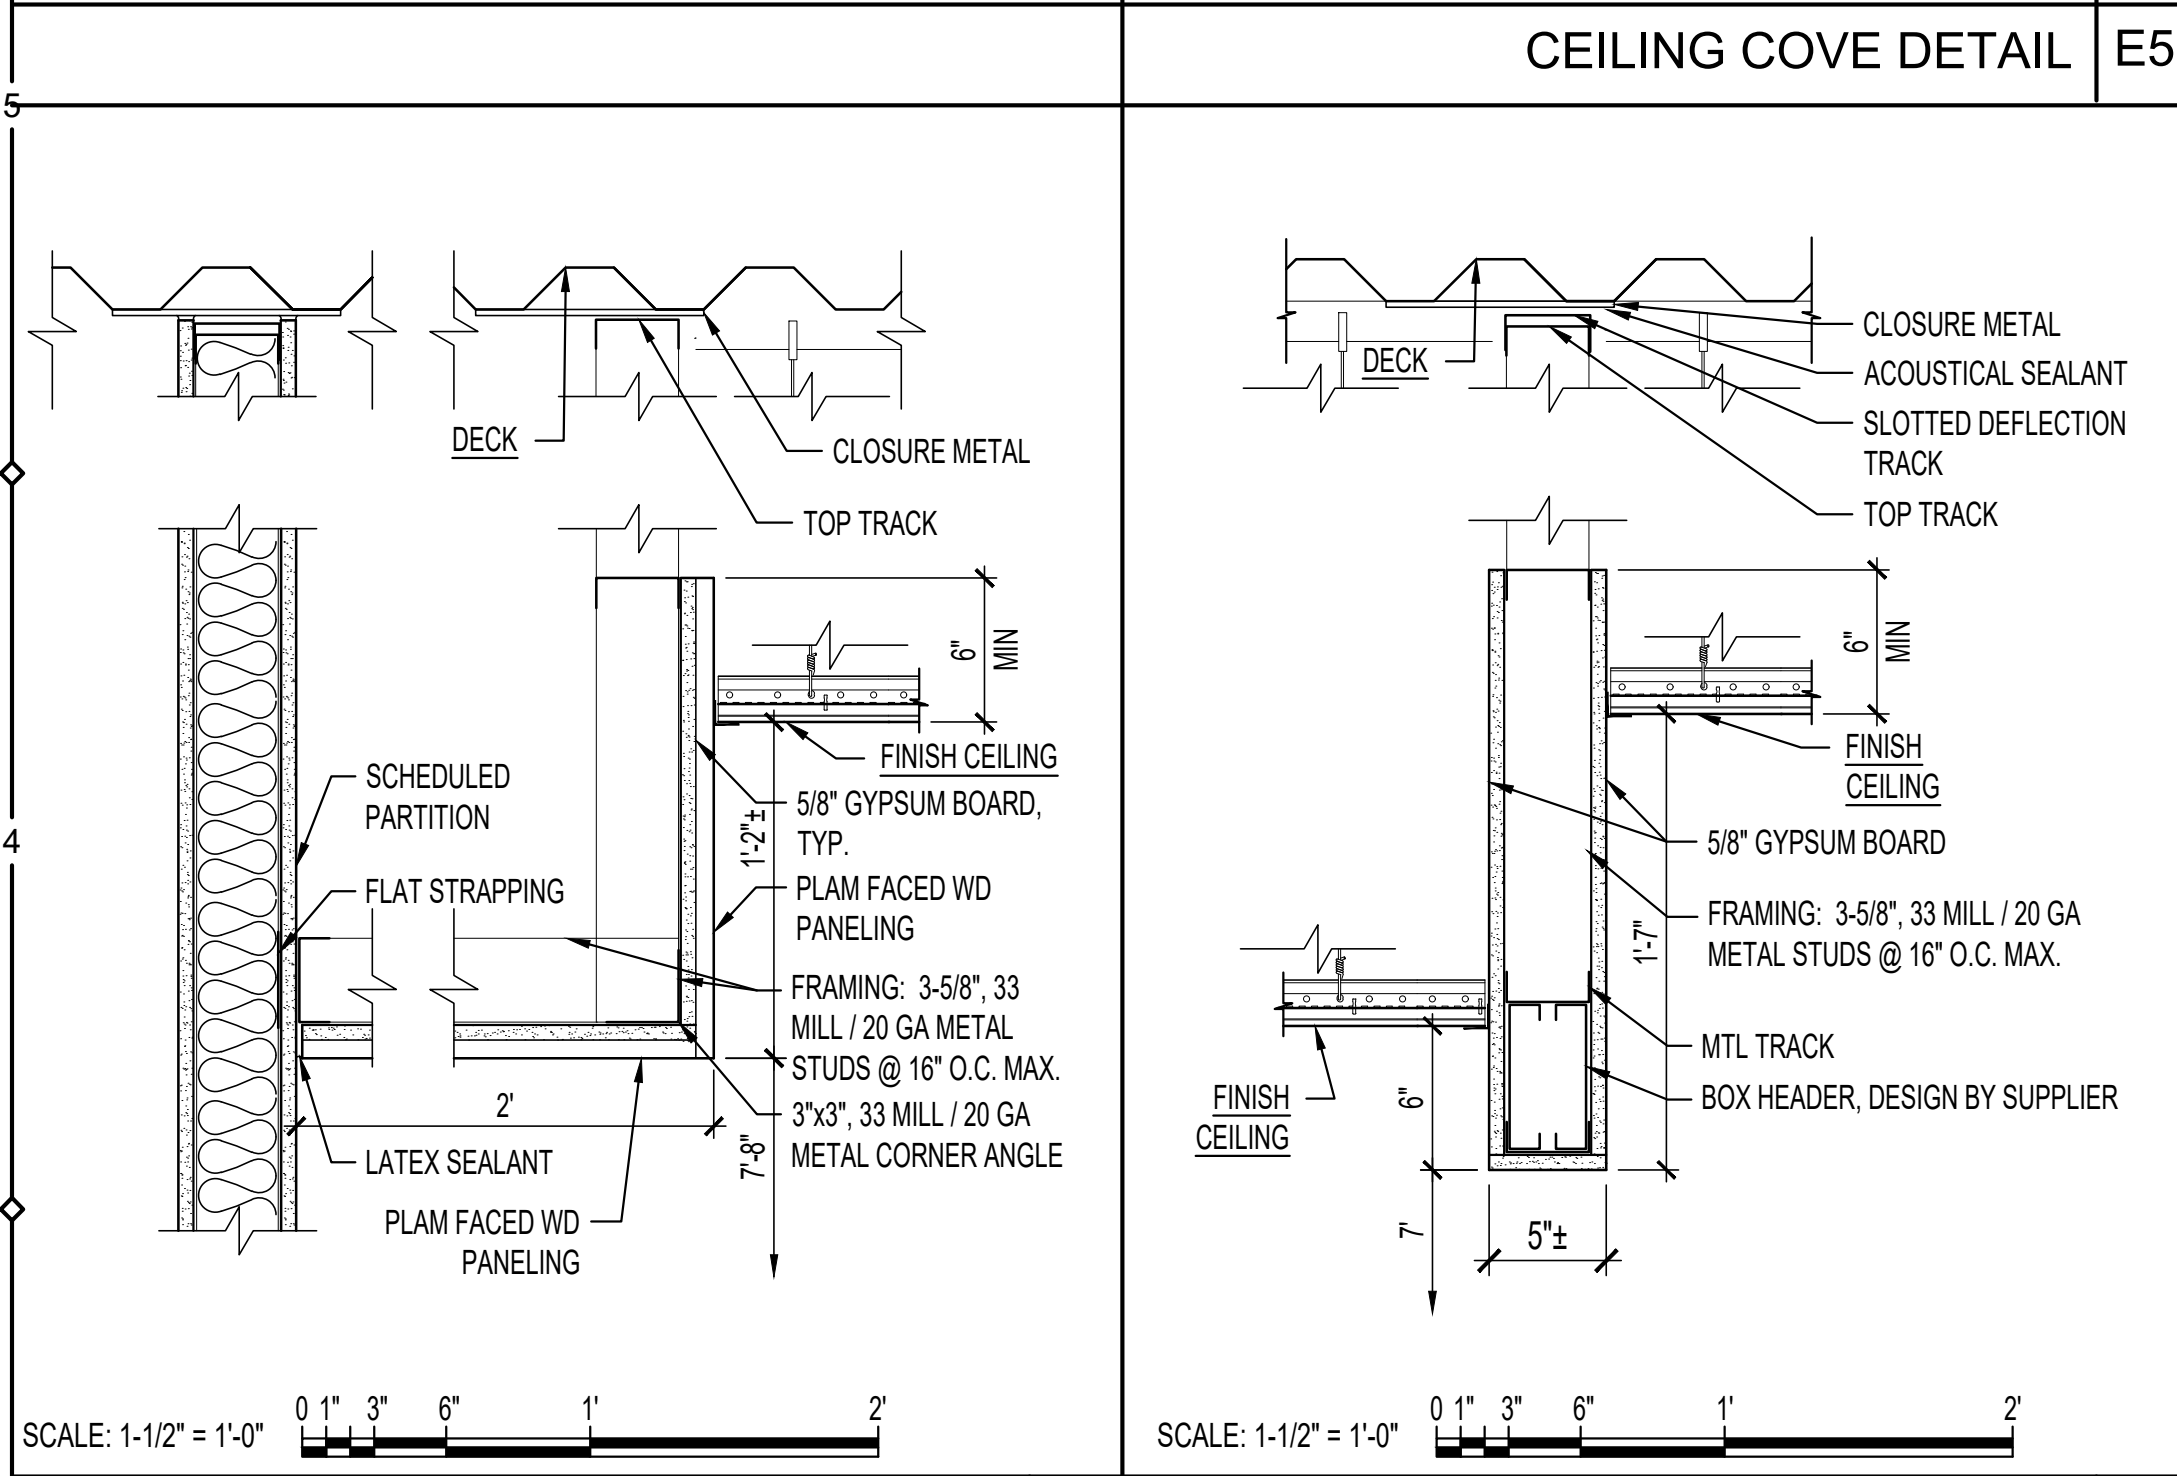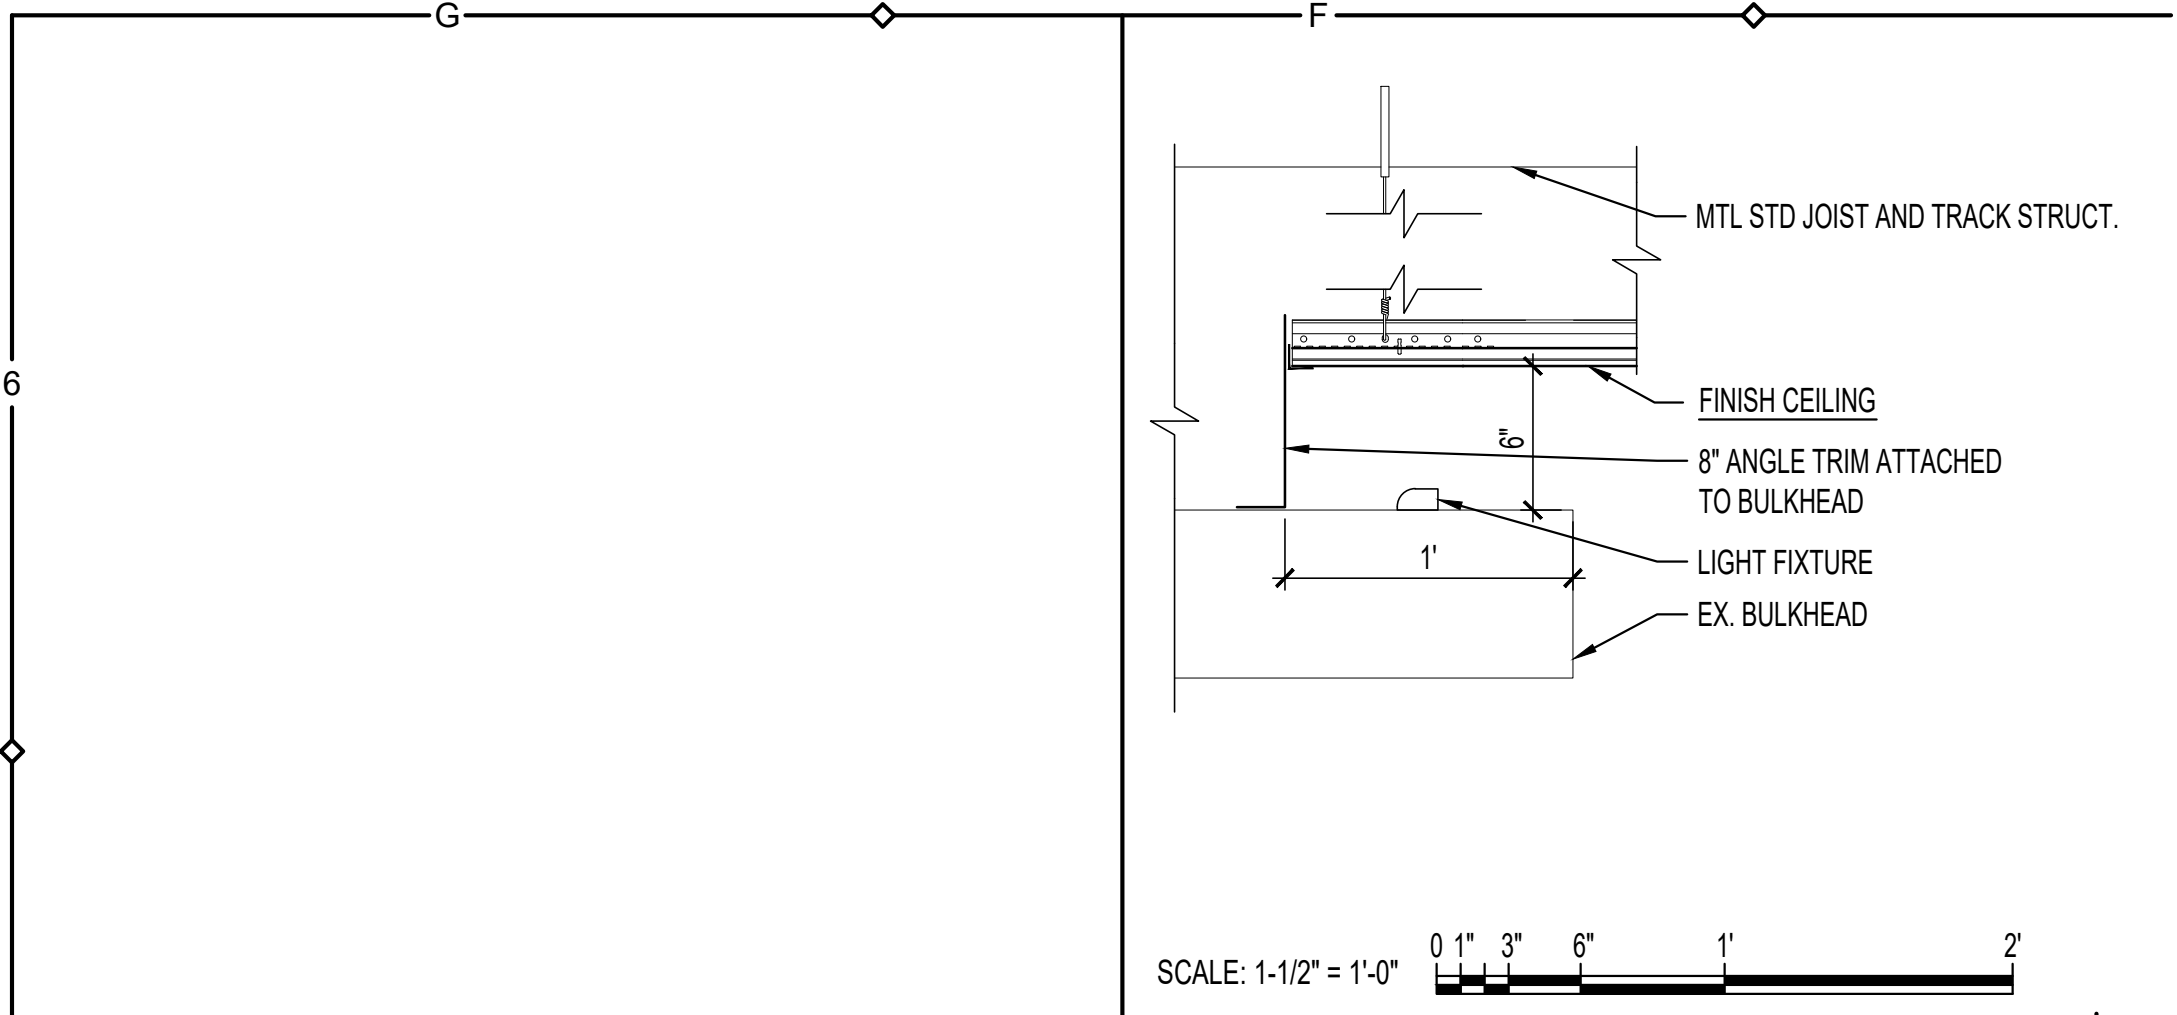

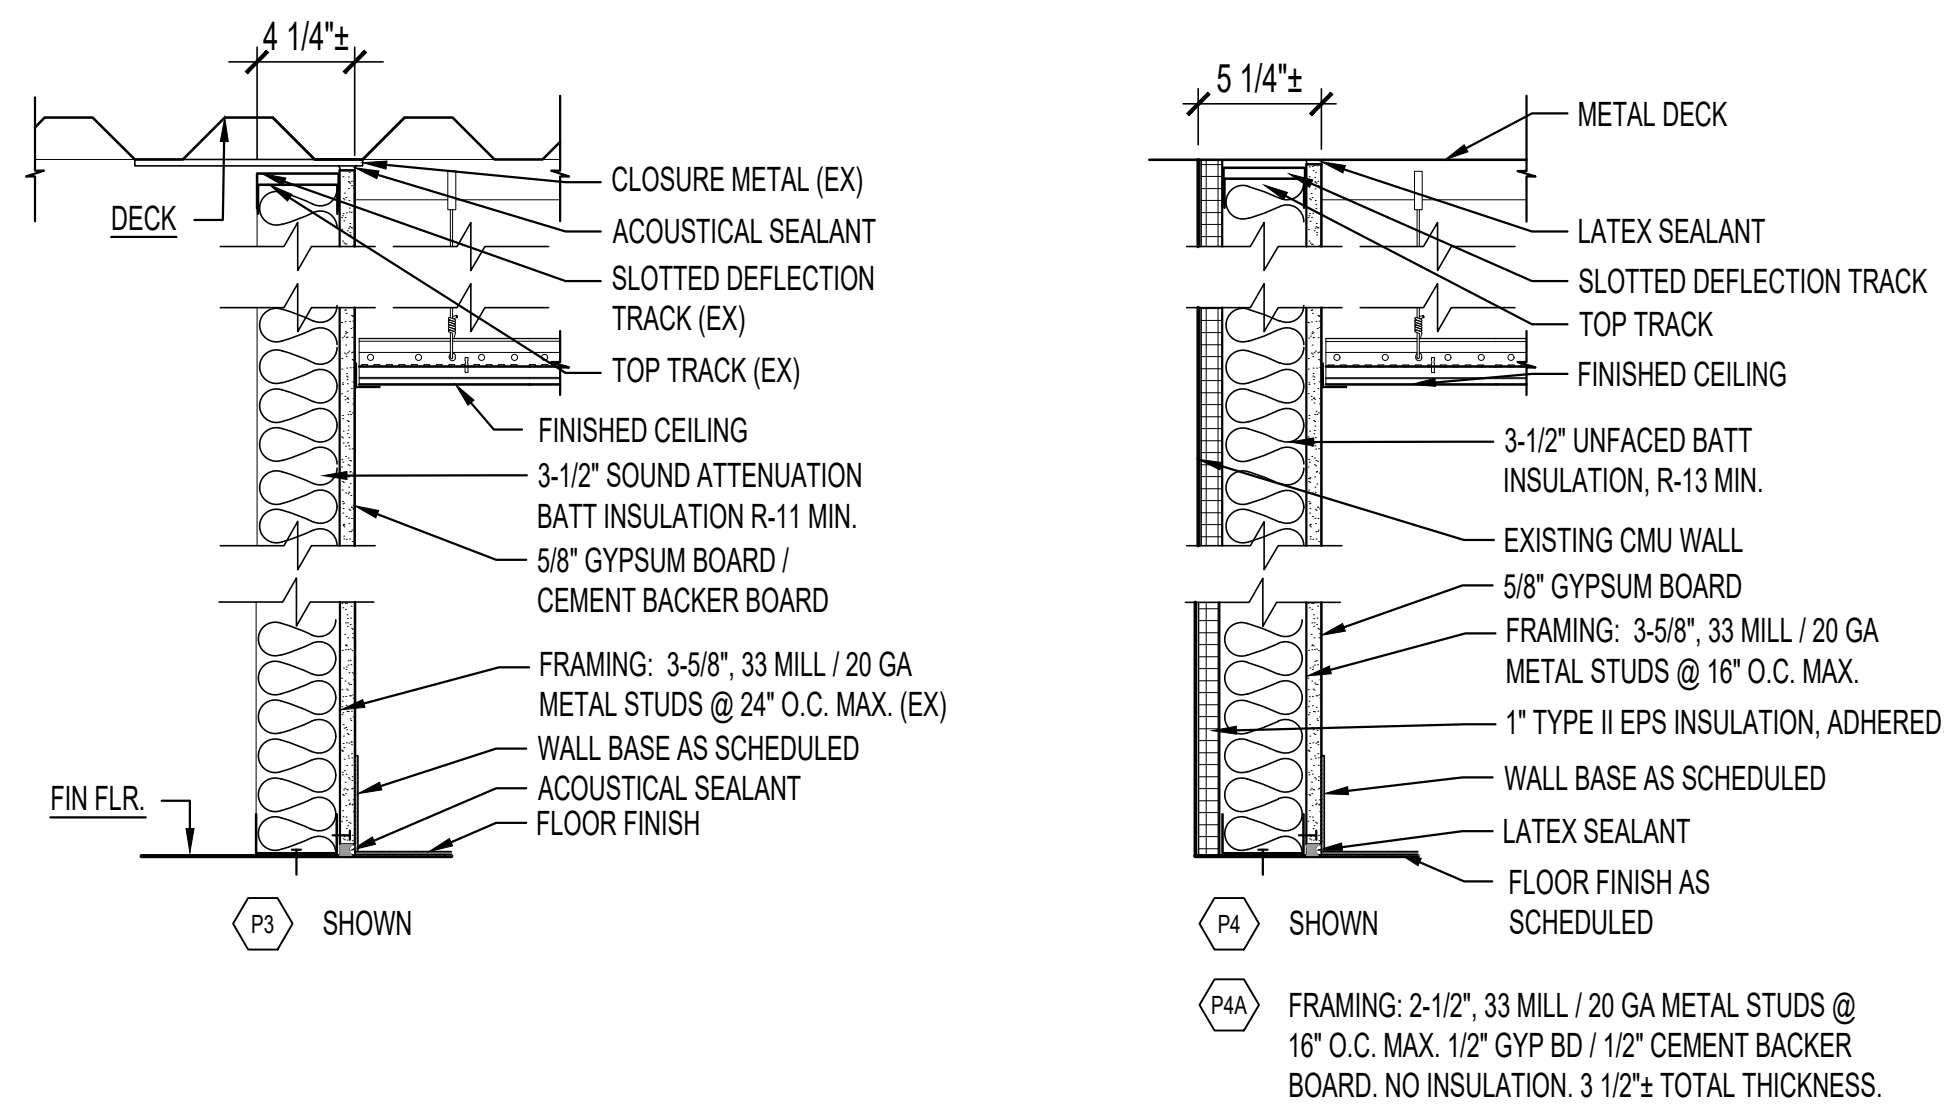

COLUMN BUILD-OUT DETAIL


- G01. PREPARE ALL SUBSTRATES TO RECEIVE FINISHES SPECIFIED. COORDINATE W/ MFRS RECOMMENDATIONS. BEGIN FINISH WORK ONLY WHEN SURFACES AND CONDITIONS ARE IN ACCORDANCE WITH PRODUCT MANUFACTURER'S SPECIFICATIONS.
- G02. HANDLE AND STORE MATERIALS ACCORDING TO PRODUCT MANUFACTURER'S INSTRUCTIONS WITHIN CONFINES OF PROJECT.
- G03. REMOVE WASTE MATERIALS FROM THE PREMISES DAILY.
- G04. PROVIDE TRANSITION STRIPS AT FLOORING MATERIAL CHANGES.
- G05. PROVIDE MOISTURE / MOLD RESISTANT FIBERGLASS FACED GYPSUM BOARD IN ALL WET AREAS. USE TILE BACKING PANES

IN RESTROOM AND BREAK ROOM WALLS WHERE CERAMIC TILE
OR SOLID SURFACING IS THE SCHEDULE FINISH.
COORDINATE W/ FINISH SCHEDULE.
FURNITURE IS PROVIDED AND INSTALLED BY OWNER.
LOCATIONS SHOWN ARE APPROXIMATE AND FOR REFERENCE
ONLY. COORDINATE WITH FINAL OWNER SELECTIONS AND
LAYOUT.
COORDINATE POWER AND DATA LOCATIONS WITH FINAL
FURNITURE LAYOUT.
CERAMIC FLOOR TILE ON CONCRETE SUBFLOOR IS TO BE
INSTALLED ON FLEECE WEBBED POLYETHYLENE WATERPROOF
MEMBRANE, WITH THINSET MODIFIED DRY-SET MORTAR AND
HIGH-PERFORMANCE POLYMER TYPE SANDED GROUT. TURN
MEMBRANE UP 4" AT WALLS.


FURNITURE PLAN KEY NOTES: (X)

01. POWER AND DATA TO BE PROVIDED TO CUBICLES FROM THE CEILING VIA MANUFACTURER SUPPLIED POWER COLUMN. PROVIDE WHIPS FOR INSTALLATION AND CONNECTION AS NECESSARY.
02. POWER AND DATA TO BE PROVIDED TO CUBICLES IN THE ADJACENT WALL. PROVIDE WHIPS FOR INSTALLATION AND CONNECTION AS NECESSARY.
03. APPROXIMATE LOCATION OF SERVER.
04. APPROXIMATE LOCATION OF CURRENT DATA CABLING ABOVE CEILING. RELOCATE DATA IN THE CEILING ON THE SOUTH WALL TO ABOVE THE CEILING AT THE SERVER.


NOTES: PLAN | A6

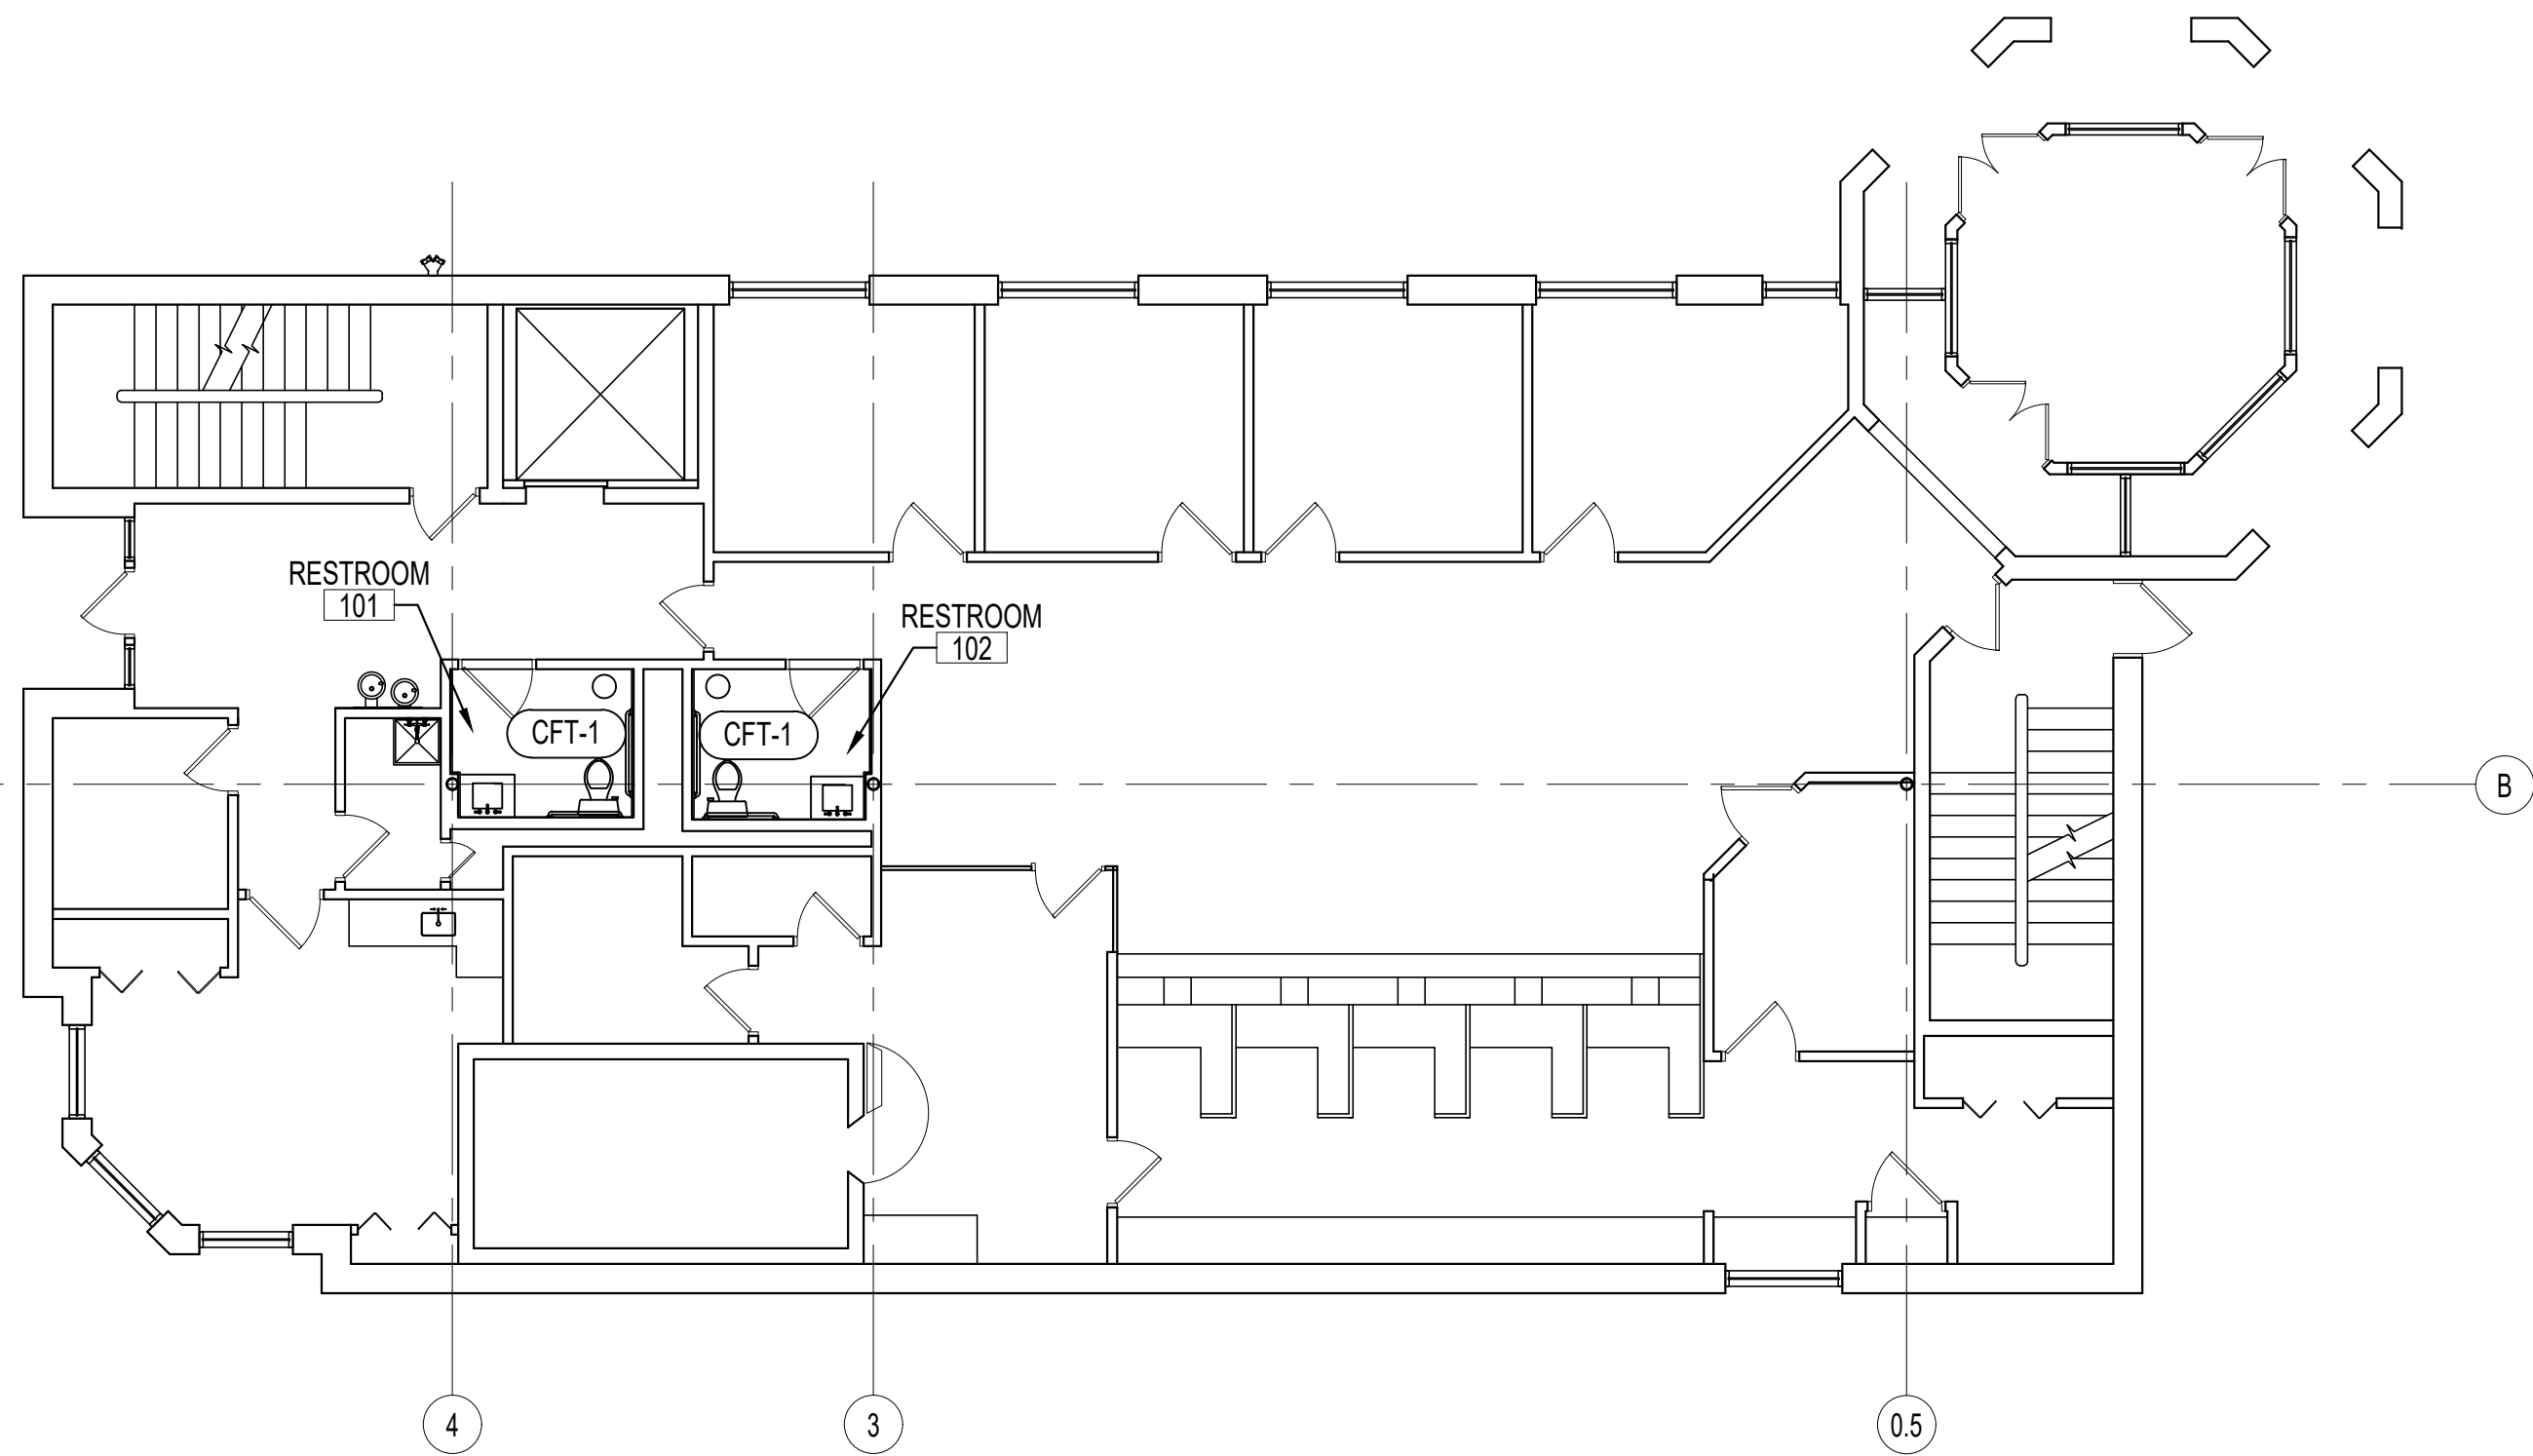


FIRST FLOOR PLAN | A3

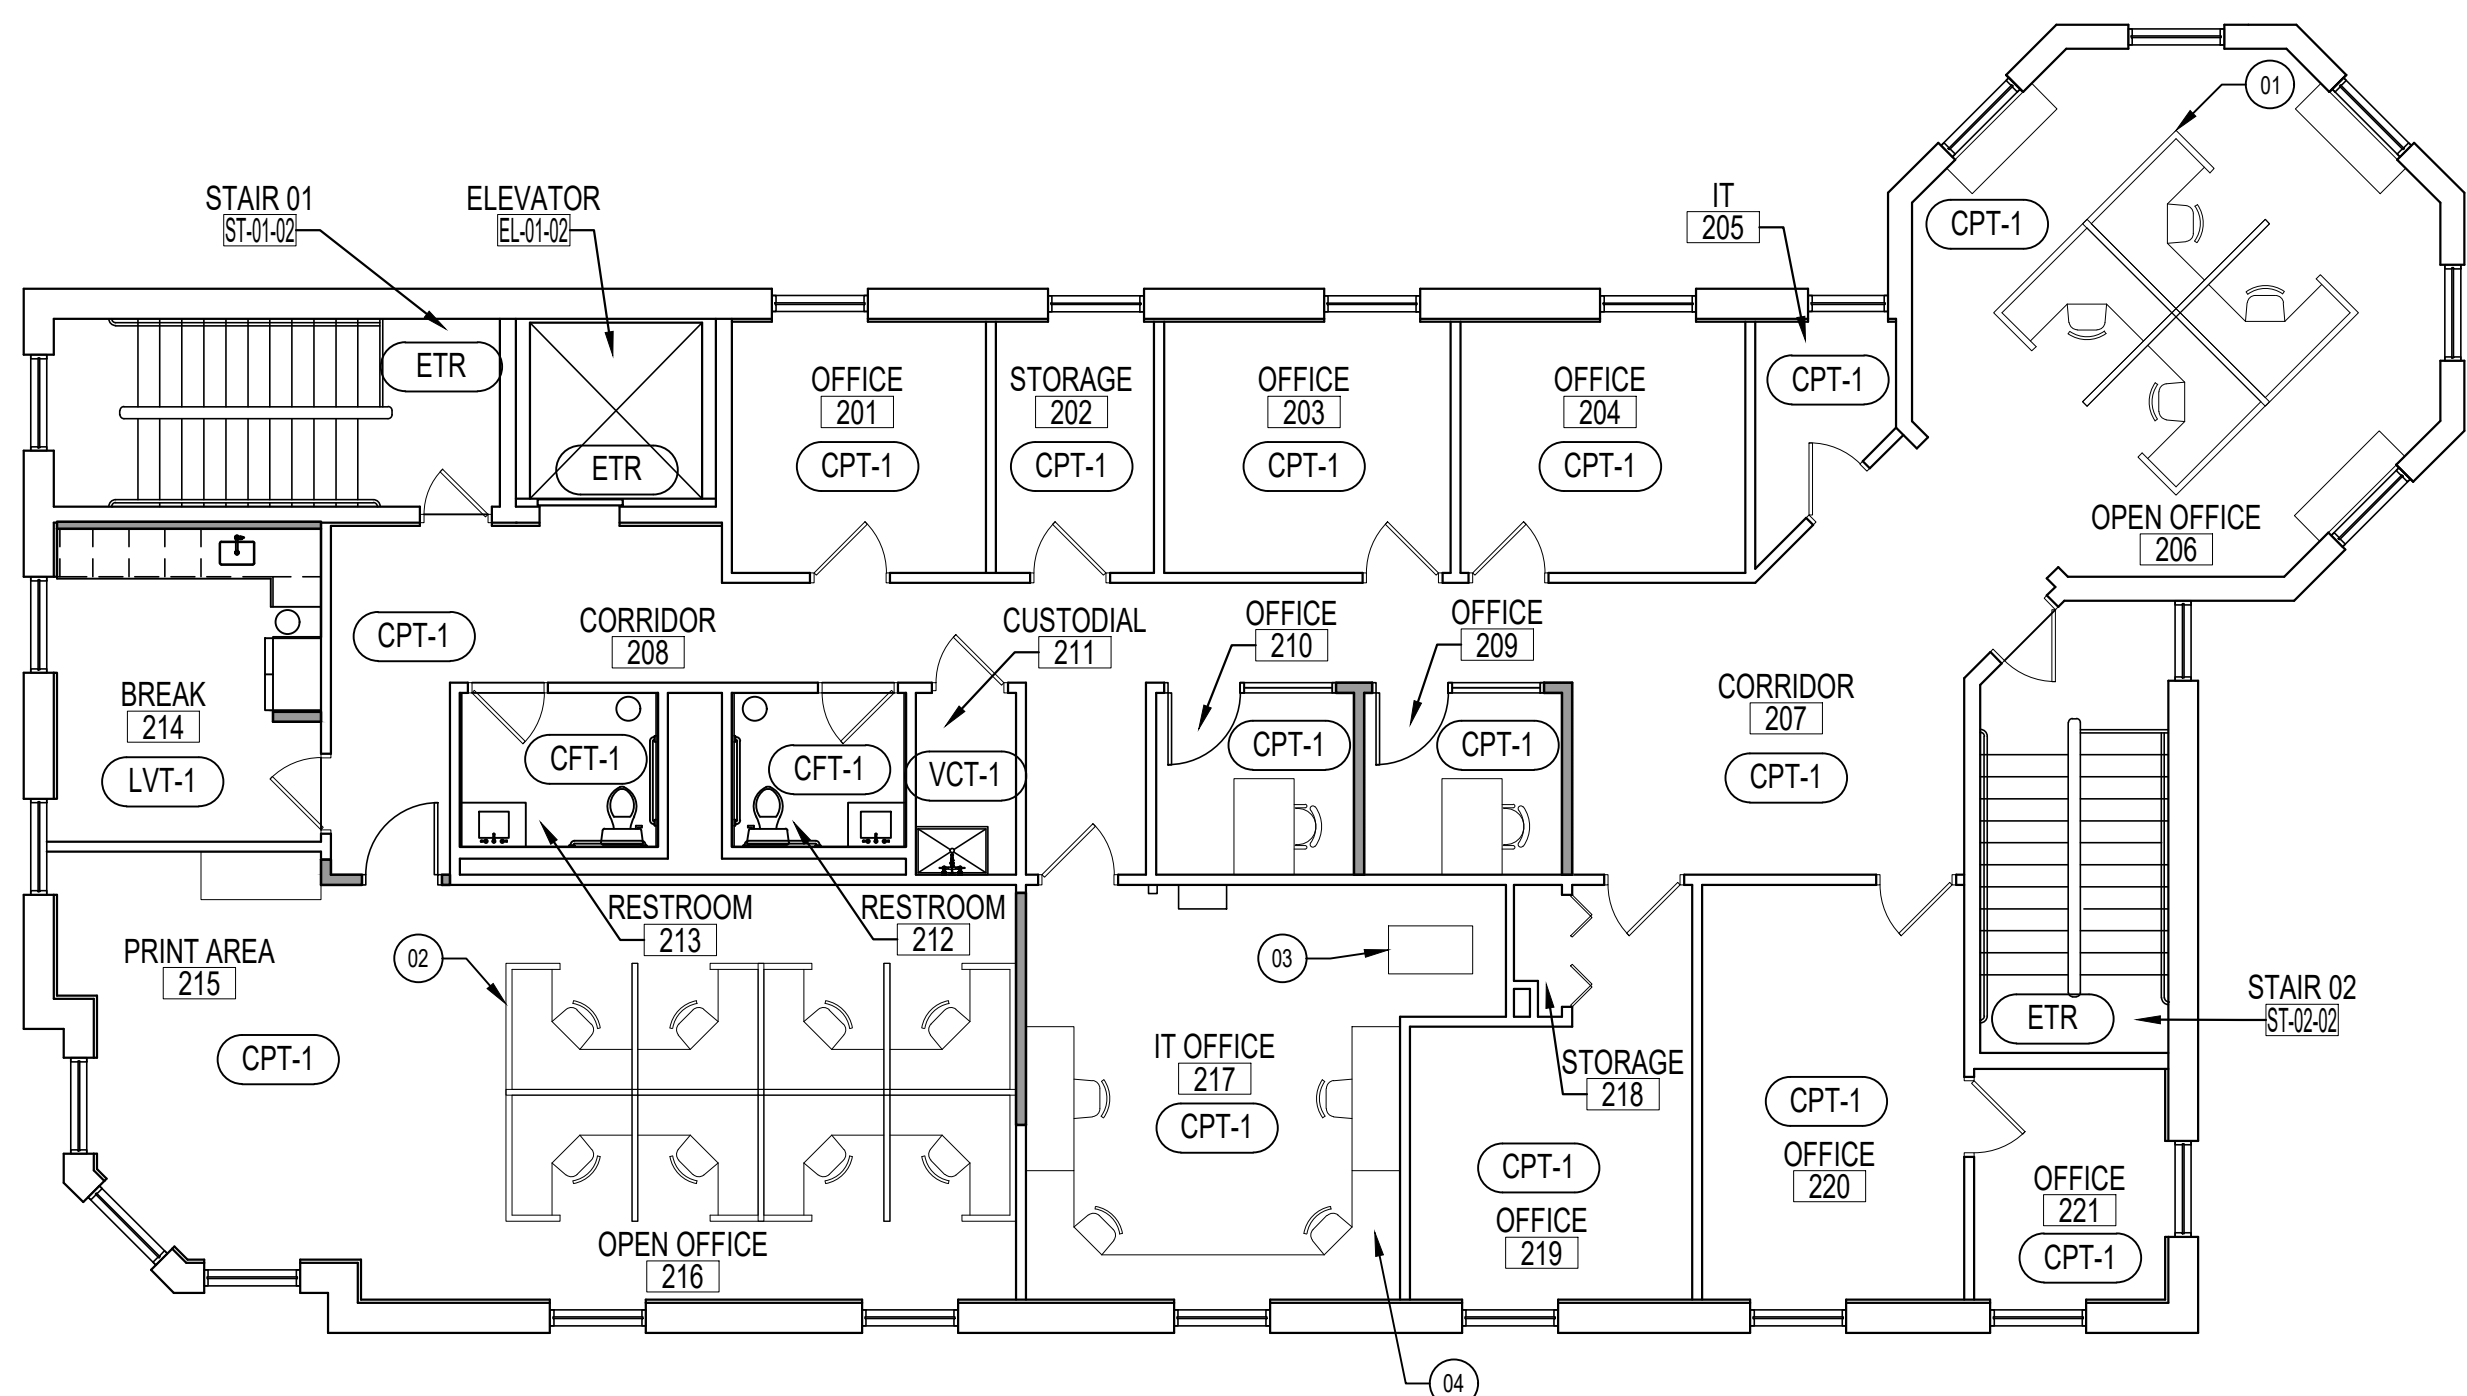

SECOND FLOOR PLAN

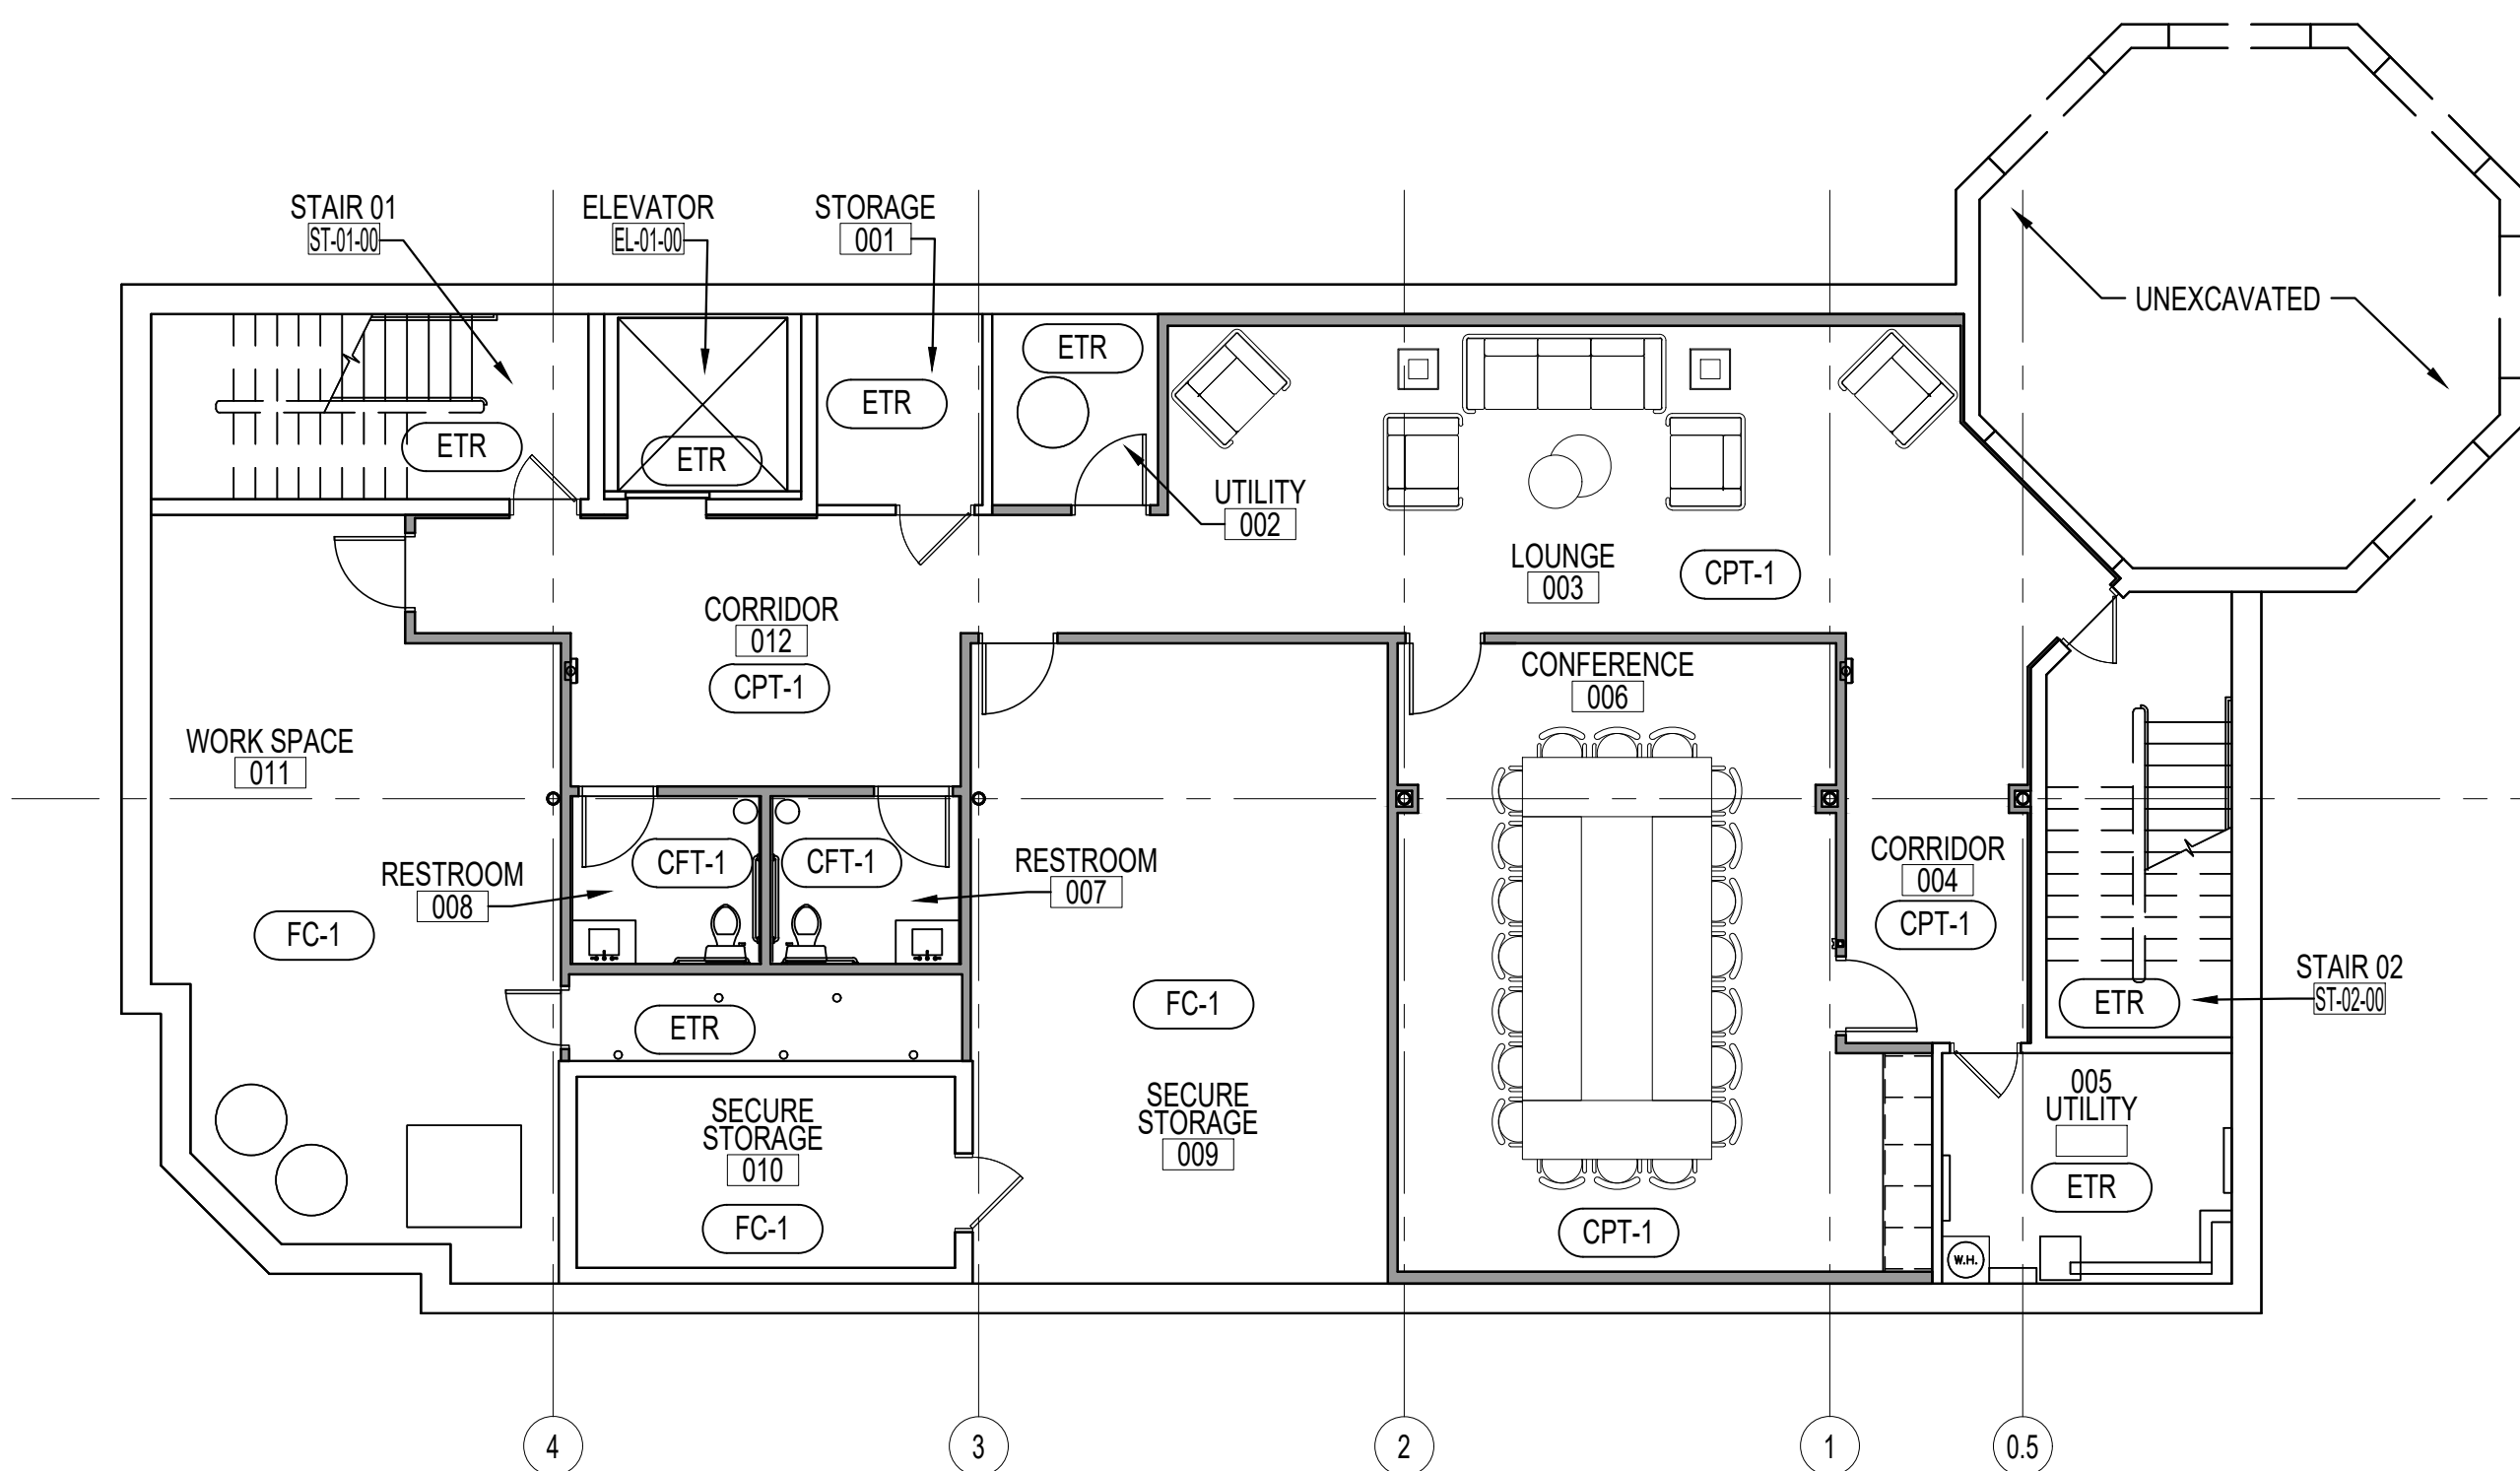

BASEMENT FLOOR PLAN | A1

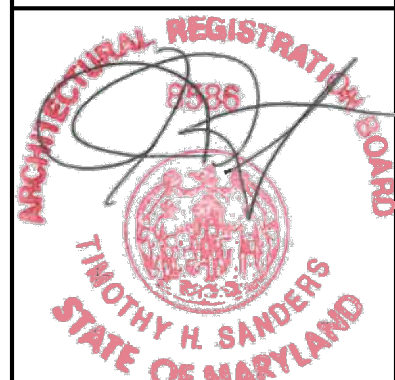

I CERTIFY THAT THESE
DOCUMENTS WERE PREPARED
OR APPROVED BY ME AND THAT
I AM A DULY LICENSED
ARCHITECT
UNDER THE LAWS OF THE STATE
OF MARYLAND.

LICENSE NO.: 8586

EXP. DATE: 21 MAY 2027

THESE DRAWINGS ARE NOT
PERMITTED TO BE COPIED OR
REPRODUCED, EITHER WHOLLY
OR PARTIALLY, UNLESS
WRITTEN PERMISSION IS FIRST
OBTAINED FROM SANDERS
DESIGNS, P.A.

[illegible]

Project No.:	26.102
--------------	--------

Date: 29 SEPTEMBER 2026

Scale: $1/8" = 1'-0"$

Edition:

PERMIT SET

Drawing Name:

FURN FINISH &

EQUIP. PLANS

A131

</

DOOR SCHEDULE | D5

D5

[illegible]

DOOR DETAILS | D3

D3

NUMBER	WINDOW		FRAME		DETAILS			FIRE RATING	REMARKS	NUMBER
	NOMINAL SIZE (W x H)	GLAZING	MATERIAL	FINISH	HEAD	JAMB	SILL			
W1	4'-0" x 3'-10"	GL-1	HM-1	PT-4	WH-1	WJ-1	WS-1	---	SEE DOOR SCHEDULE AND FRAME ELEVATION FOR ADDITIONAL INFORMATION	W1
KEY TO WINDOW SCHEDULE:										
GLAZING: GL-1: 1/4" ANNEALED CLEAR FLOAT GLASS, TEMPERED					FRAME: HM-1: SDI LEVEL 1, 18GA WELDED HOLLOW METAL					

WINDOW SCHEDULE

D2

WINDOW HEAD WH-1

- AS SCHEDULED
- SOUND ATTENUATING BATT
- INSULATION
- GYPSUM BOARD
- MTL TRACK
- BOX HEADER
- LATEX SEALANT, BOTH SIDES
- H.M. FRAME; PACK SOLID W/ MINERAL WOOL
- ANCHOR CLIP
- GLAZING BEAD
- EXPANDED TAPE, BOTH SIDES
- GLAZING AS SCHEDULED
- 5/8"
- 1/2"
- 2"

WINDOW JAMB WJ-1

- GLAZING AS SCHEDULED
- H.M. FRAME; PACK SOLID W/ MINERAL WOOL
- ANCHOR CLIP
- LATEX SEALANT, TYP BOTH SIDES
- GYPSUM BOARD
- AS SCHEDULED
- SOUND ATTENUATING BATT
- INSULATION
- DOUBLE KING STUDS AND CLOSURE TRACK
- GLAZING BEAD
- EXPANDED TAPE, BOTH SIDES

WINDOW SILL WS-1

- GLAZING AS SCHEDULED
- EXPANDED TAPE, BOTH SIDES
- GLAZING BEAD
- H.M. FRAME; PACK SOLID W/ MINERAL WOOL
- LATEX SEALANT, TYP. BOTH SIDES
- SILL TRACK
- CRIPPLE STUD
- GYPSUM BOARD
- SOUND ATTENUATING BATT
- INSULATION
- AS SCHEDULED
- 5/8"
- 2"

SCALE: 1-1/2" = 1'-0"

0 1" 3" 6" 1' 2'

WINDOW DETAILS | D1

D1

ROOM		FLOOR	BASE	WALLS				CASEWORK		CEILING	HEIGHT	REMARKS	ROOM NUMBER
NO.	NAME			N	S	E	W	CAB	TOP				
BASEMENT													
001	STORAGE	ETR	ETR	PT-1	PT-1	PT-1	PT-1	---	---	ETR	ETR	1,6	001
002	UTILITY	ETR	VWB-1	PT-1	PT-1	PT-1	PT-1	---	---	OPEN	---	1,6	002
003	LOUNGE	CPT-1	WB-1	PT-1	PT-1	PT-1	PT-1	---	---	APC-1	8'-7"±	2	003
004	CORRIDOR	CPT-1	WB-1	PT-1	PT-1	PT-1	PT-1	---	---	APC-1	8'-7"±	2,6	004
005	UTILITY	ETR	ETR	PT-1	PT-1	PT-1	PT-1	---	---	ETR	ETR	1,6	005
006	CONFERENCE	CPT-1	WB-1	PT-1	PT-1	PT-1	PT-1	PLAM-3	SS-5	APC-1	8'-7"±	2	006
007	RESTROOM	CFT-1	CWB-1	PT-2	CWT-1/PT-2	CWT-1/PT-2	CWT-1/PT-2	PLAM-1	SS-1	APC-1	8'-7"±	2,4,5,7,8	007
008	RESTROOM	CFT-1	CWB-1	PT-2	CWT-1/PT-2	CWT-1/PT-2	CWT-1/PT-2	PLAM-1	SS-1	APC-1	8'-7"±	2,4,5,7,8	008
009	SECURE STORAGE	FC-1	FC-1	PT-1	PT-1	PT-1	PT-1	---	---	ETR	ETR	1,3,6	009
010	SECURE STORAGE	FC-1	FC-1	PT-1	PT-1	PT-1	PT-1	---	---	ETR	ETR	1	010
011	WORK SPACE	FC-1	FC-1	PT-1	PT-1	PT-1	PT-1	---	---	ETR	ETR	3,6	011
012	CORRIDOR	CPT-1	WB-1	PT-1	PT-1	PT-1	PT-1	---	---	APC-1	8'-7"±	2,6	012
EL-01-00	ELEVATOR	ETR	ETR	ETR	ETR	ETR	ETR	---	---	ETR	ETR		EL-01-00
ST-01-00	STAIR	ETR	ETR	ETR	ETR	ETR	ETR	---	---	ETR	ETR		ST-01-00
ST-02-00	STAIR	ETR	ETR	ETR	ETR	ETR	ETR	---	---	ETR	ETR		ST-02-00

FIRST FLOOR

101	RESTROOM	CFT-1	CWB-1	PT-2	CWT-1/PT-2	CWT-1/PT-2	CWT-1/PT-2	PLAM-1	SS-1	APC-1	8'-10"±	2,4,5,7,8	101
102	RESTROOM	CFT-1	CWB-1	PT-2	CWT-1/PT-2	CWT-1/PT-2	CWT-1/PT-2	PLAM-1	SS-1	APC-1	8'-10"±	2,4,5,7,8	102

SECOND FLOOR


201	OFFICE	CPT-1	WB-1	PT-1	PT-1	PT-1	PT-1	---	---	APC-1	8'-10"x	2	201
202	OFFICE	CPT-1	WB-1	PT-1	PT-1	PT-1	PT-1	---	---	APC-1	8'-10"x	2	202
203	OFFICE	CPT-1	WB-1	PT-1	PT-1	PT-1	PT-1	---	---	APC-1	8'-10"x	2	203
204	OFFICE	CPT-1	WB-1	PT-1	PT-1	PT-1	PT-1	---	---	APC-1	8'-10"x	2	204
205	IT	CPT-1	WB-1	PT-1	PT-1	PT-1	PT-1	---	---	APC-1	8'-10"x	2	205
206	OPEN OFFICE	CPT-1	WB-1	PT-1	PT-1	PT-1	PT-1	---	---	ETR / APC-1	8'-10"x	2	206
207	CORRIDOR	CPT-1	WB-1	PT-1	PT-1	PT-1	PT-1	---	---	APC-1	8'-10"x	2	207
208	CORRIDOR	CPT-1	WB-1	PT-1	PT-1	PT-1	PT-1	---	---	APC-1	8'-10"x	2	208
209	OFFICE	CPT-1	WB-1	PT-1	PT-1	PT-1	PT-1	---	---	APC-1	8'-10"x	2	209
210	OFFICE	CPT-1	WB-1	PT-1	PT-1	PT-1	PT-1	---	---	APC-1	8'-10"x	2	210
211	CUSTODIAL	VCT-1	VWB-1	PT-1	PT-1	PT-1	PT-1	---	---	APC-1	8'-10"x	1,2,6	211
212	RESTROOM	CFT-1	CWB-1	PT-2	CWT-1/PT-2	CWT-1/PT-2	CWT-1/PT-2	PLAM-1	SS-1	APC-1	8'-10"x	2,4,5,7,8	212
213	RESTROOM	CFT-1	CWB-1	PT-2	CWT-1/PT-2	CWT-1/PT-2	CWT-1/PT-2	PLAM-1	SS-1	APC-1	8'-10"x	2,4,5,7,8	213
214	BREAK	LVT-1	WB-1	PT-3	PT-3	PT-3	PT-3	PLAM-2	SS-4	APC-1	8'-10"x	2,6	214
215	PRINT AREA	CPT-1	WB-1	PT-1	PT-1	PT-1	PT-1	---	---	APC-1	8'-10"x	2	215
216	OPEN OFFICE	CPT-1	WB-1	PT-1	PT-1	PT-1	PT-1	---	---	APC-1	8'-10"x	2	216
217	IT OFFICE	CPT-1	WB-1	PT-1	PT-1	PT-1	PT-1	---	---	APC-1	8'-10"x	2	217
218	STORAGE	CPT-1	WB-1	PT-1	PT-1	PT-1	PT-1	---	---	ETR	ETR	2	218
219	OFFICE	CPT-1	WB-1	PT-1	PT-1	PT-1	PT-1	---	---	APC-1	8'-10"x	2	219
220	OFFICE	CPT-1	WB-1	PT-1	PT-1	PT-1	PT-1	---	---	APC-1	8'-10"x	2	220
221	OFFICE	CPT-1	WB-1	PT-1	PT-1	PT-1	PT-1	---	---	APC-1	8'-10"x	2	221
EL-01-02	ELEVATOR	ETR	ETR	ETR	ETR	ETR	ETR	---	---	ETR	ETR		EL-01-02
ST-01-02	STAIR	ETR	ETR	ETR	ETR	ETR	ETR	---	---	ETR	ETR		ST-01-02
ST-02-02	STAIR	ETR	ETR	ETR	ETR	ETR	ETR	---	---	ETR	ETR		ST-02-02

KEY TO FINISH SCHEDULE


<u>CARPET FLOORING:</u> CPT-1: MANUFACTURER - MOHAWK GROUP TYPE - 12x36 TILE STYLE - GENTLE GROUND GT364 COLOR - 739 NECTAR INSTALL- BRICK ASHLAR	<u>PAINTS & PAINT SYSTEM</u> PAINT MANUFACTURER - SHERWIN WILLIAMS PT-1: FINISH - EGGSHELL COLOR - TBD PT-2: FINISH - EGGSHELL COLOR - TBD PT-3: FINISH - EGGSHELL COLOR - TBD PT-4: FINISH - SEMI-GLOSS COLOR - TBD PT-5: FINISH - SEMI-GLOSS COLOR - TBD	<u>FLOOR COATING:</u> FC-1: MANUFACTURER - SHERWIN-WILLIAMS TYPE - RESUFLOOR AQUA EPOXY STYLE - INTEGRATED WALL BASE COLOR - TBD	<u>SOLID SURFACING MATERIAL</u> SS-1: MANUFACTURER - FORMICA EVERFORM STYLE - VANITY COLOR - ARCTIC 102 THICKNESS - 1/2-INCH
<u>WALL BASE:</u> WB-1: WOOD MOLDING WALL BASE MANUFACTURER - MOLDINGS ONE TYPE - POPLAR WOOD PROFILE - OGEE, 2093 SIZE - 3/4" X 4" FINISH- FACTORY PRIMED, PAINTED CWB-1: CERAMIC TILE WALL BASE MANUFACTURER - ARIZONA TILE PROFILE - TRAPEZ COLOR - CREAM GROUT- OYSTER GRAY INSTALL- FLAT BOND VWB-1: VINYL WALL BASE MANUFACTURER - JOHNSONITE TYPE - VINYL PROFILE- COVE SIZE - 4" COLOR- PEBBLE 32 VWB-2: VINYL WALL BASE MANUFACTURER - JOHNSONITE TYPE - VINYL PROFILE- COVE SIZE - 4" COLOR- BLACK	<u>ACOUSTIC PANEL CEILING</u> APC-1: MANUFACTURER - ARMSTRONG TYPE - ULTIMA HIGH NRC 2x2 1941 PROFILE - BEVELED REGULAR GRID - PRELUDE COLOR - WHITE <u>CERAMIC FLOOR TILE:</u> CFT-1: MANUFACTURER - DALTILE SIZE - 12x24 STYLE - COHESION COLOR - BEIGE C022	<u>VINYL COMPOSITION TILE:</u> VCT-1: MANUFACTURER -"ARMSTRONG" TYPE - PREMIUM EXCELOX 52143 STYLE - STONETEX COLOR - SANDSTONE TAN <u>TRANSITION STRIPS</u> MANUFACTURER - SCHLUTER OR ROPPE STYLE - TBD (SEE DOOR SILL CONDITIONS)	SS-2: MANUFACTURER - DUPONT CORIAN STYLE - BACKSPASH COLOR - NATURAL GRAY THICKNESS - 1/2-INCH SS-3: MANUFACTURER "DUPONT" STYLE - THRESHOLD W/ CHAMFERED EDGES COLOR - TBD THICKNESS - 1/2-INCH SIZE - MATCH WALL THICKNESS AND DOOR WIDTH SS-4: MANUFACTURER - DUPONT CORIAN STYLE - COUNTER TOP COLOR - NATURAL GRAY THICKNESS - 1/2-INCH SS-5: MANUFACTURER - DUPONT CORIAN STYLE - COUNTER TOP COLOR - CAMEO WHITE THICKNESS - 1/2-INCH
<u>CERAMIC WALL TILE:</u> CWT-1: MANUFACTURER - ARIZONA TILE STYLE - TRAPEZ COLOR - CREAM GROUT- OYSTER GRAY INSTALL- AS SHOWN, HEXAGON	<u>LUXURY VINYL TILE:</u> LVT-1: MANUFACTURER - ARMSTRONG TYPE - AMERICAN CHARM, U7125 STYLE - OSCFORD WHITE OAK COLOR - NATURAL HARMONY INSTALL- 1/3 STAGGERED	<u>CERAMIC TILE ACCESSORIES</u> MANUFACTURER - SCHLUTER STYLE - TBD (SEE NOTES FOR CONDITIONS) <u>PLASTIC LAMINATE</u> PLM-1: MANUFACTURER - FORMICA STYLE - LAMINATE (VERTICAL) COLOR - SOLENNNE 8301 PLM-2: MANUFACTURER - FORMICA STYLE - LAMINATE (VERTICAL) COLOR - NILE VELVET 15515 PLM-3: MANUFACTURER - WILSONART* STYLE - LAMINATE (VERTICAL) COLOR - JUBILEE OAK 8242 PLM-4: MANUFACTURER - FORMICA STYLE - LAMINATE (VERTICAL) COLOR - BLACK 1595	<u>REMARKS</u> 1. REMOVE AND SALVAGE ALL ACCESSORIES AND REINSTALL AFTER FINISHES ARE INSTALLED. 2. MATCH EXISTING CEILING HEIGHT, VIF. 3. PROVIDE AND INSTALL NECESSARY SUPPORT, GRID, AND ACCESSORIES TO ACCOMMODATE NEW LAYOUT TO RETAIN EXISTING APC. CUT TILES AS NECESSARY TO FIT NEW GRID LAYOUT. 4. COORDINATE WITH ELEVATIONS. 5. PROVIDE SOLID SURFACING THRESHOLD SS-3. 6. PROVIDE ALUMINUM EDGING / TRANSITION STRIP. COORDINATE WITH FINISHED FLOORING. 7. PROVIDE SS COVE AT WALL-FLOOR TRANSITION, SCHLUTER DILEX-EHK. 8. PROVIDE SS FINISHING EDGE AT TOP OF WAINSCOT AND WALL BASE TILE. SCHLUTER JOLLY.

ROOM FINISH SCHEDULE | A1


A1

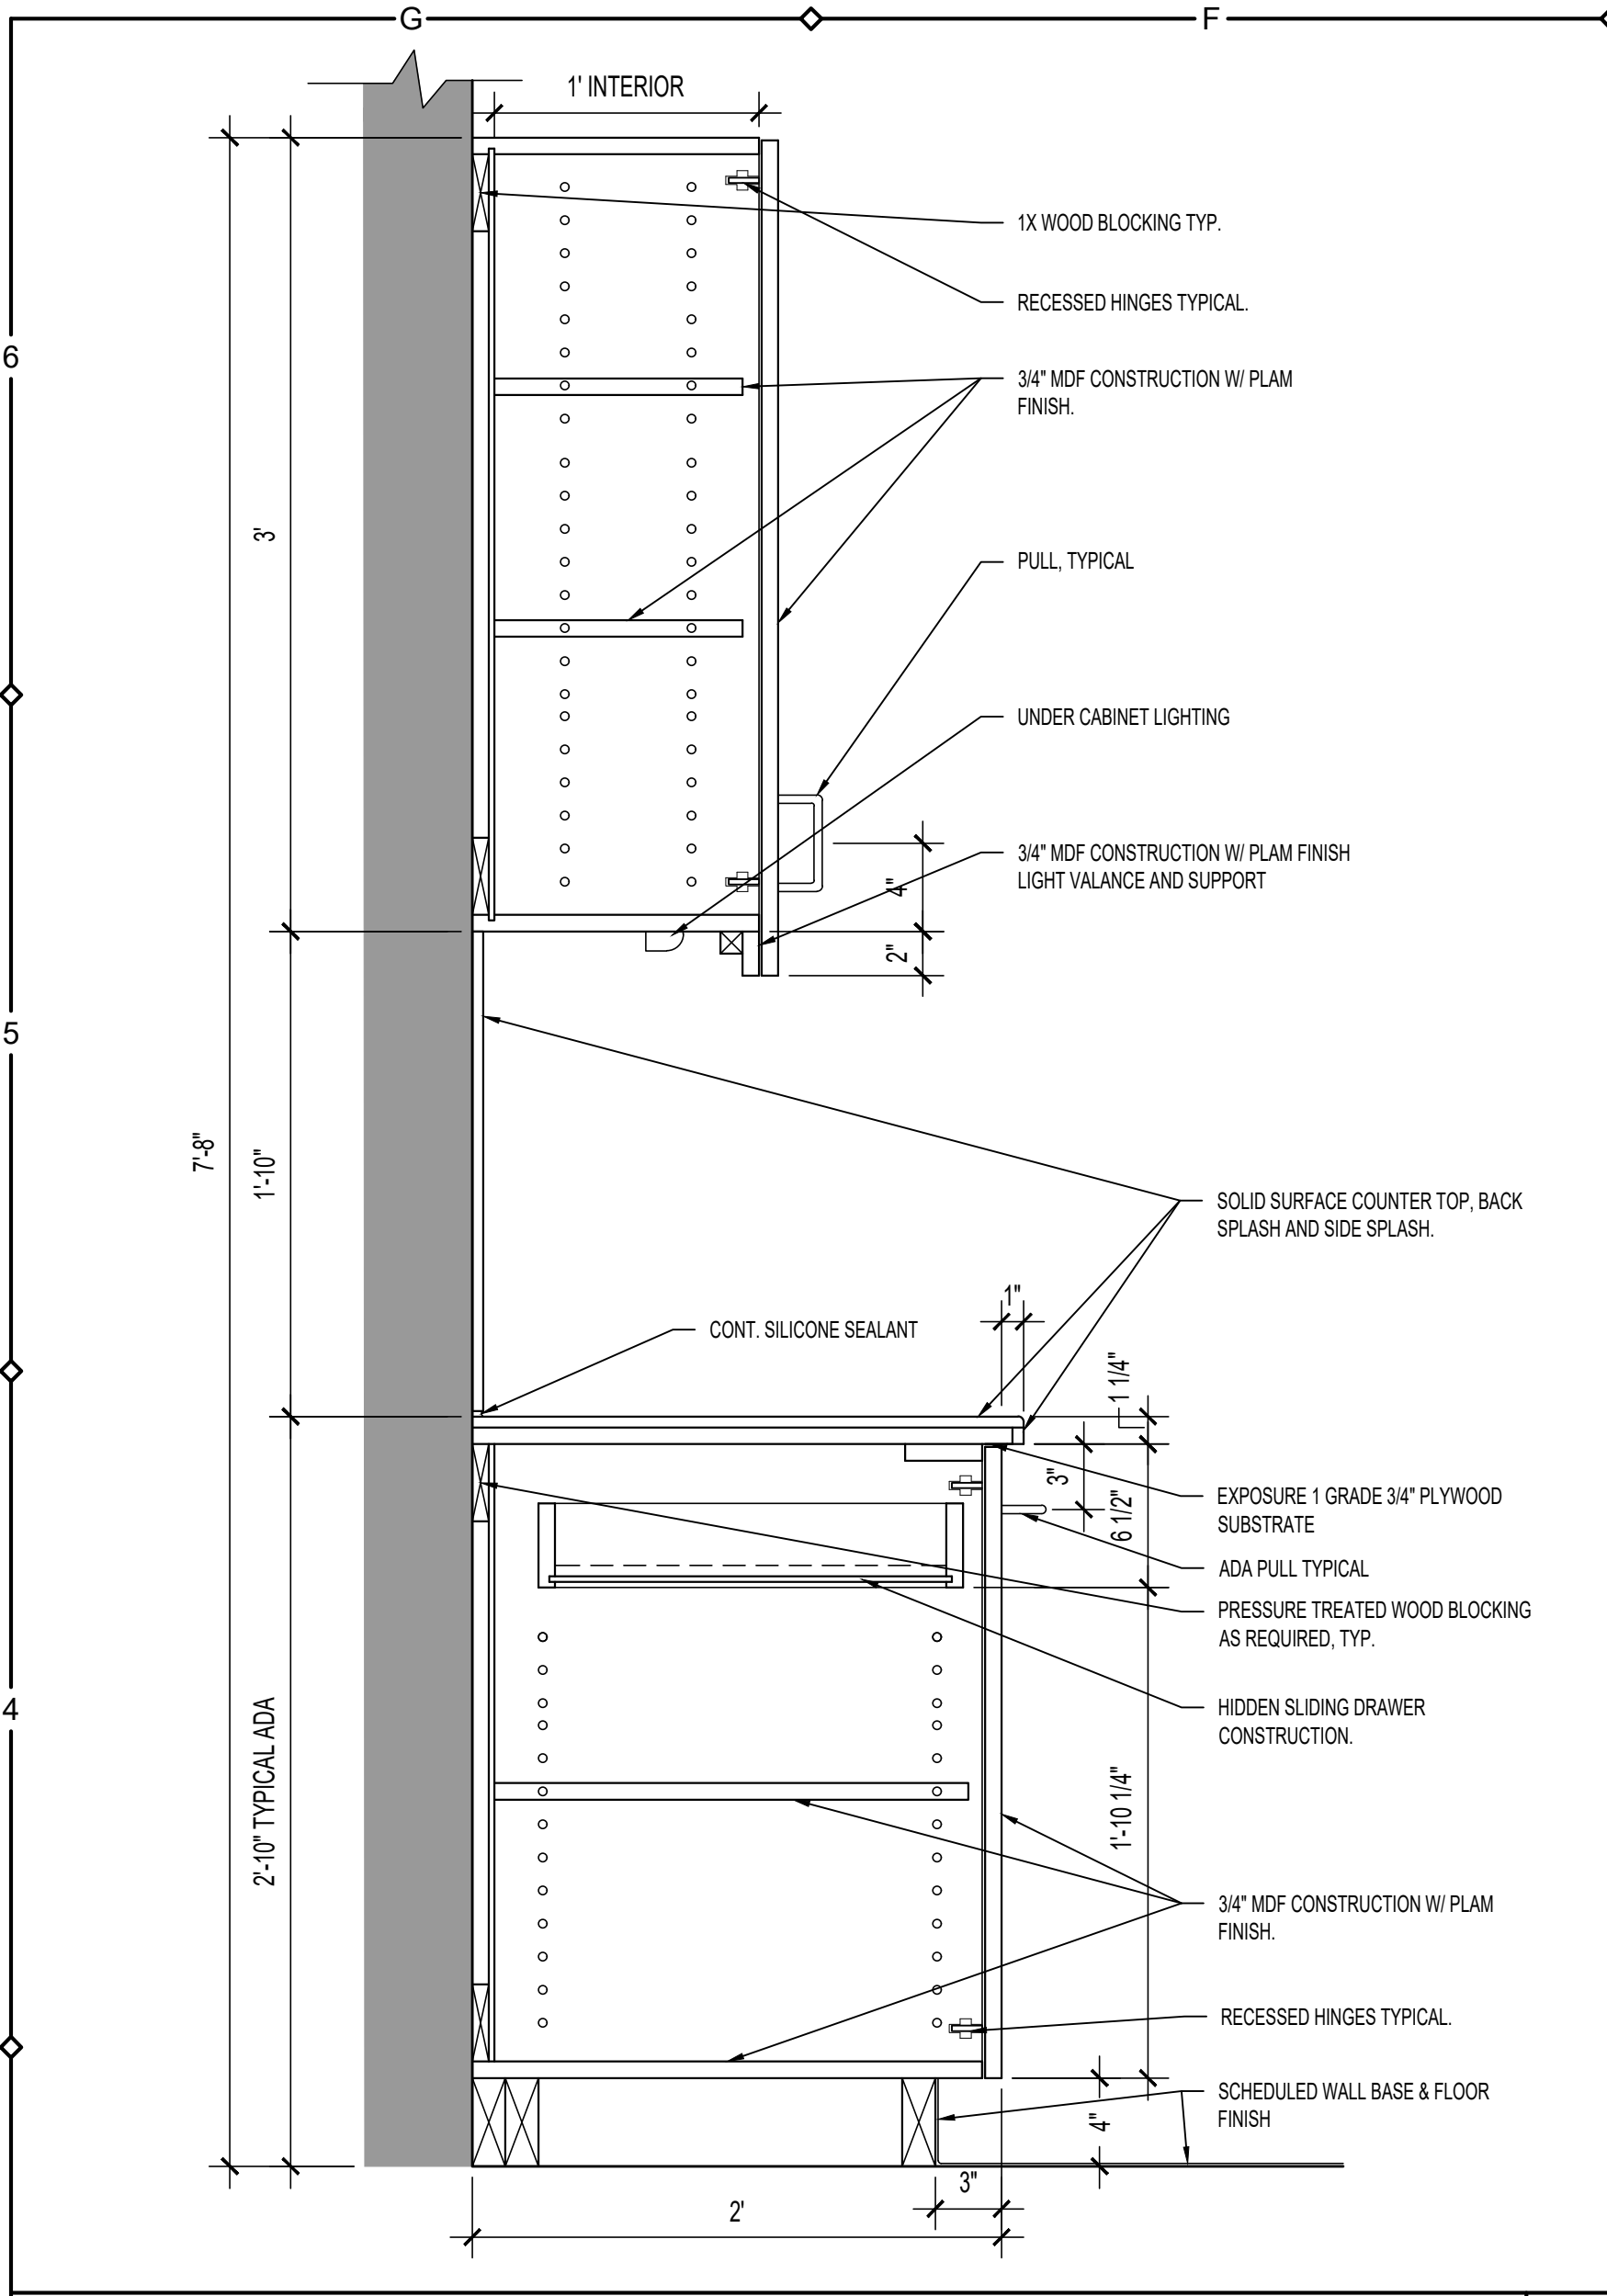


SCALE: 1-1/2" = 1'-0" BASE AND WALL CAB DETAIL F3

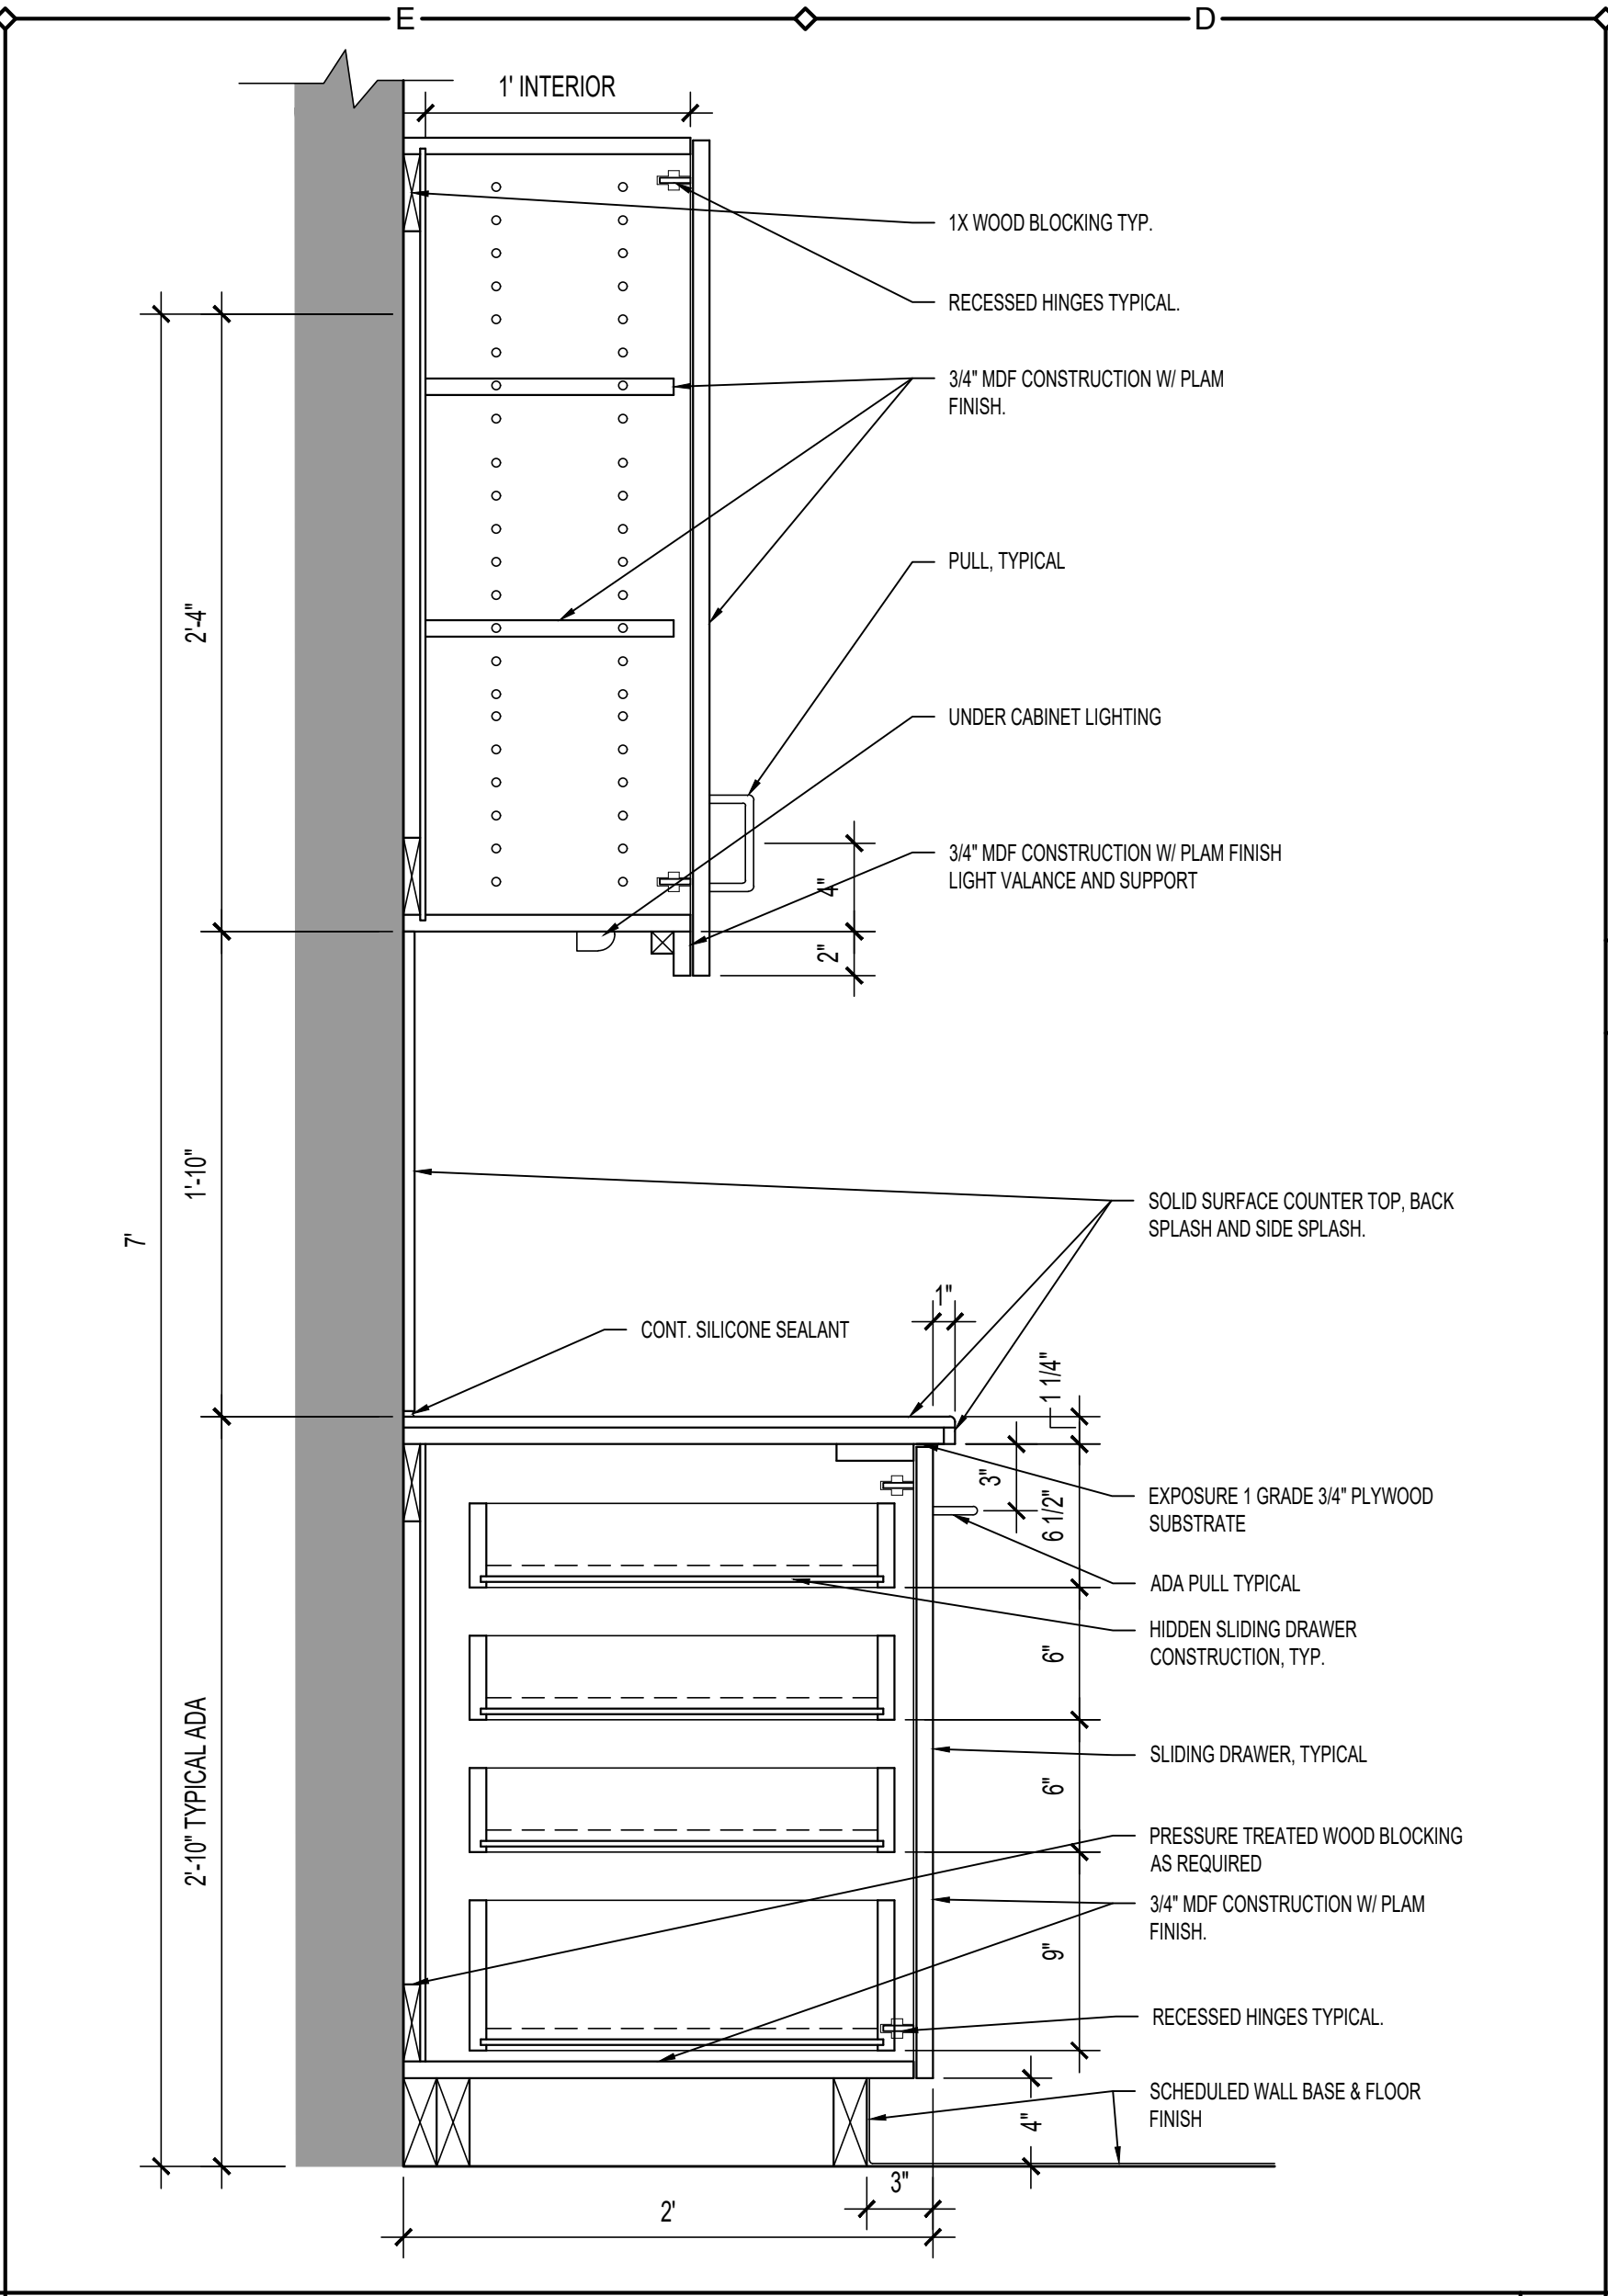


SCALE: 1-1/2" = 1'-0" BASE AND WALL CAB DETAIL D3

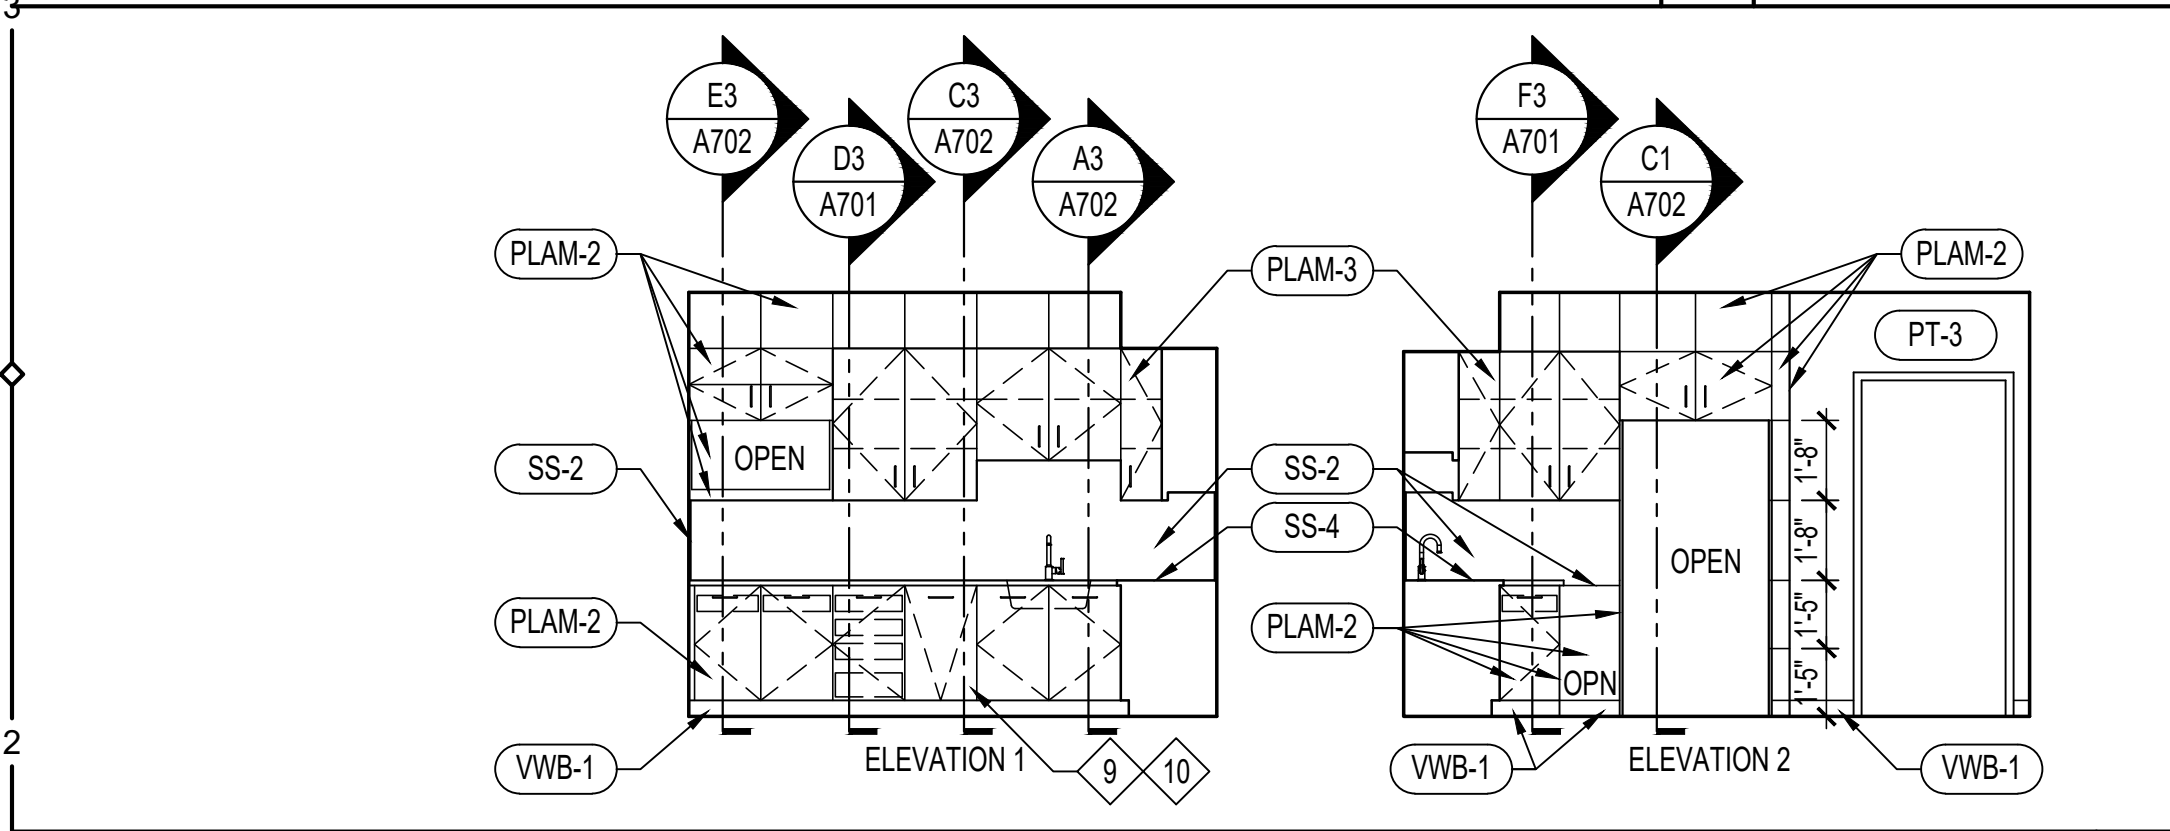


SCALE: 1/4" = 1'-0" KITCHENETTE INT ELEVATIONS E2

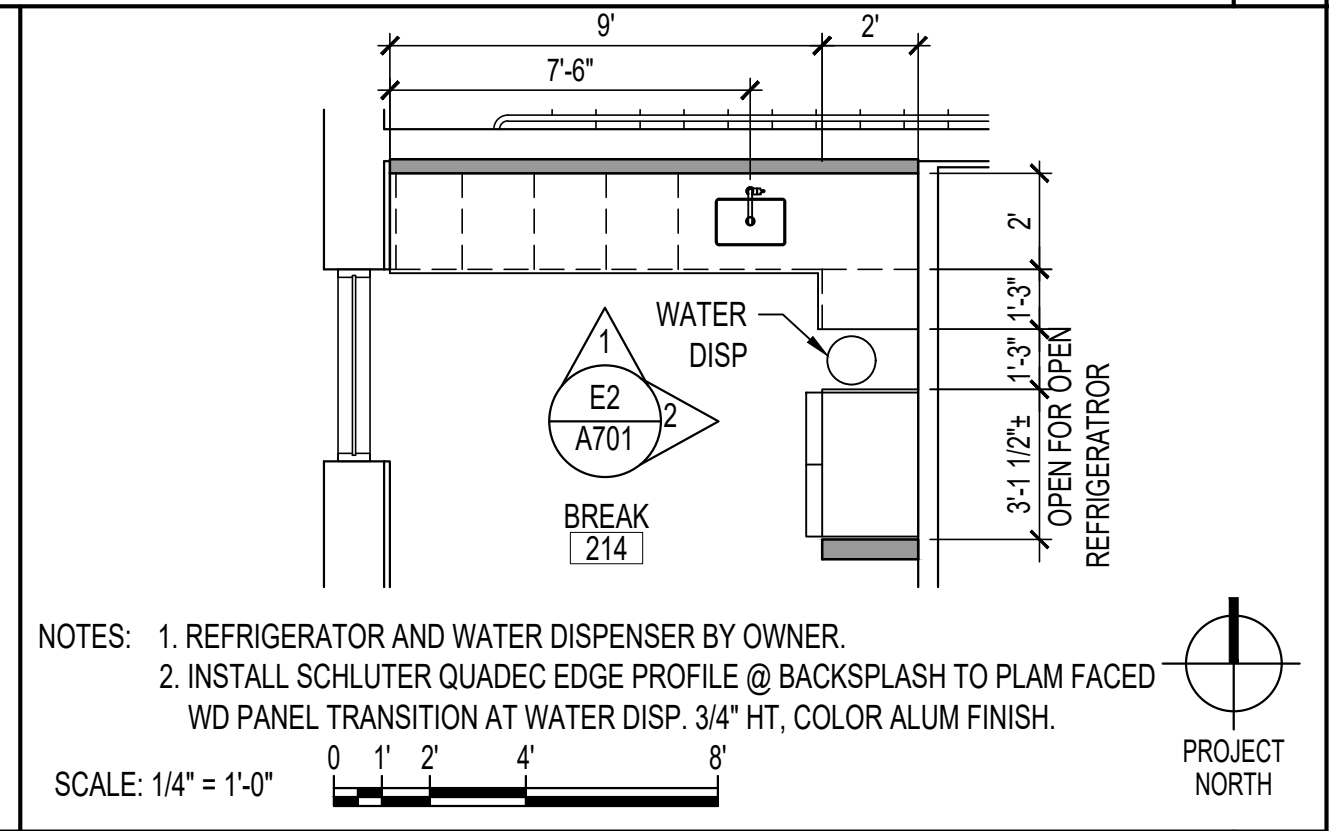


SCALE: 1/4" = 1'-0" ENLARGED KITCHENETTE PLAN D2

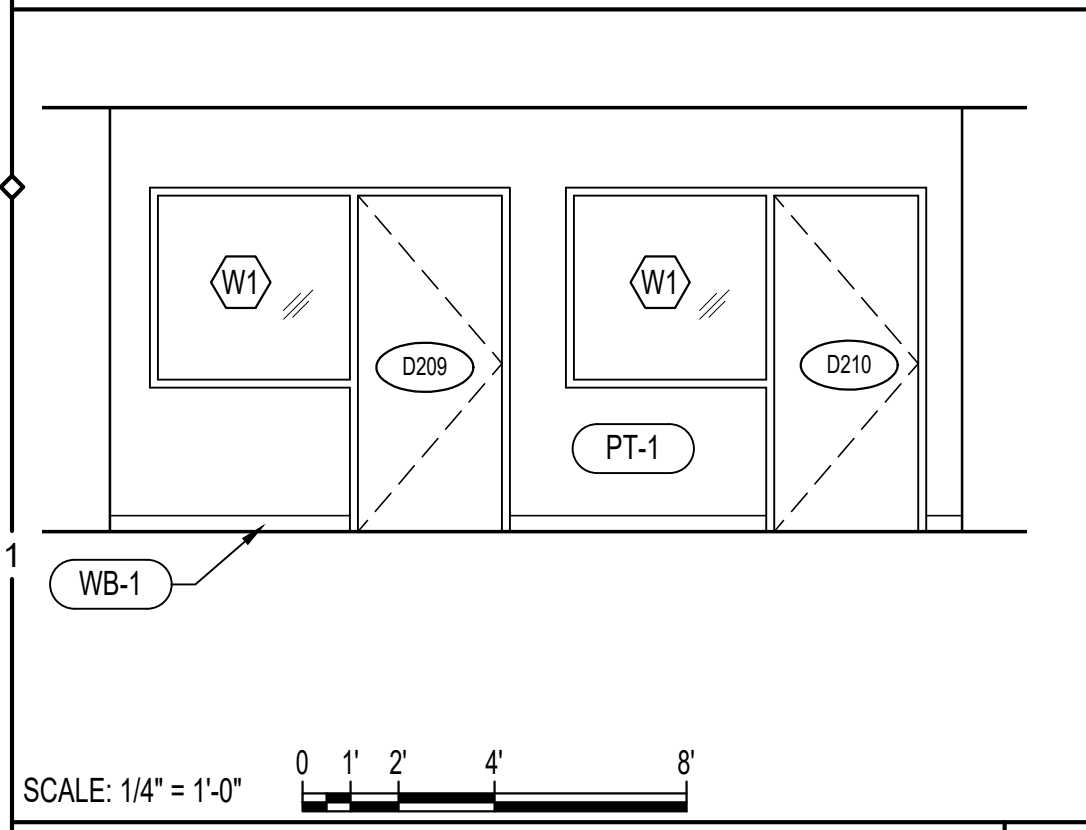

SCALE: 1/4" = 1'-0" OFFICE INT ELEVATIONS G1

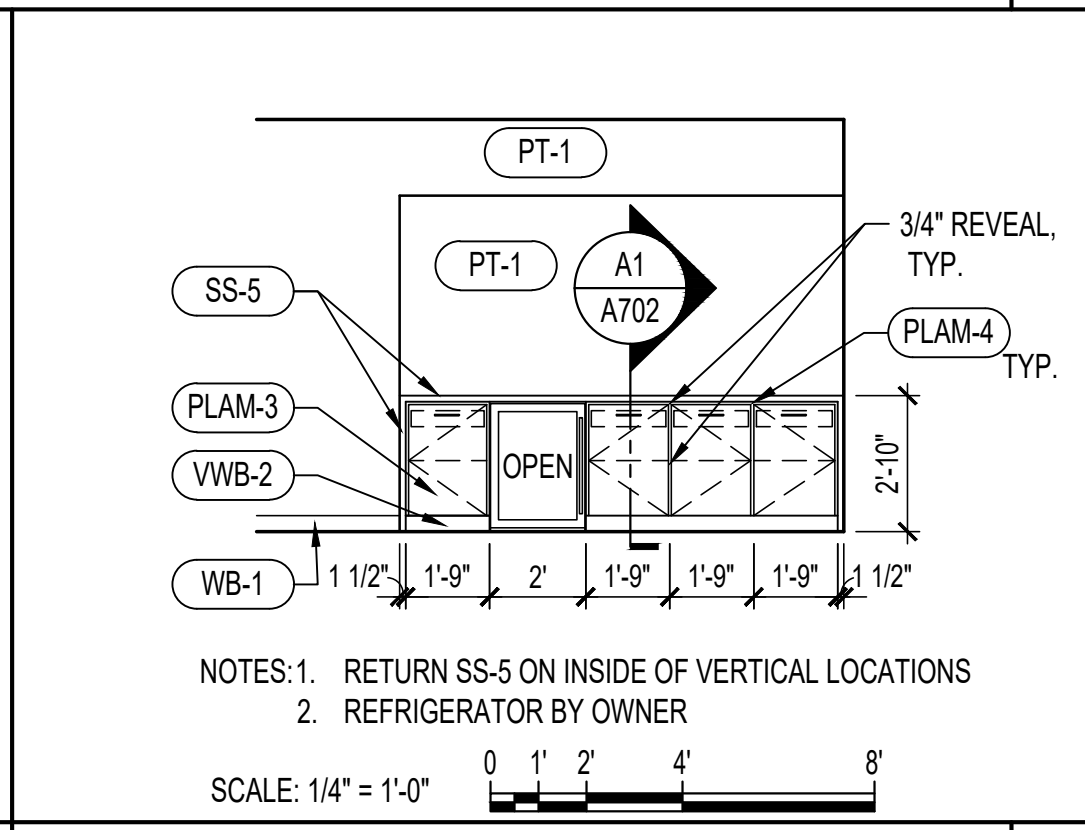

SCALE: 1/4" = 1'-0" CONFERENCE INT ELEVATIONS E1

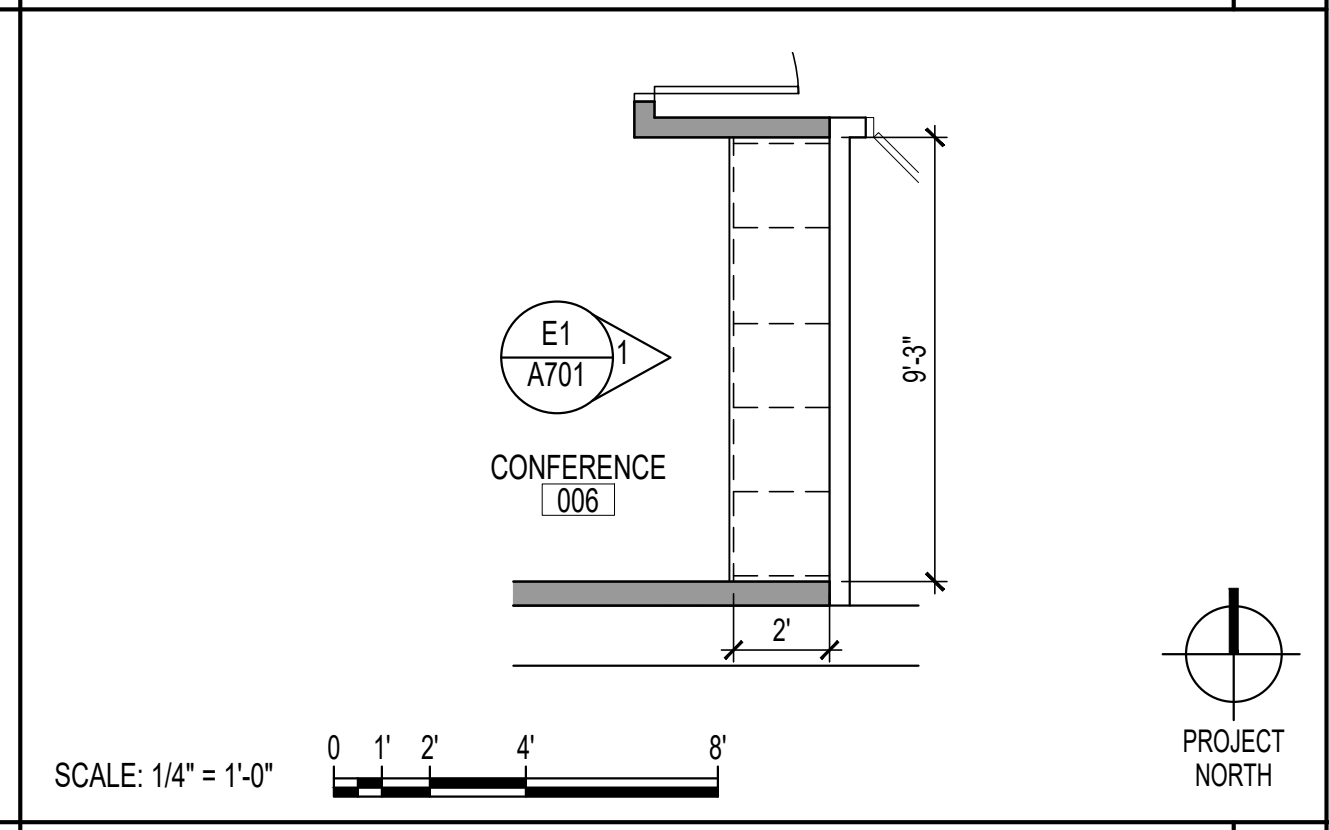


SCALE: 1/4" = 1'-0" ENLARGED CONFERENCE PLAN D1


RESTROOM ACCESSORY SCHEDULE						
MARK	QUANTITY	ITEM	MANUFACTURER	MODEL	MOUNTING	REMARKS
1	6	MIRROR	BOBRICK	B-105	SEE ELEVATIONS	
2	6	TOILET TISSUE DISPENSER	BOBRICK	B-6867	SEE ELEVATIONS	DOUBLE STANDARD ROLL
3	6	WASTE RECEPTACLE	BOBRICK	B-2300	FLOOR	W/ DOME TOP
4	6	GRAB BAR	BOBRICK	B-6806.99x36	SEE ELEVATIONS	PEENED GRIP
5	6	GRAB BAR	BOBRICK	B-6806.99x42	SEE ELEVATIONS	PEENED GRIP
6	6	PAPER TOWEL DISPENSER	BOBRICK	B-4262	SEE ELEVATIONS	SURFACE MOUNTED
7	6	SEAT COVER DISPENSER	BOBRICK	B-4221	SEE ELEVATIONS	SURFACE MOUNTED
8	12	ROBE / COAT HOOK	BOBRICK	B-76717	SEE ELEVATIONS	SURFACE MOUNTED
9	1	WASTE RECEPTACLE	RUBBERMAID	H-1859BLU	CABINET	COORDINATE W/ MILLWORK
10	1	WASTE RECEPTACLE	RUBBERMAID	S-13527BL	CABINET	COORDINATE W/ MILLWORK

GENERAL NOTES:
1) ALL QUANTITIES AND LOCATIONS TO BE VERIFIED PRIOR TO ORDERING AND INSTALLATION.
2) SEE PLUMBING DRAWINGS FOR FLOOR DRAIN LOCATIONS.


RESTROOM ACCESSORY SCHEDULE A5

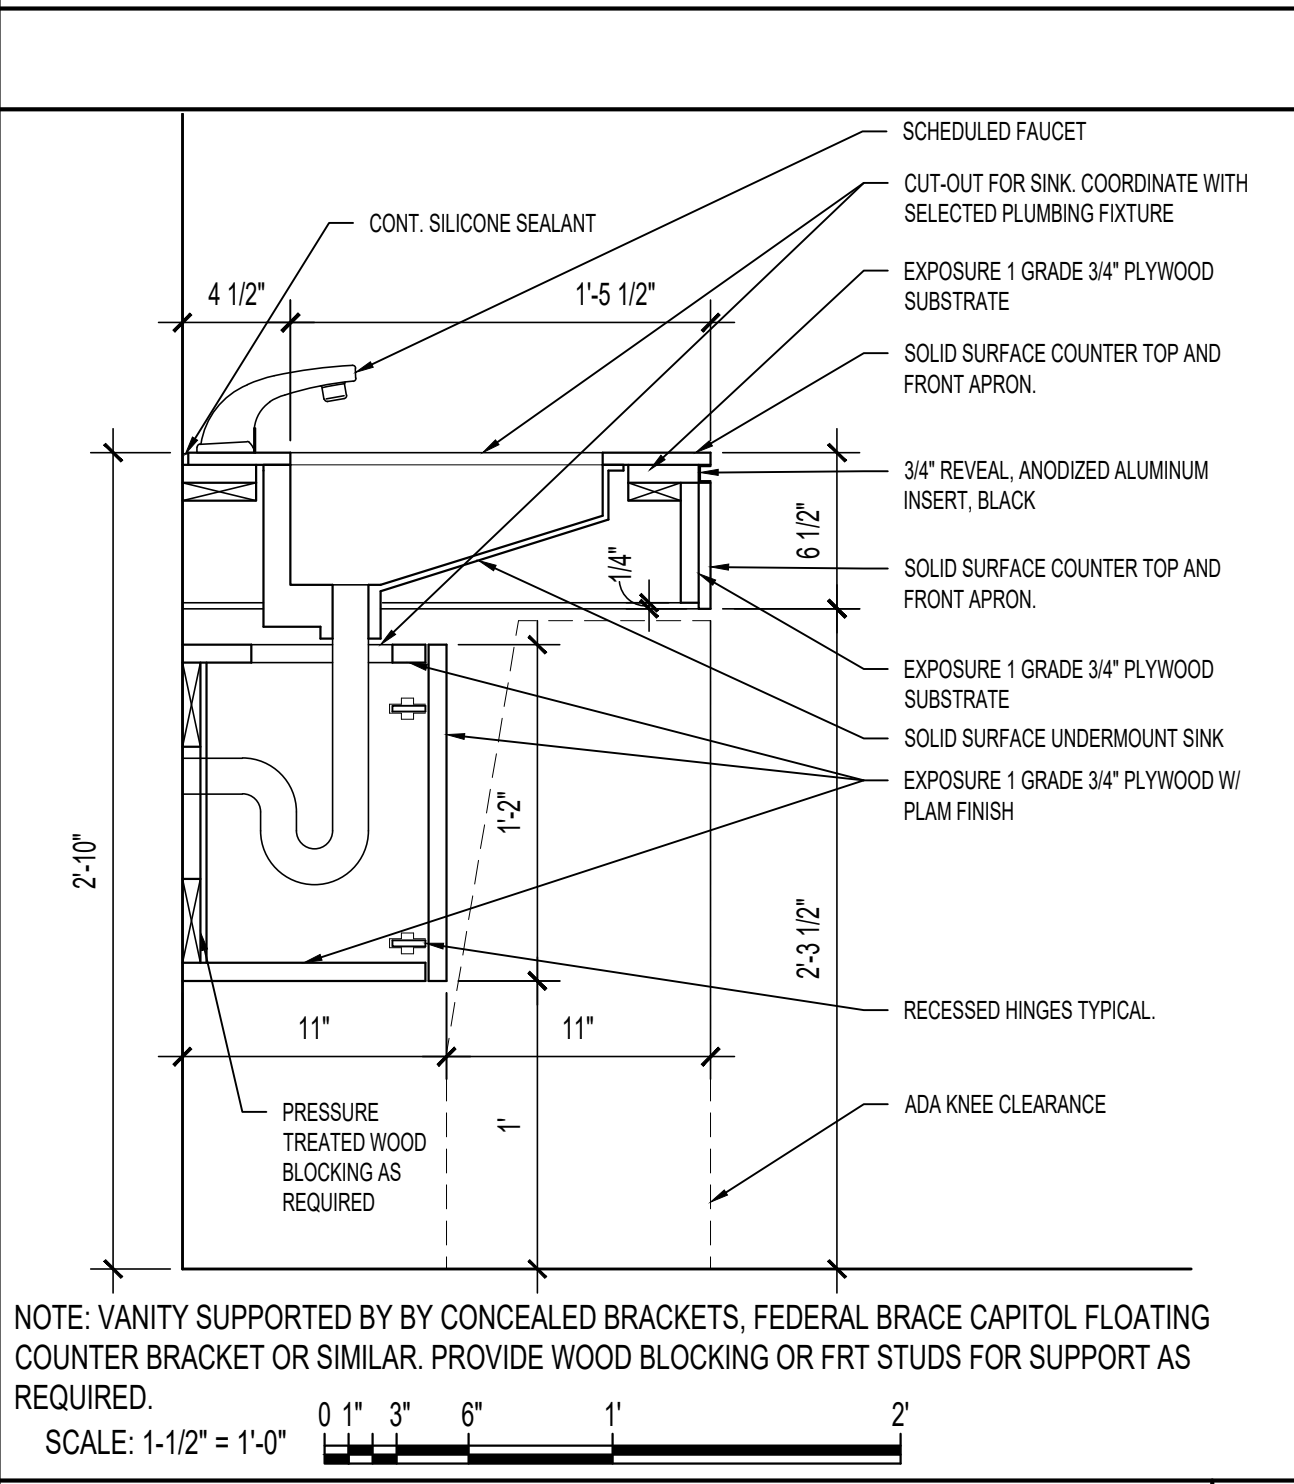


SCALE: 1-1/2" = 1'-0" VANITY DETAIL B3

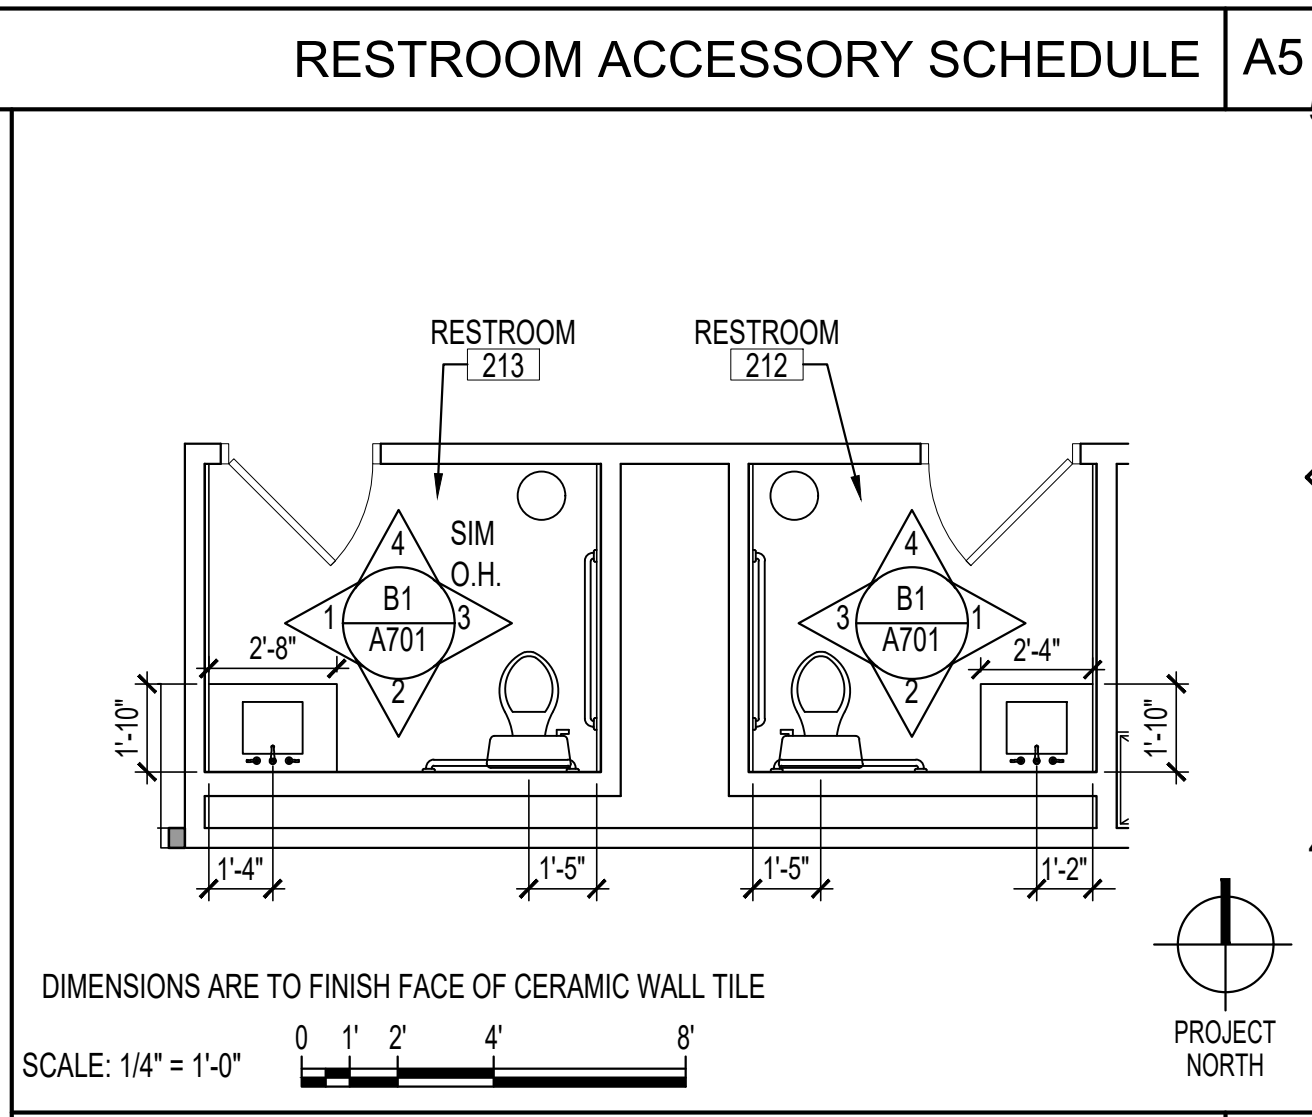


SCALE: 1/4" = 1'-0" ENLARGED RESTROOM PLAN A4

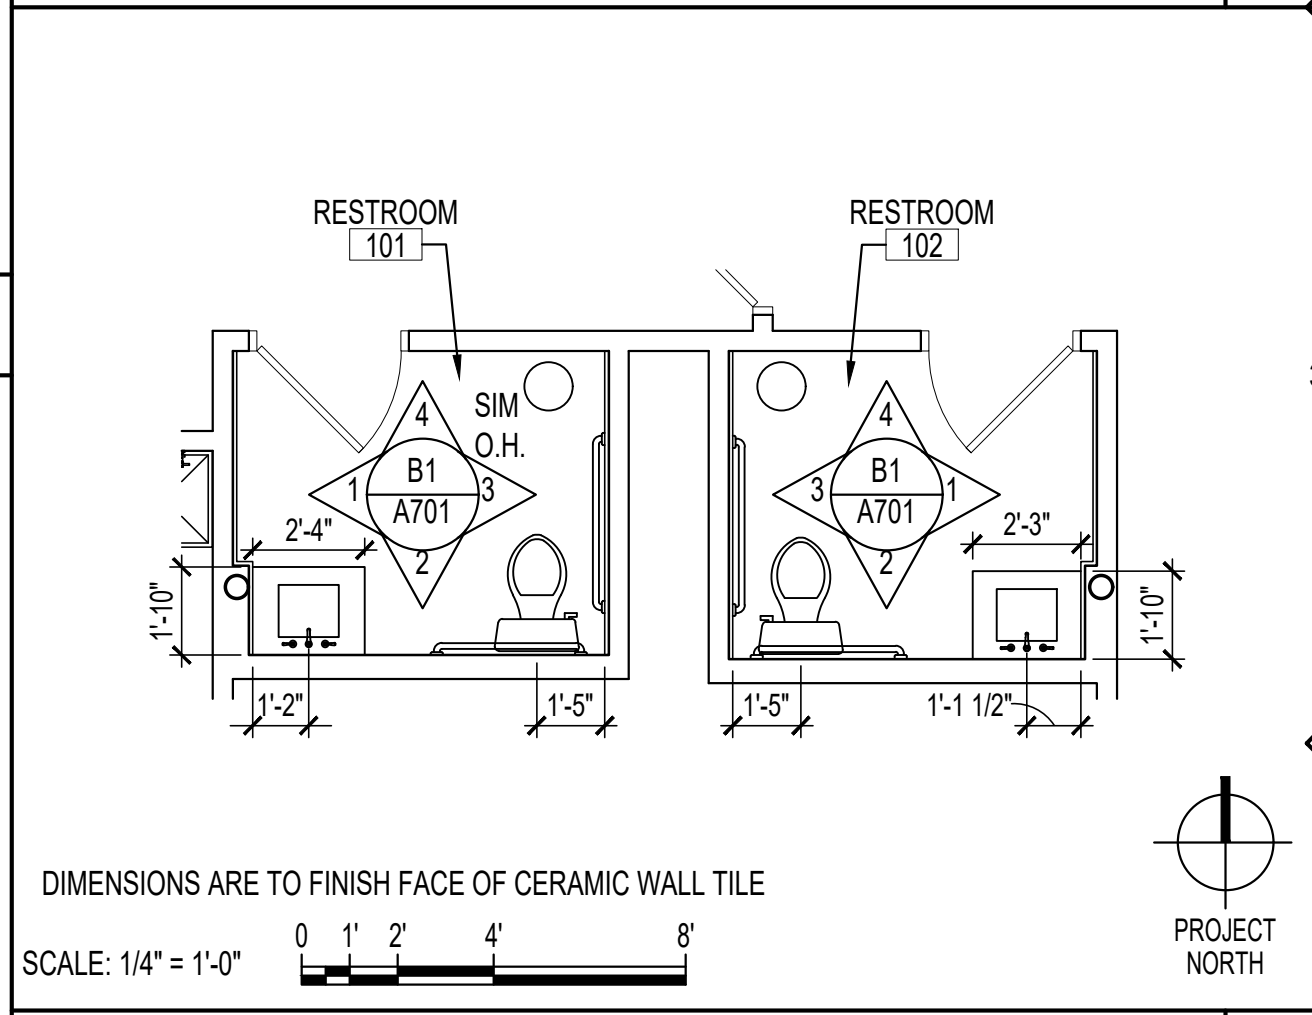

SCALE: 1/4" = 1'-0" ENLARGED RESTROOM PLAN A2

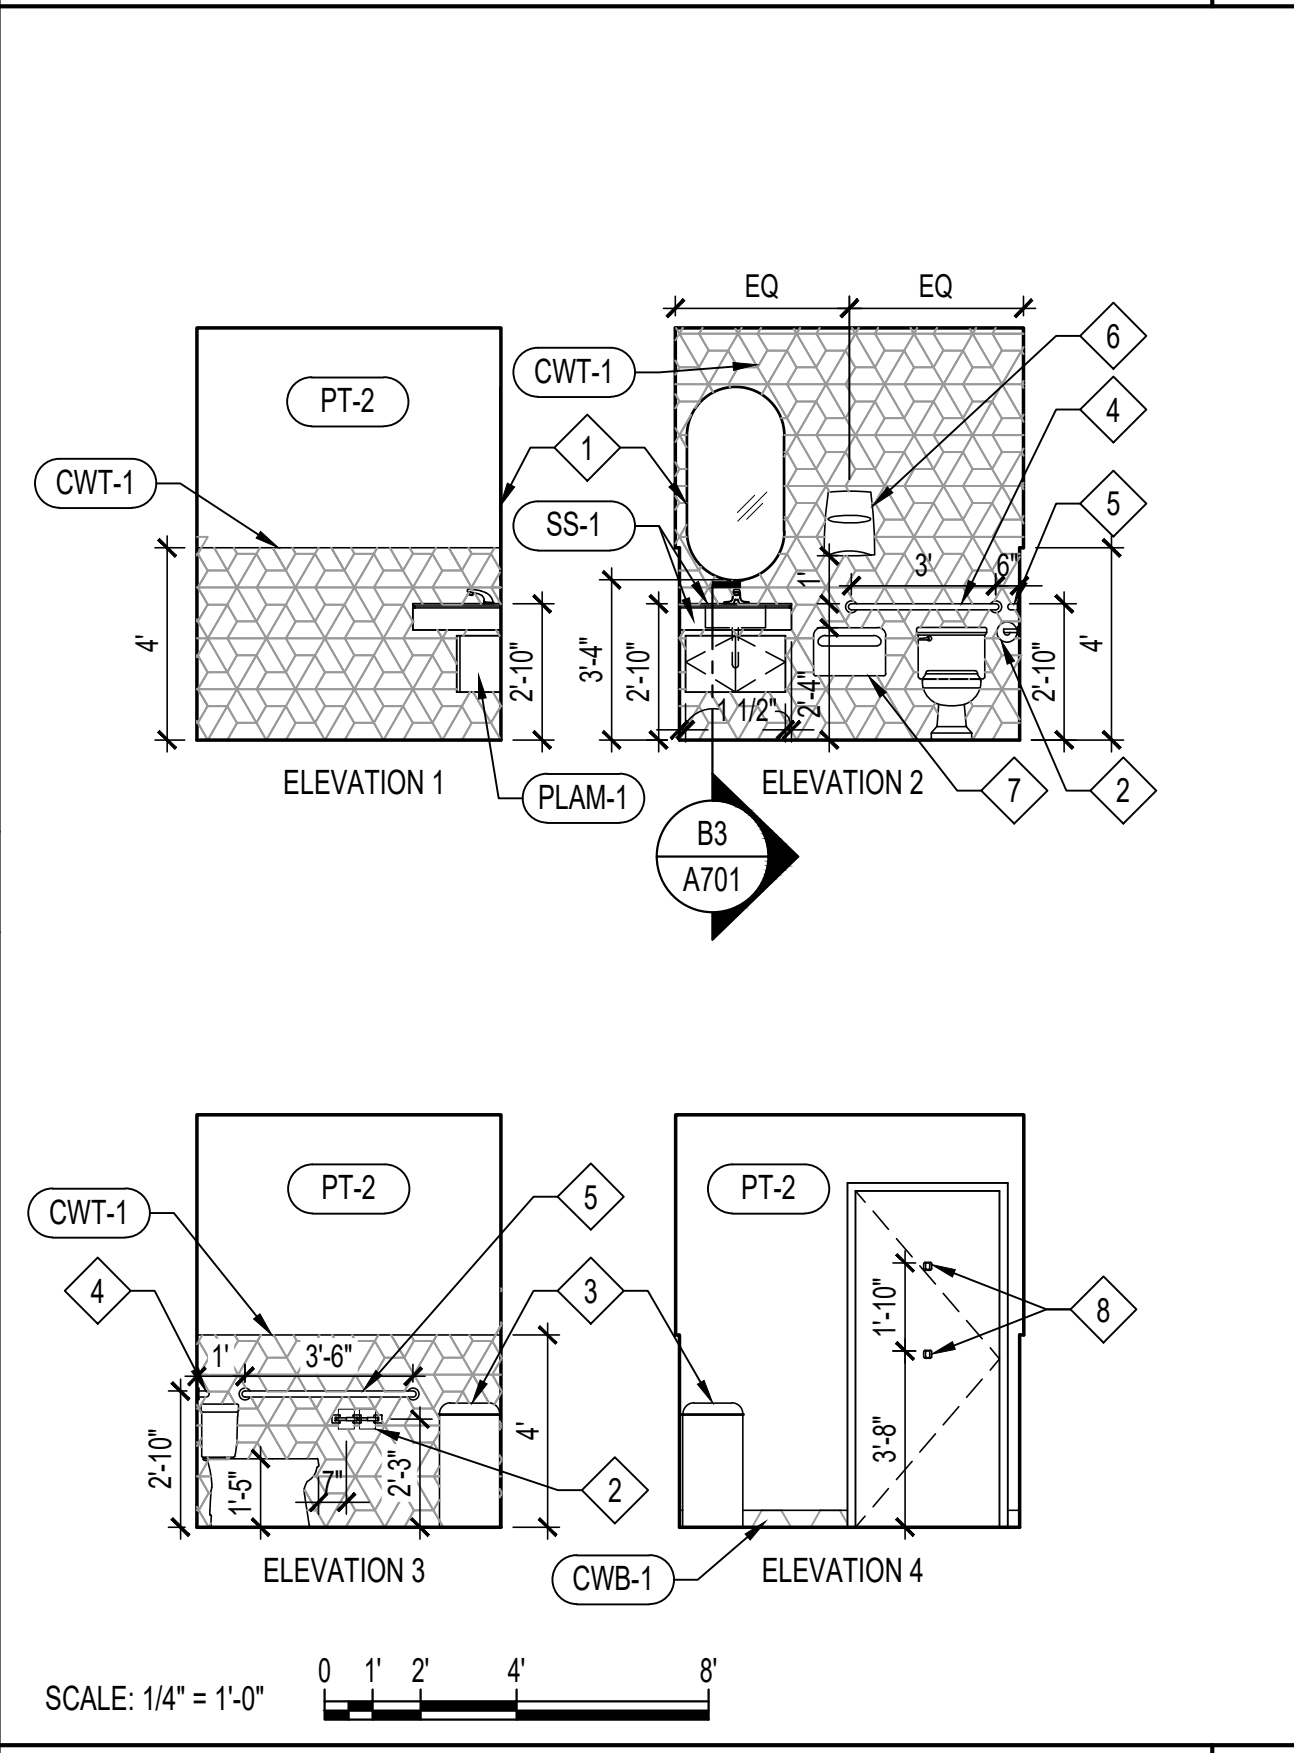

SCALE: 1/4" = 1'-0" RESTROOM ELEVATIONS B1

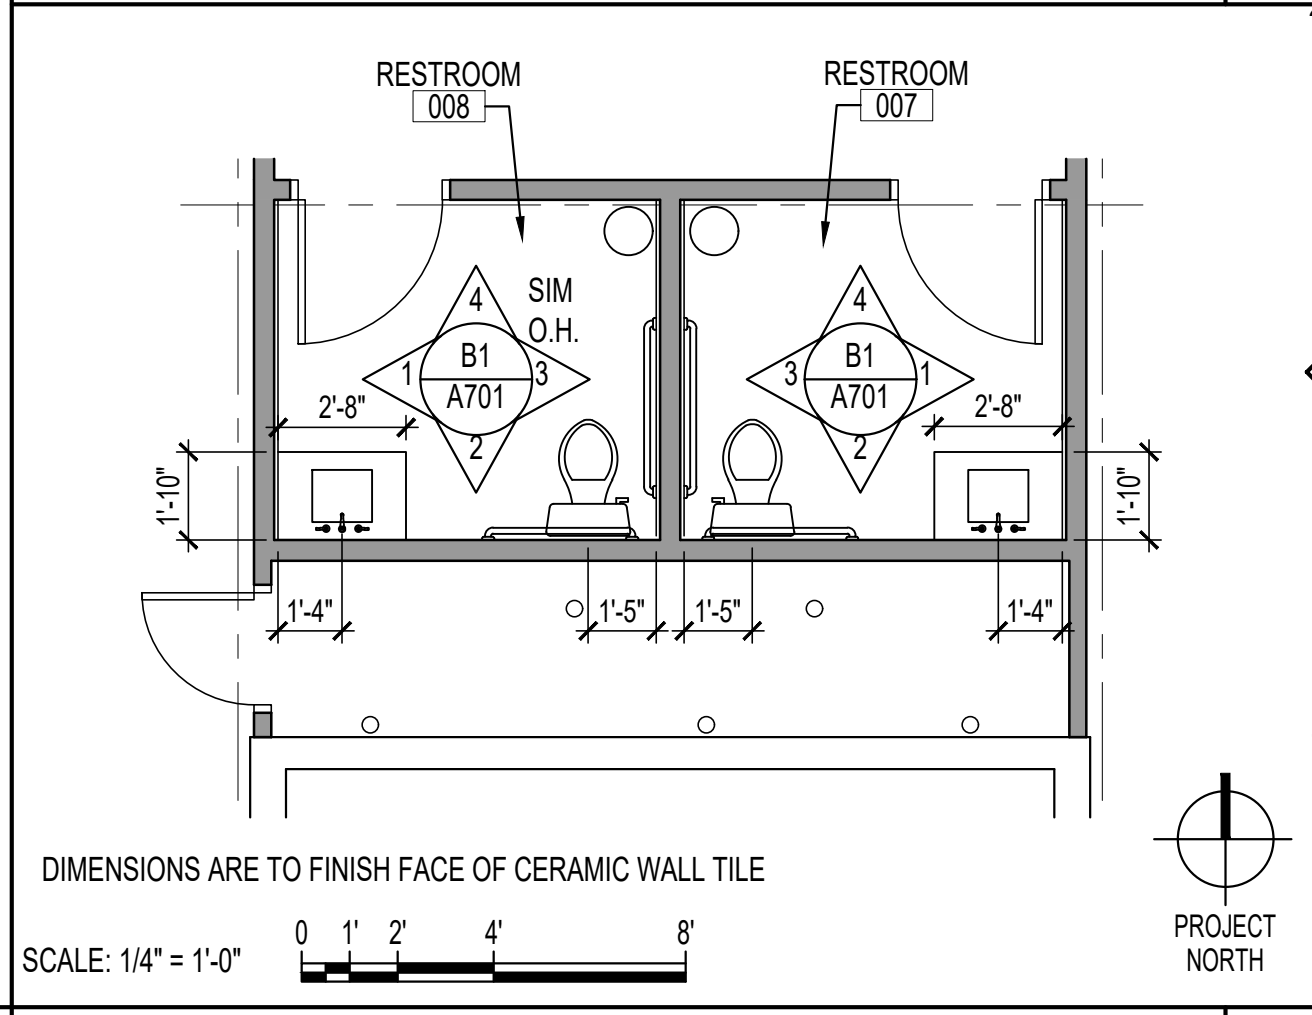

SCALE: 1/4" = 1'-0" ENLARGED RESTROOM PLAN A1

FARMERS & MERCHANTS
BANK

25 WESTMINSTER PIKE
RESTERTOWN, MARYLAND, 21136
INTERIOR ALTERATION

ARCHITECTURAL REGISTRATION BOARD
TIMOTHY H. SANDERS
STATE OF MARYLAND


I CERTIFY THAT THESE DOCUMENTS WERE PREPARED OR APPROVED BY ME AND THAT I AM A DULY LICENSED ARCHITECT UNDER THE LAWS OF THE STATE OF MARYLAND.
LICENSE NO.: 8596
EXP. DATE: 21 MAY 2027
THESE DRAWINGS ARE NOT PERMITTED TO BE COPIED OR REPRODUCED, EITHER WHOLLY OR PARTIALLY, UNLESS WRITTEN PERMISSION IS FIRST OBTAINED FROM SANDERS DESIGNS, P.A.

SANDERS | DESIGNS
ARCHITECTS PLANNERS


WWW.SANDERSDESIGNS.COM
MAILBOX@SANDERSDESIGNS.COM
9727 GREENSIDE DRIVE, SUITE 202, COCKEYSVILLE, MARYLAND 21030
T: (410) 560 2624

No.	Date	Revision


Project No.: 26.102
Date: 29 SEPTEMBER 2026
Scale: AS NOTED
Edition:
Drawing Name:
Drawing Number:
PERMIT SET
ENLARGED PLANS & MILLWORK DETAILS
A701

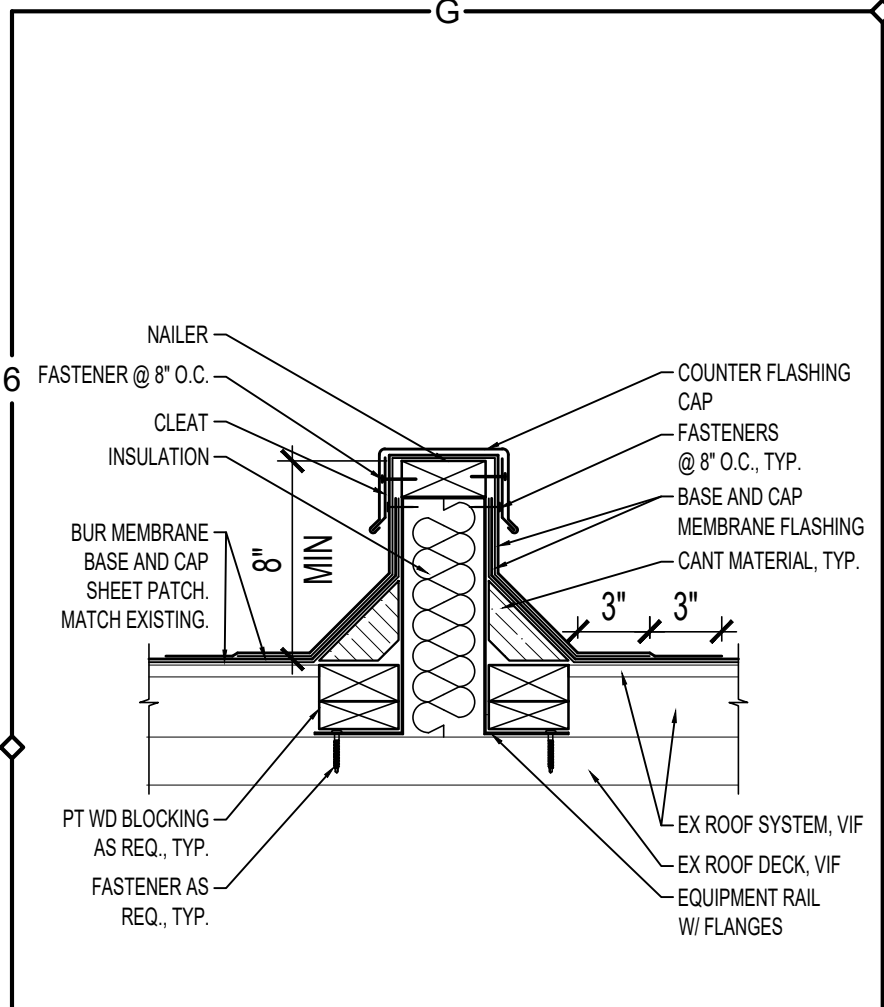

EQUIPMENT RAIL DETAIL G5

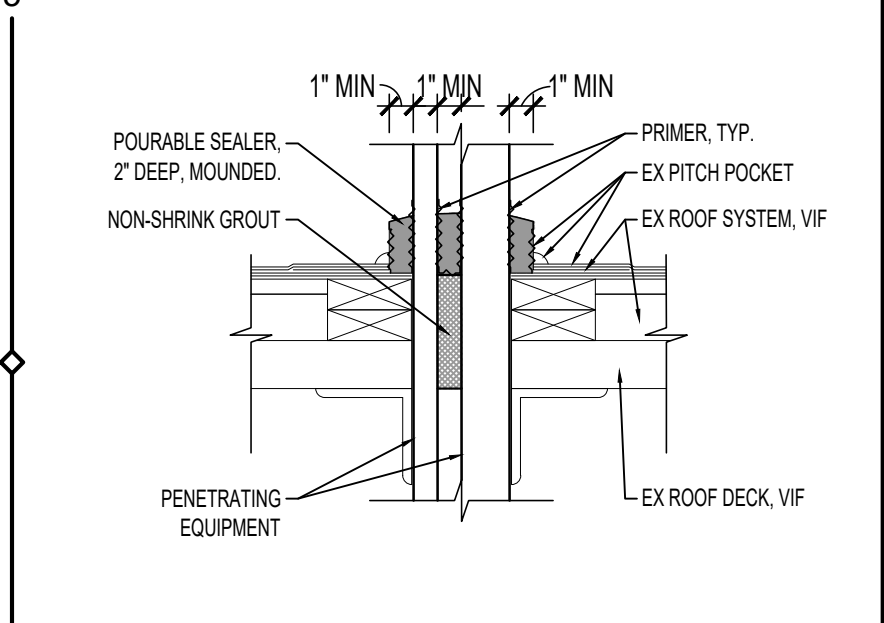


PITCH POCKET DETAIL G4

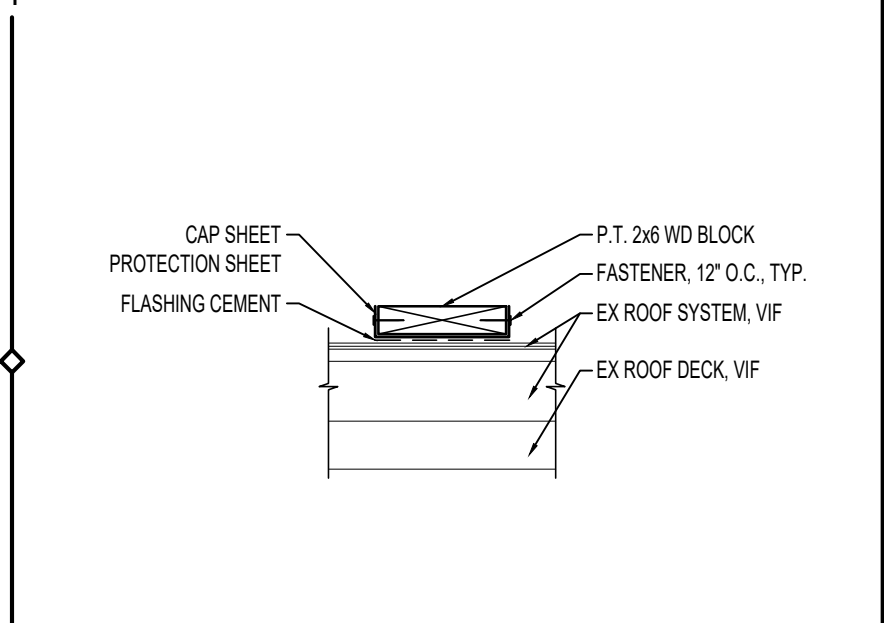


EQUIPMENT SUPPORT DETAIL G3


LOCATION			SIGN TYPE	PICTOGRAM SYMBOLS	NUMBER	TEXT	ARROW	BRAILLE
DOOR NO.	ROOM NAME	FLOOR						
D007	RESTROOM	B	A.01	MALE / FEMALE / ACCESSIBILITY	--	RESTROOM	--	RESTROOM
D008	RESTROOM	B	A.01	MALE / FEMALE / ACCESSIBILITY	--	RESTROOM	--	RESTROOM
D101	RESTROOM	1	A.01	MALE / FEMALE / ACCESSIBILITY	--	RESTROOM	--	RESTROOM
D102	RESTROOM	1	A.01	MALE / FEMALE / ACCESSIBILITY	--	RESTROOM	--	RESTROOM
D212	RESTROOM	2	B.01	FEMALE	--	WOMEN	--	WOMEN
D212	RESTROOM	2	A.02	MALE / FEMALE / ACCESSIBILITY	--	RESTROOM	RIGHT	RESTROOM
D213	RESTROOM	2	A.01	MALE / FEMALE / ACCESSIBILITY	--	RESTROOM	--	RESTROOM

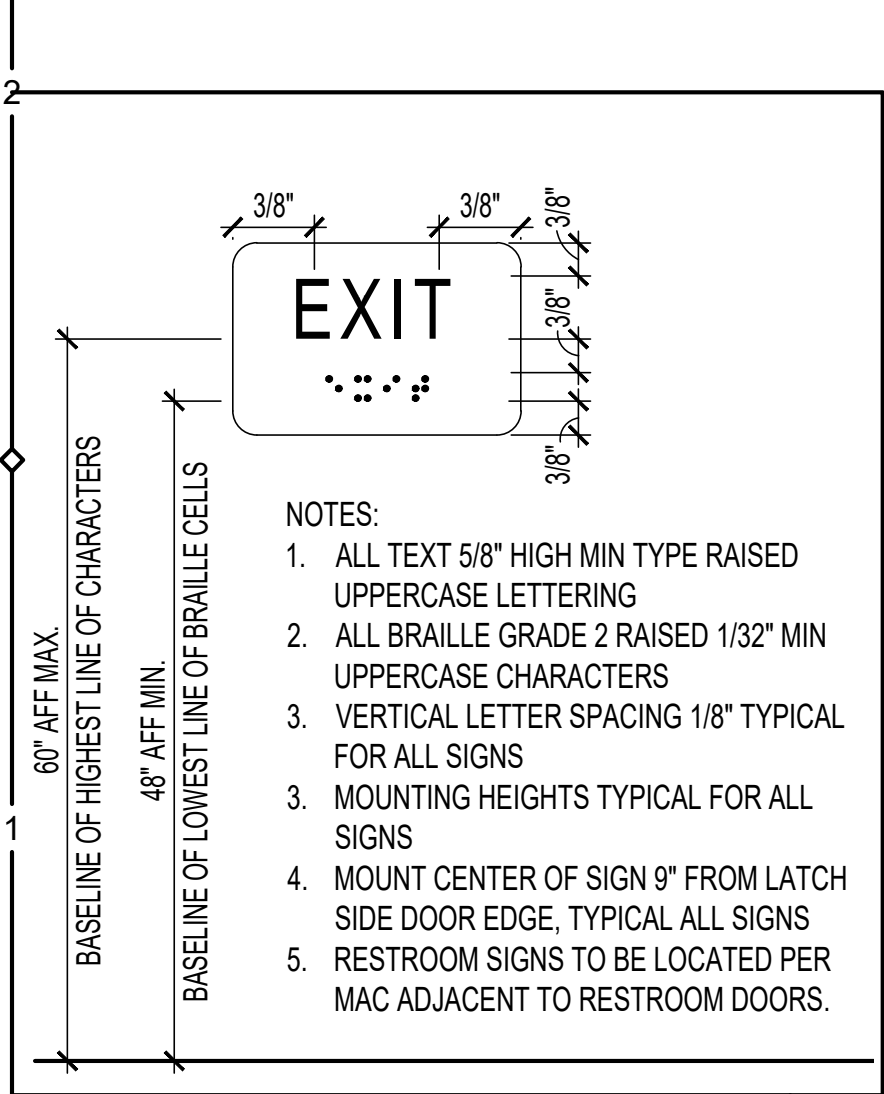


SIGN MOUNTING DETAIL G1

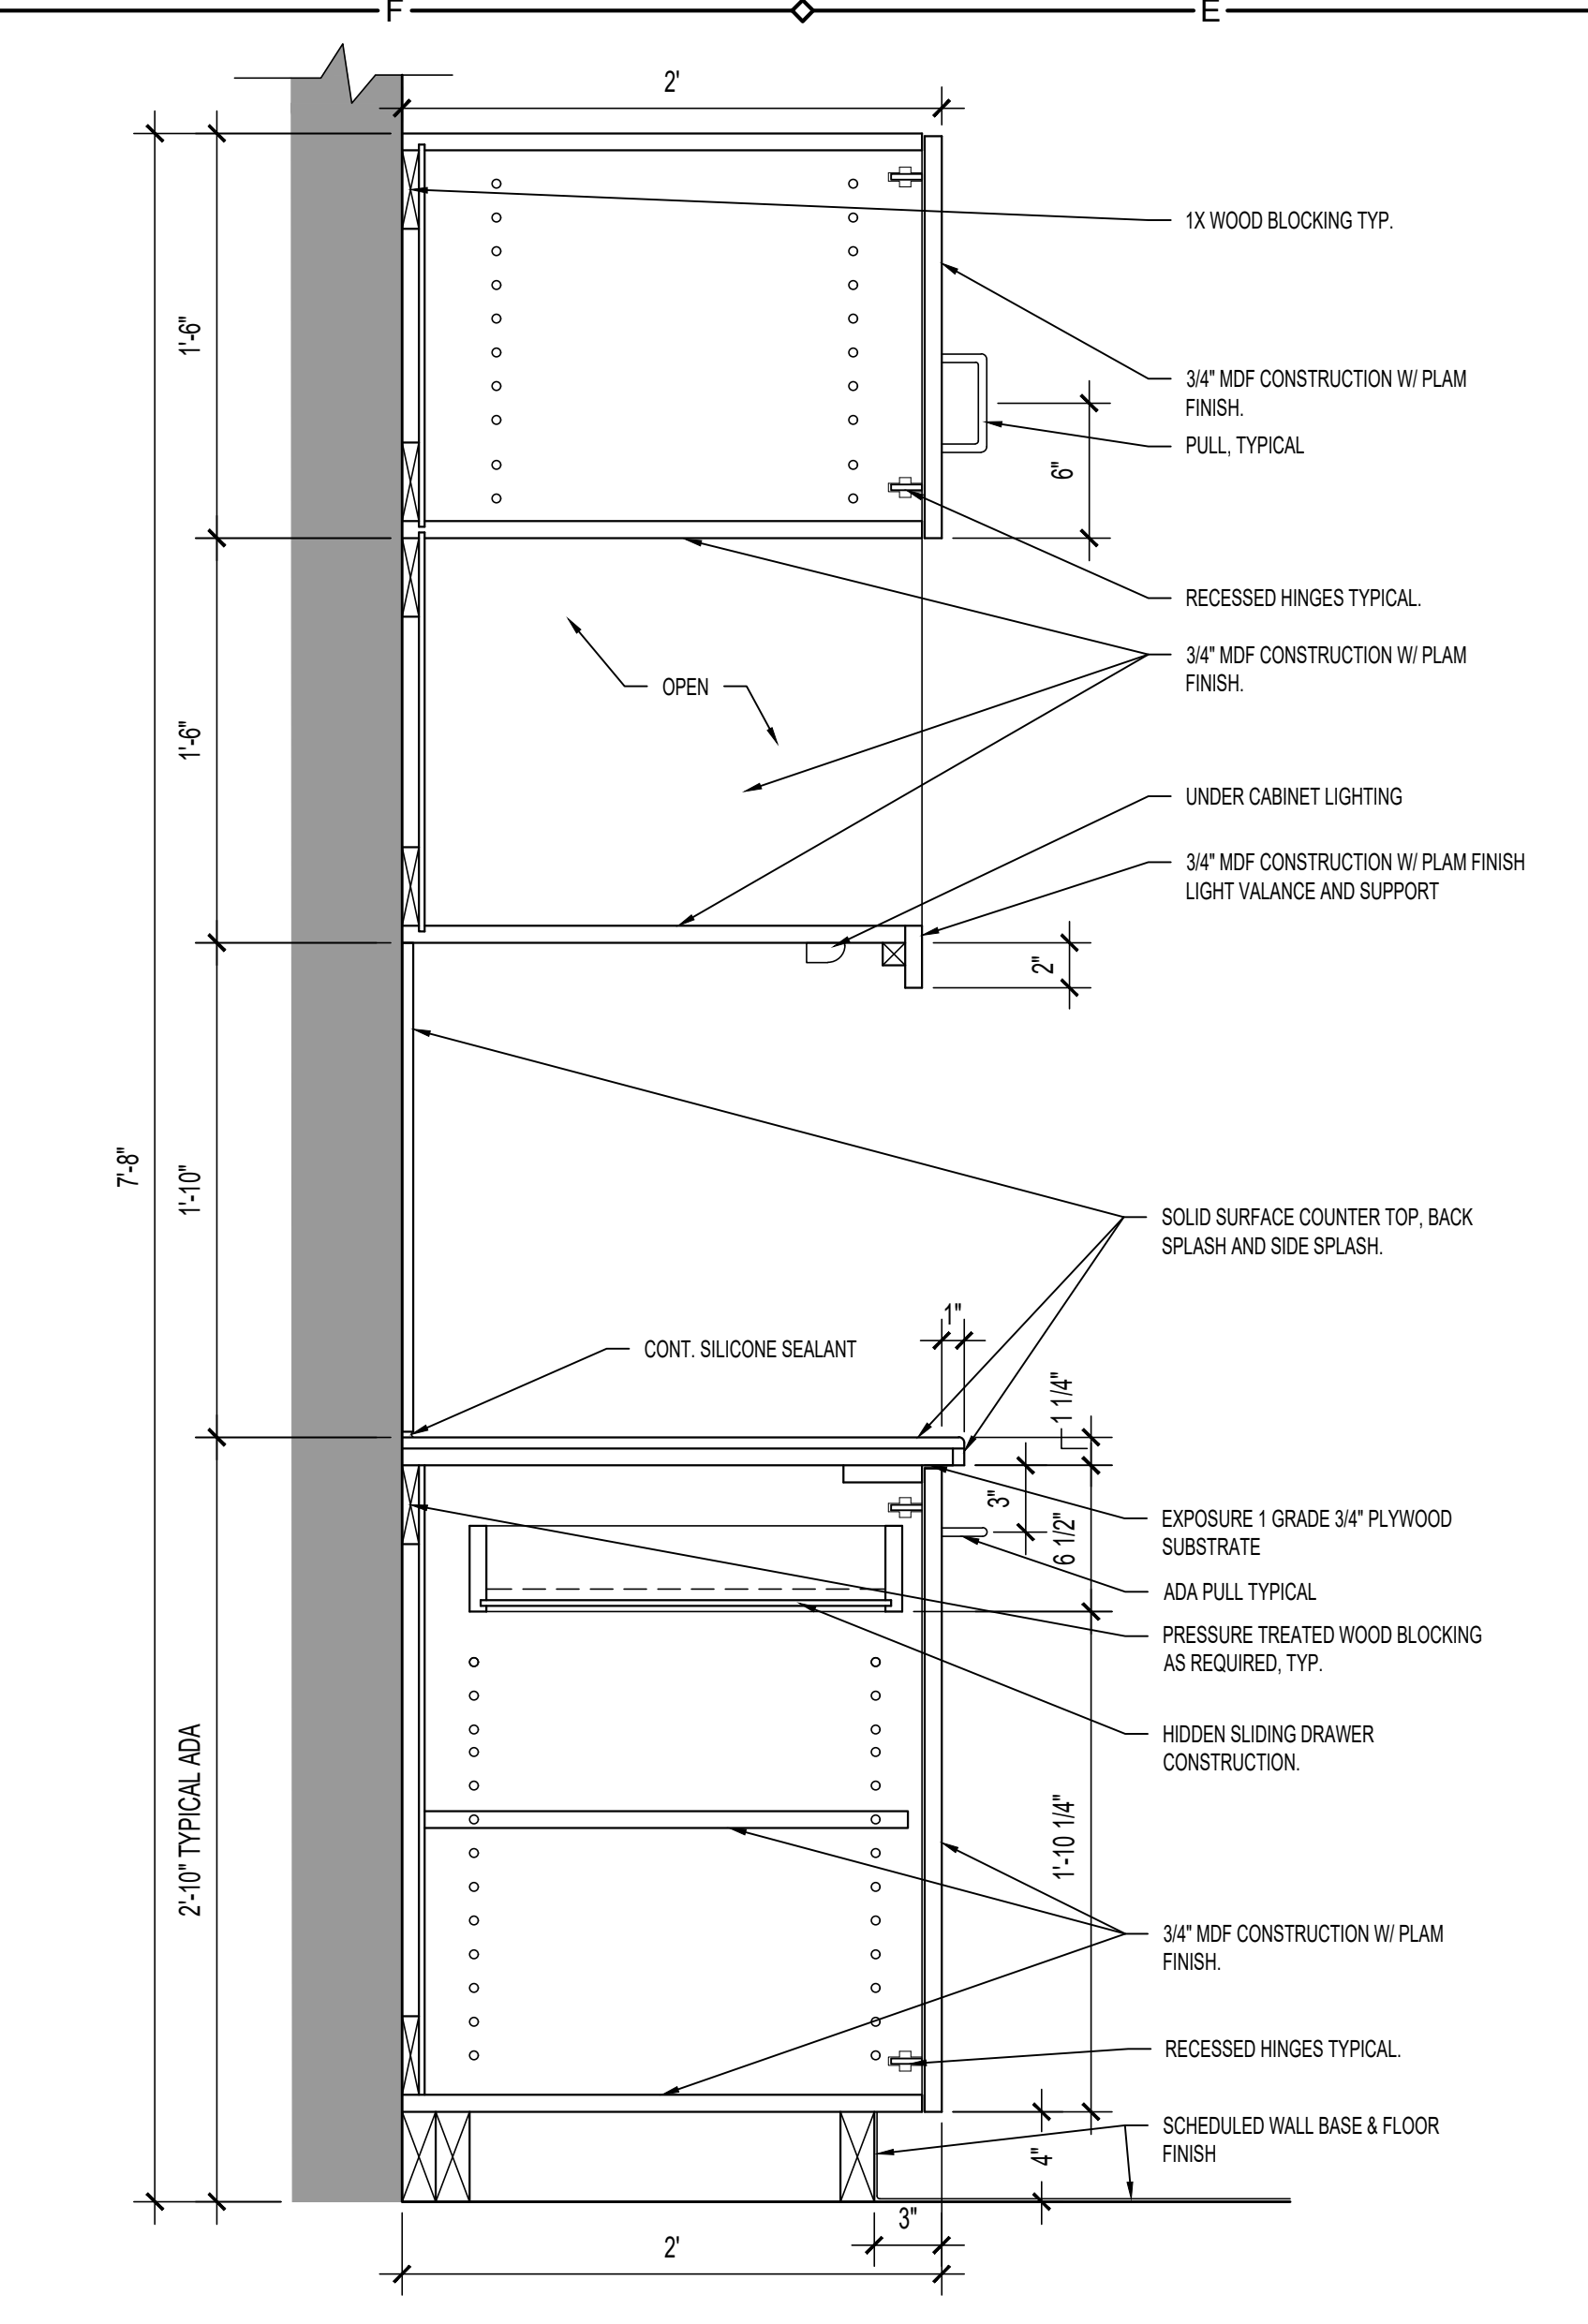


BASE AND WALL CAB DETAIL E3

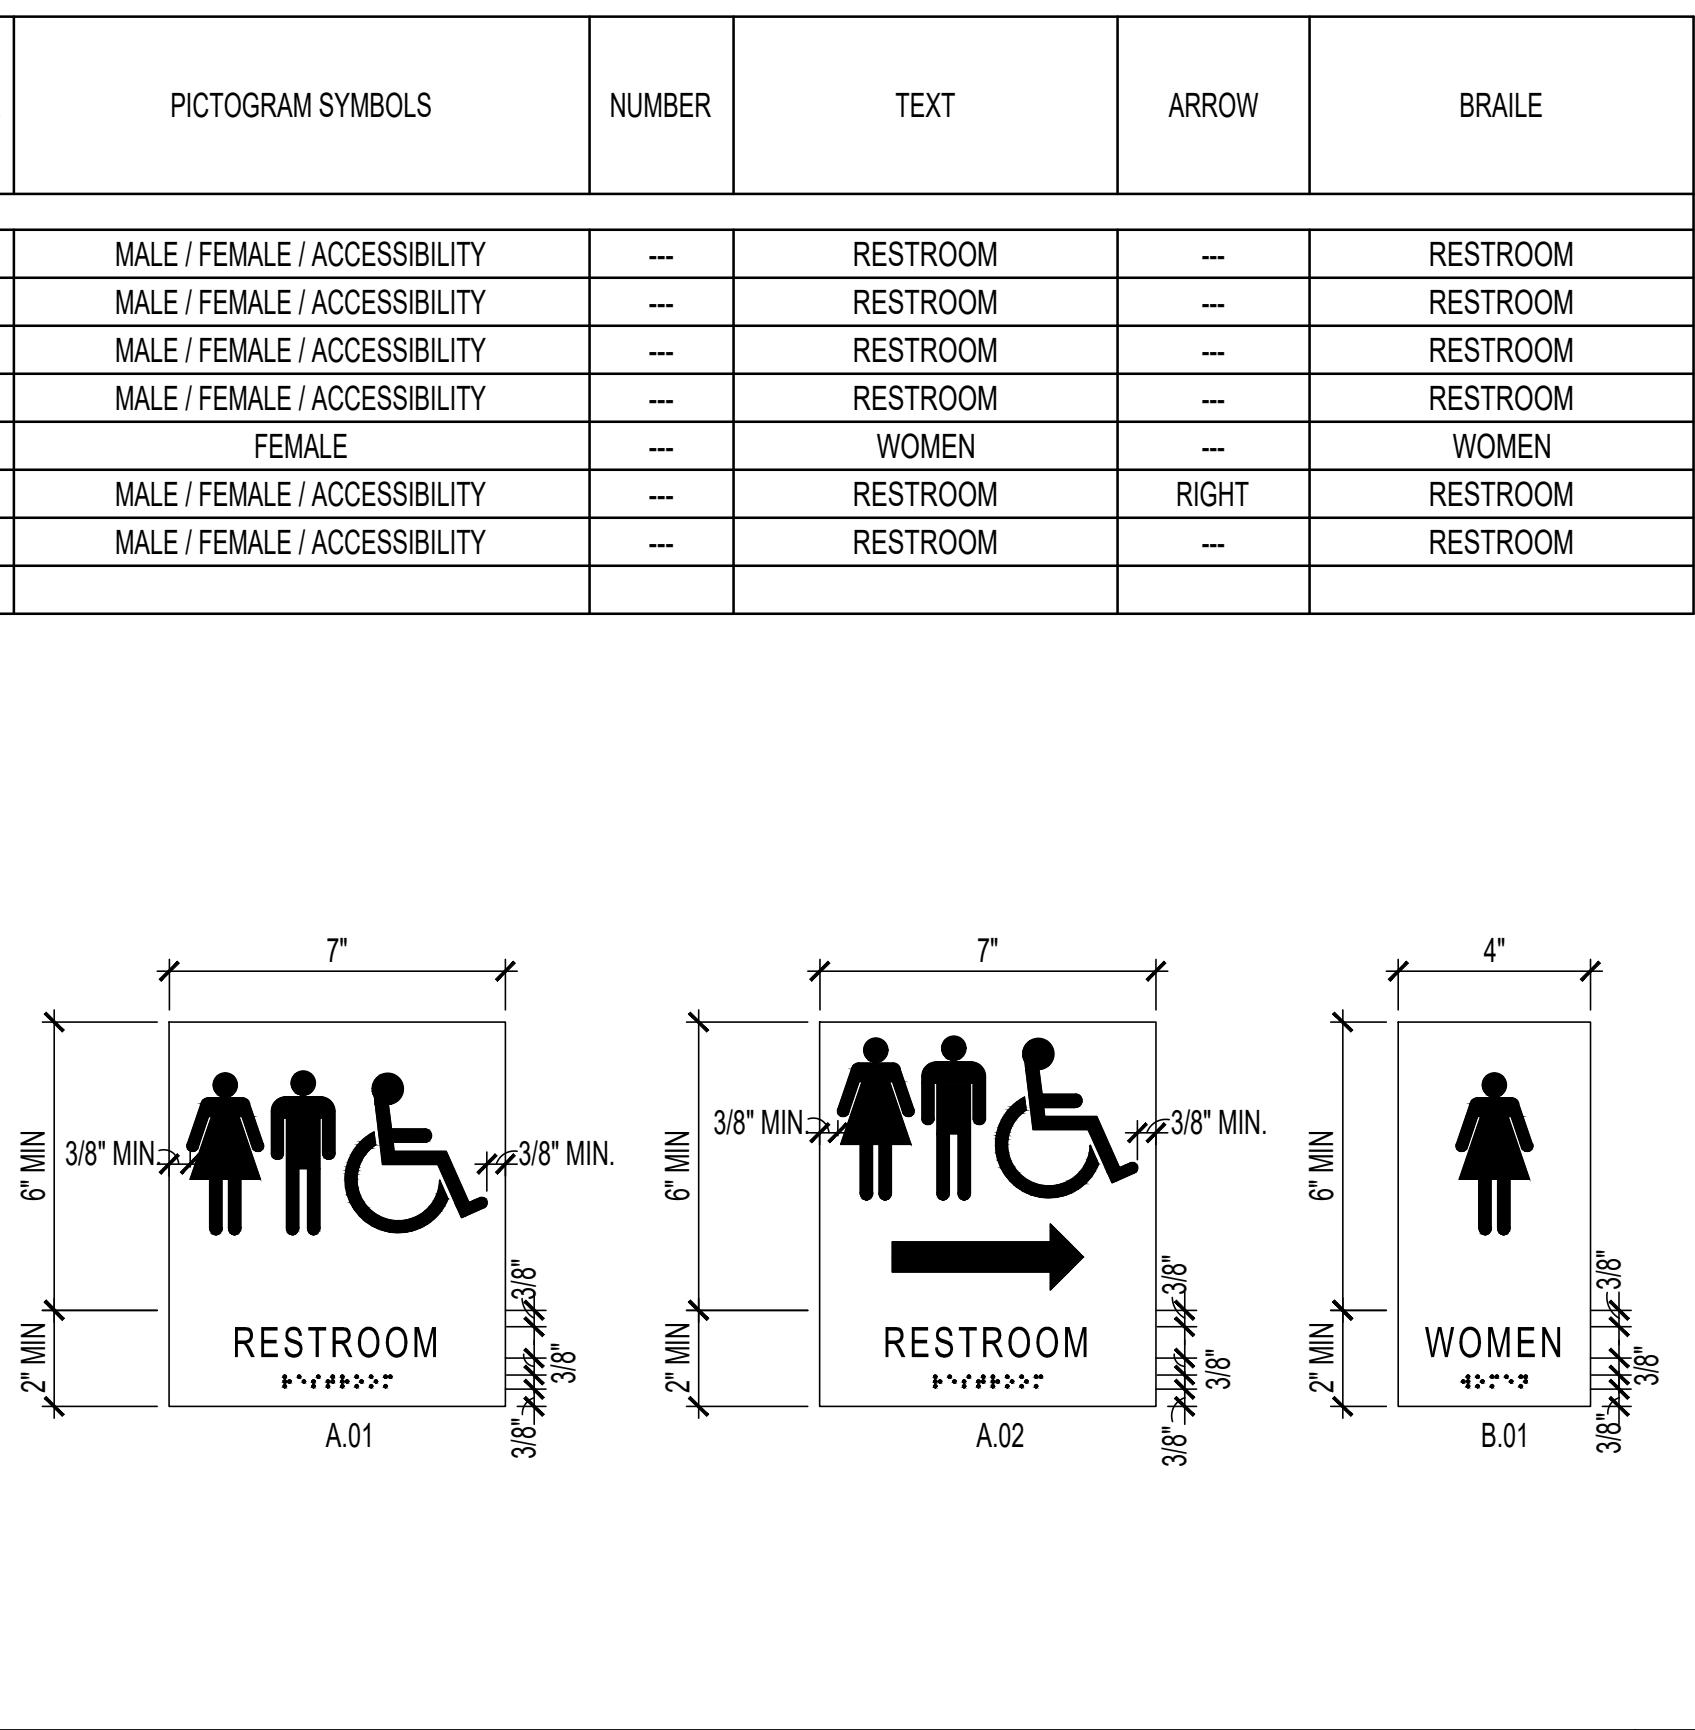


SIGN SCHEDULE E1

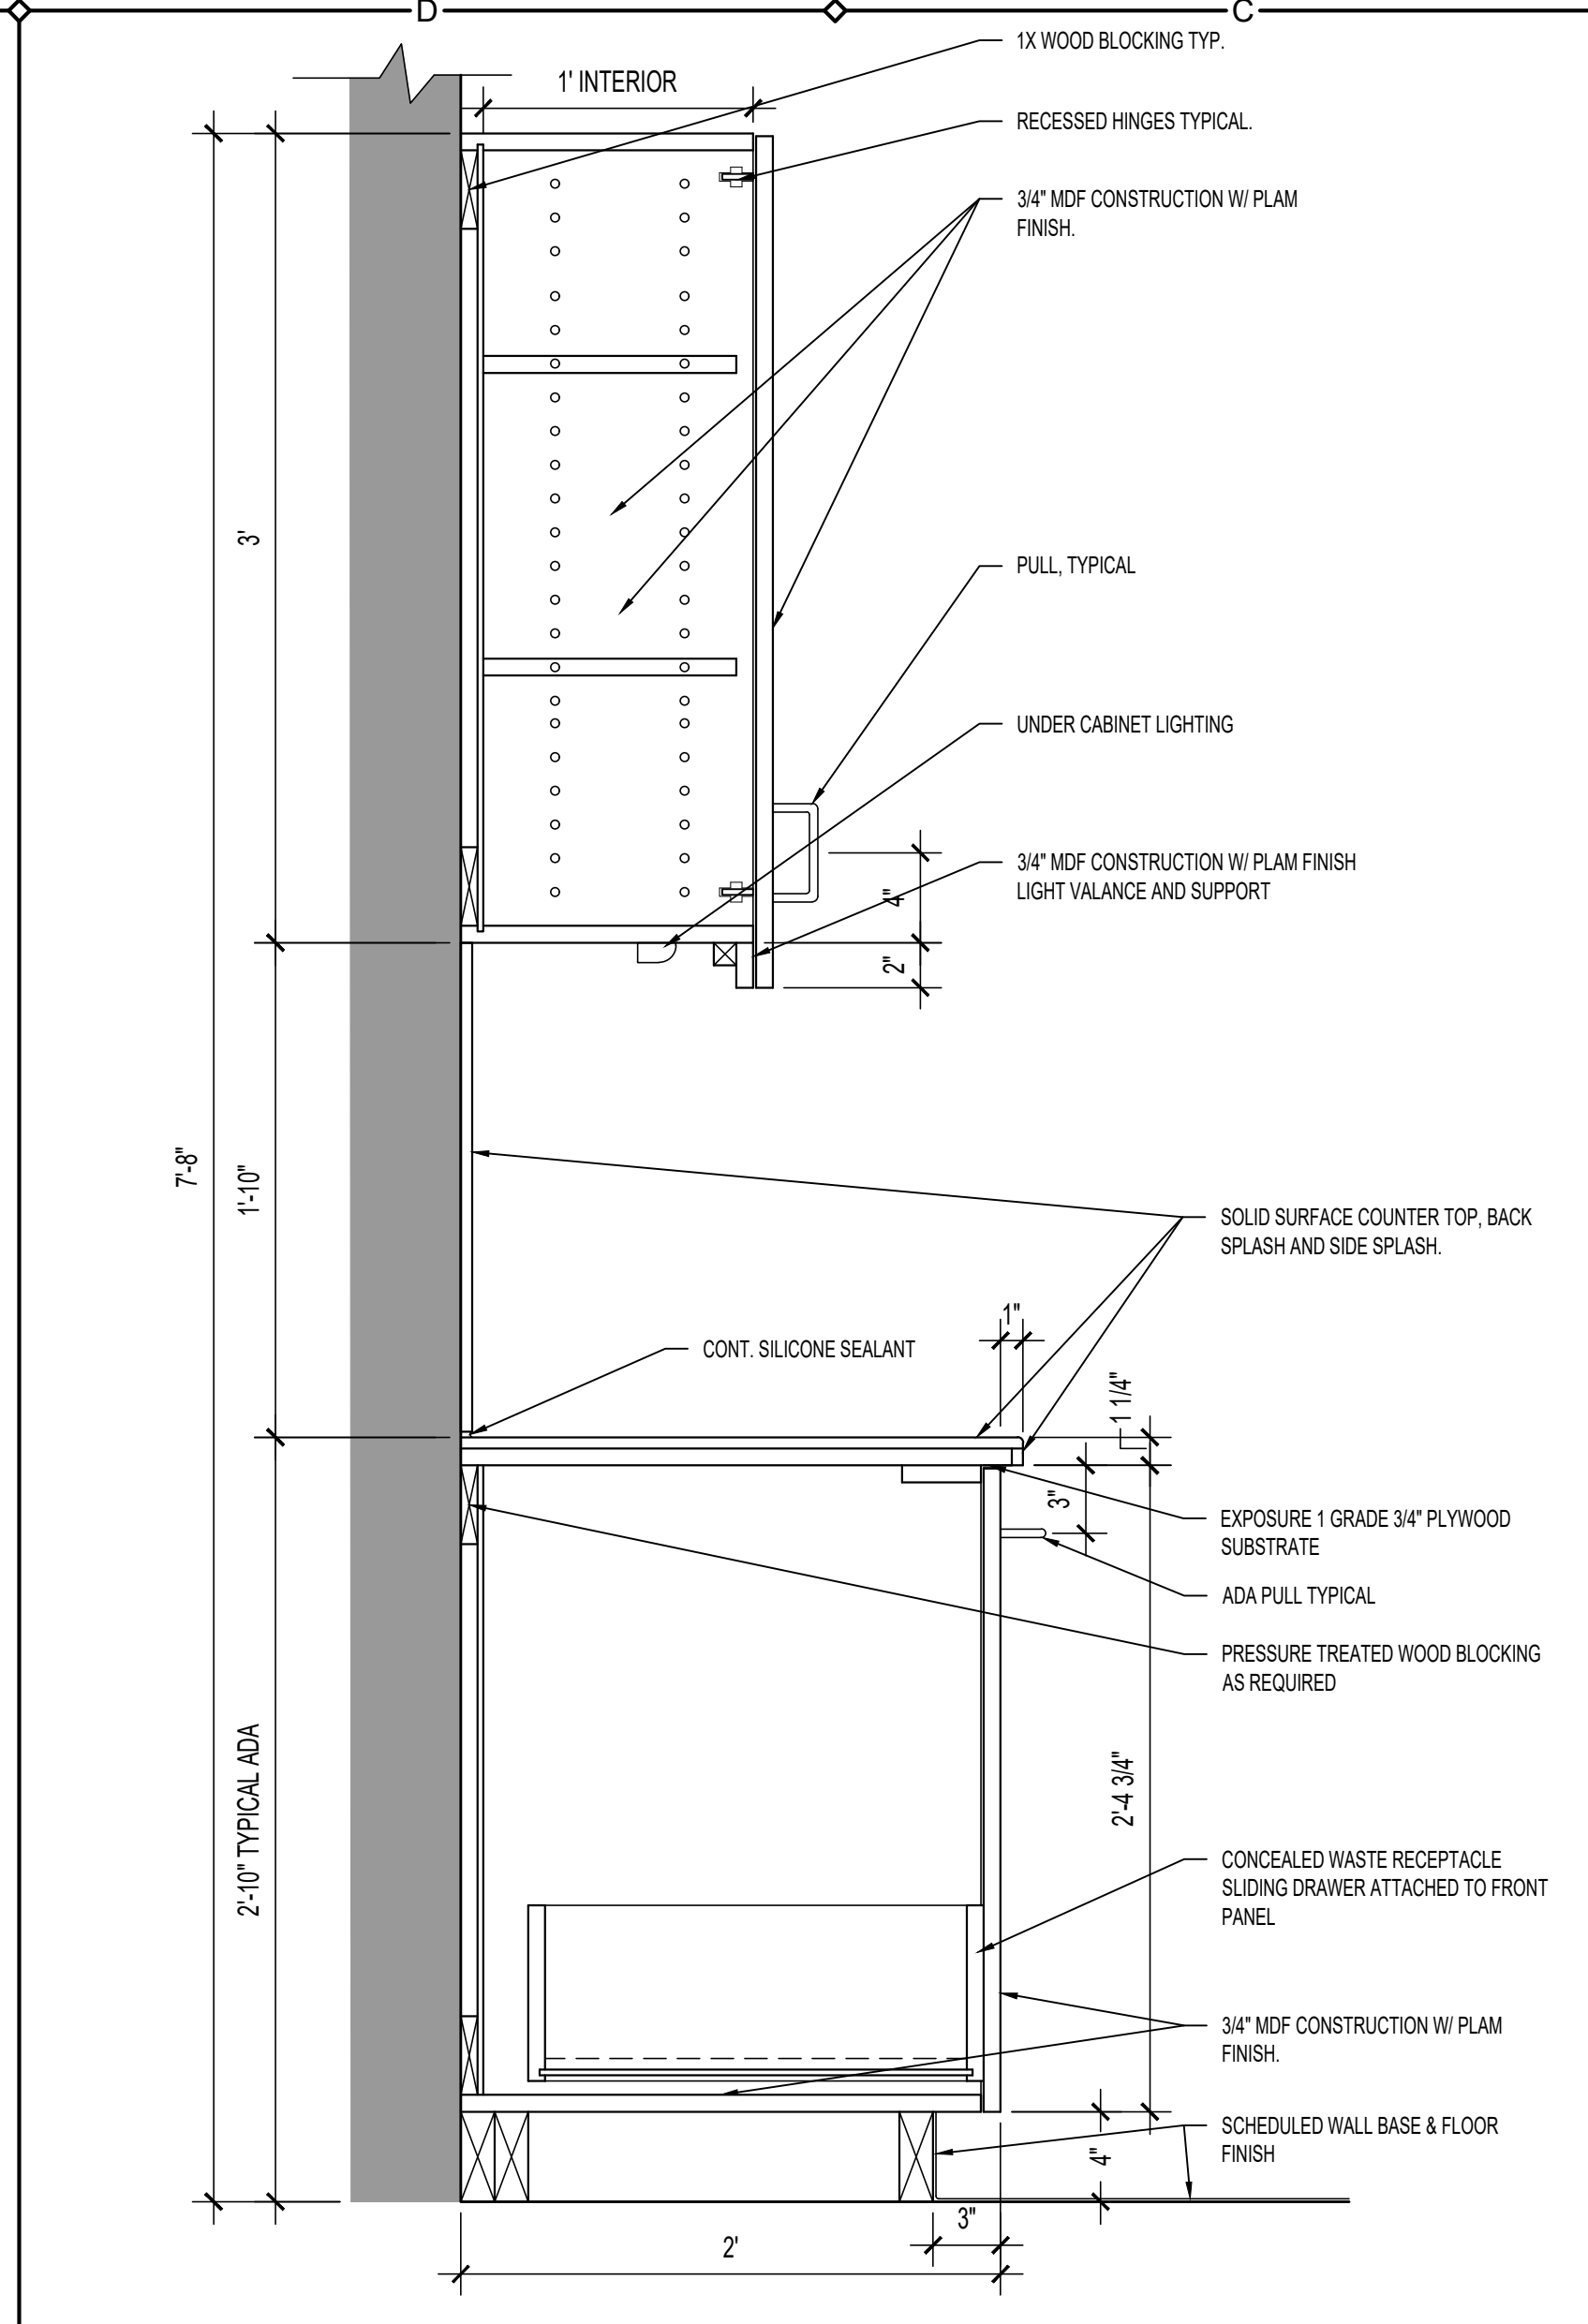


BASE AND WALL CAB DETAIL C3

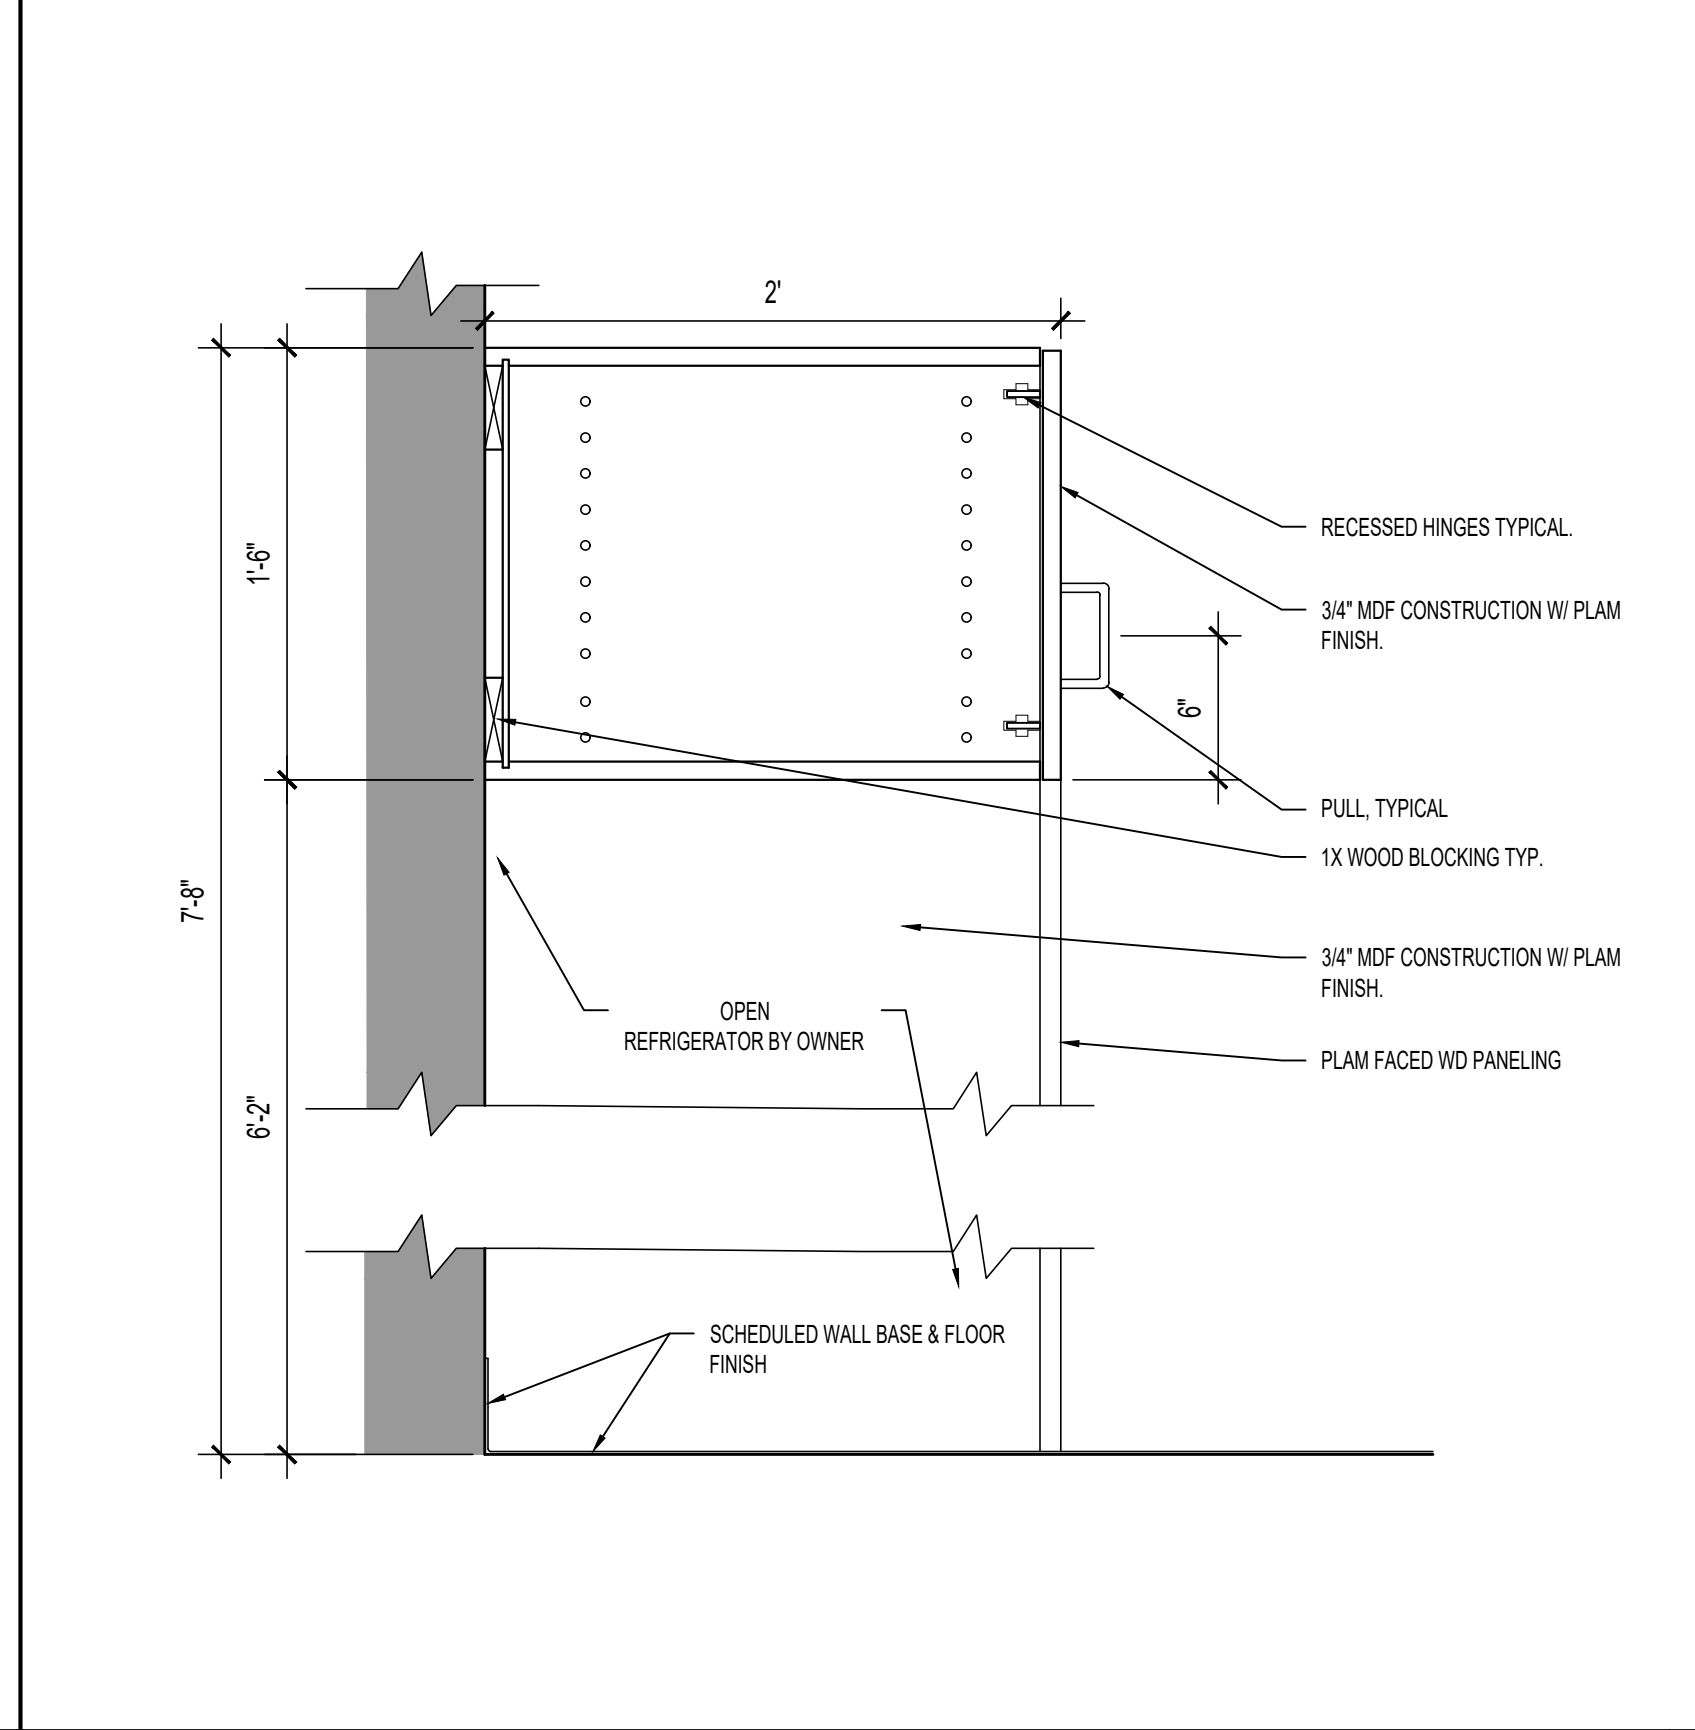

WALL CAB DETAIL C1

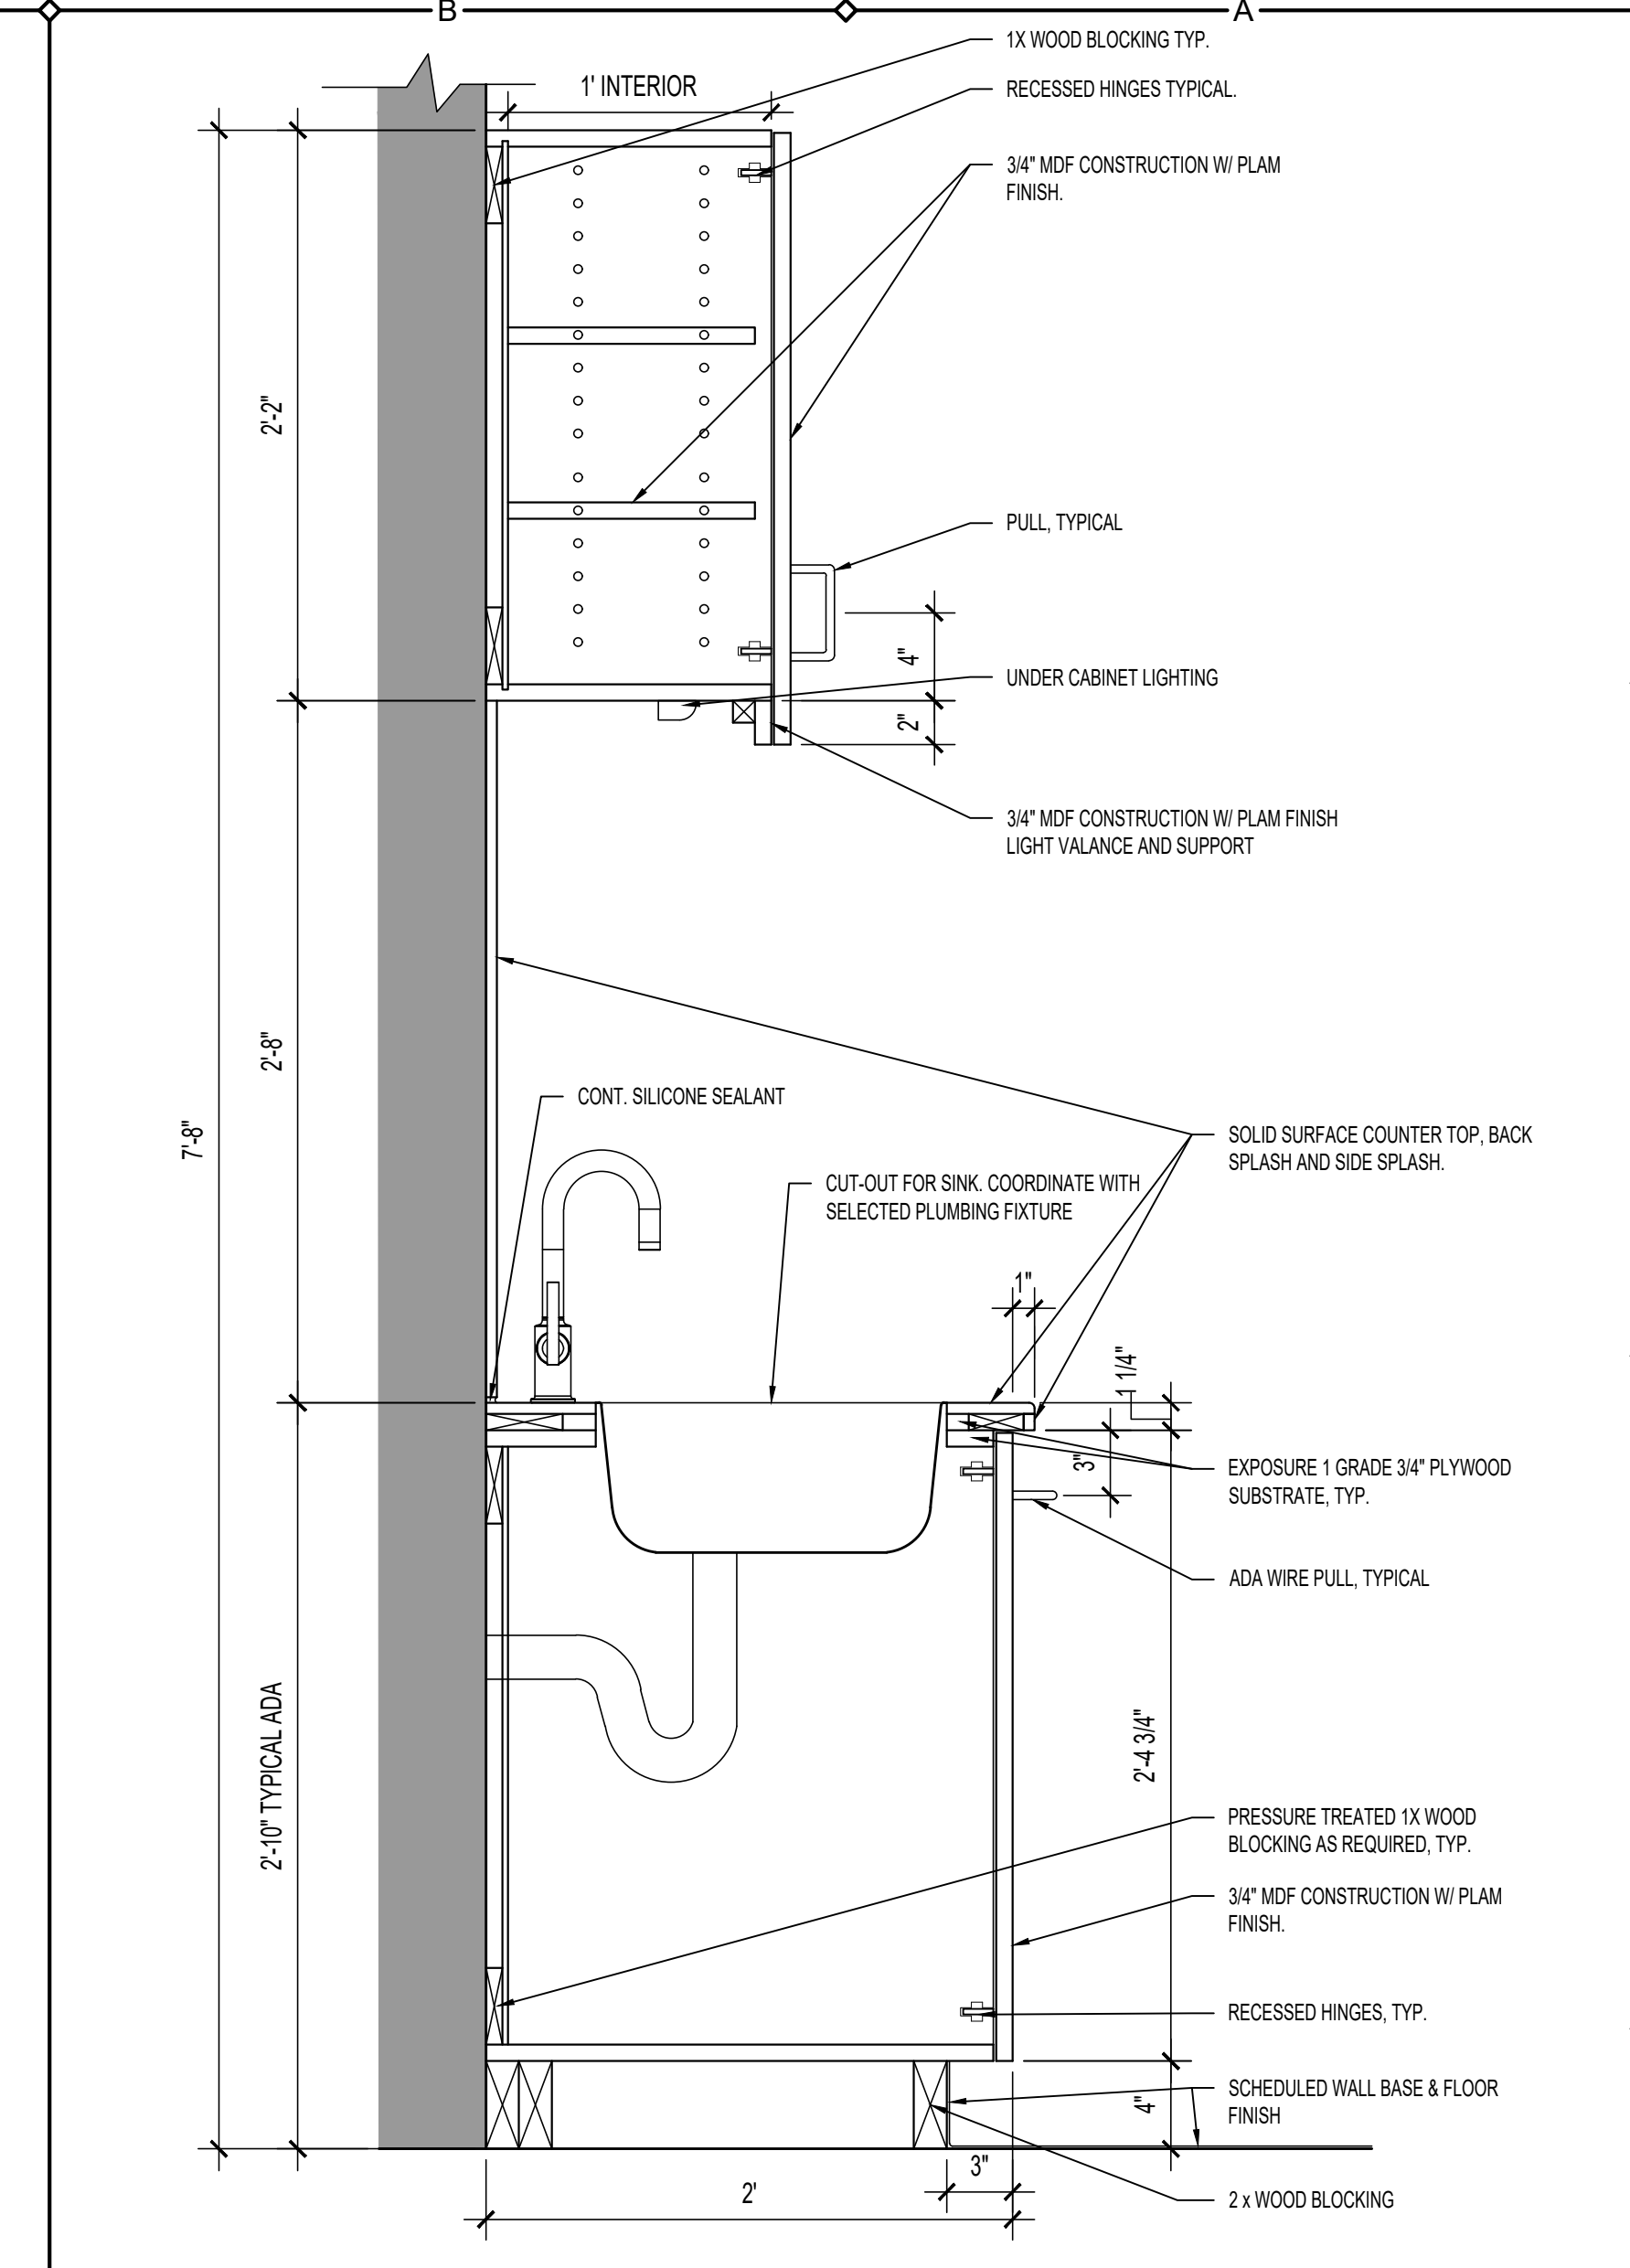

BASE AND WALL CAB DETAIL A3

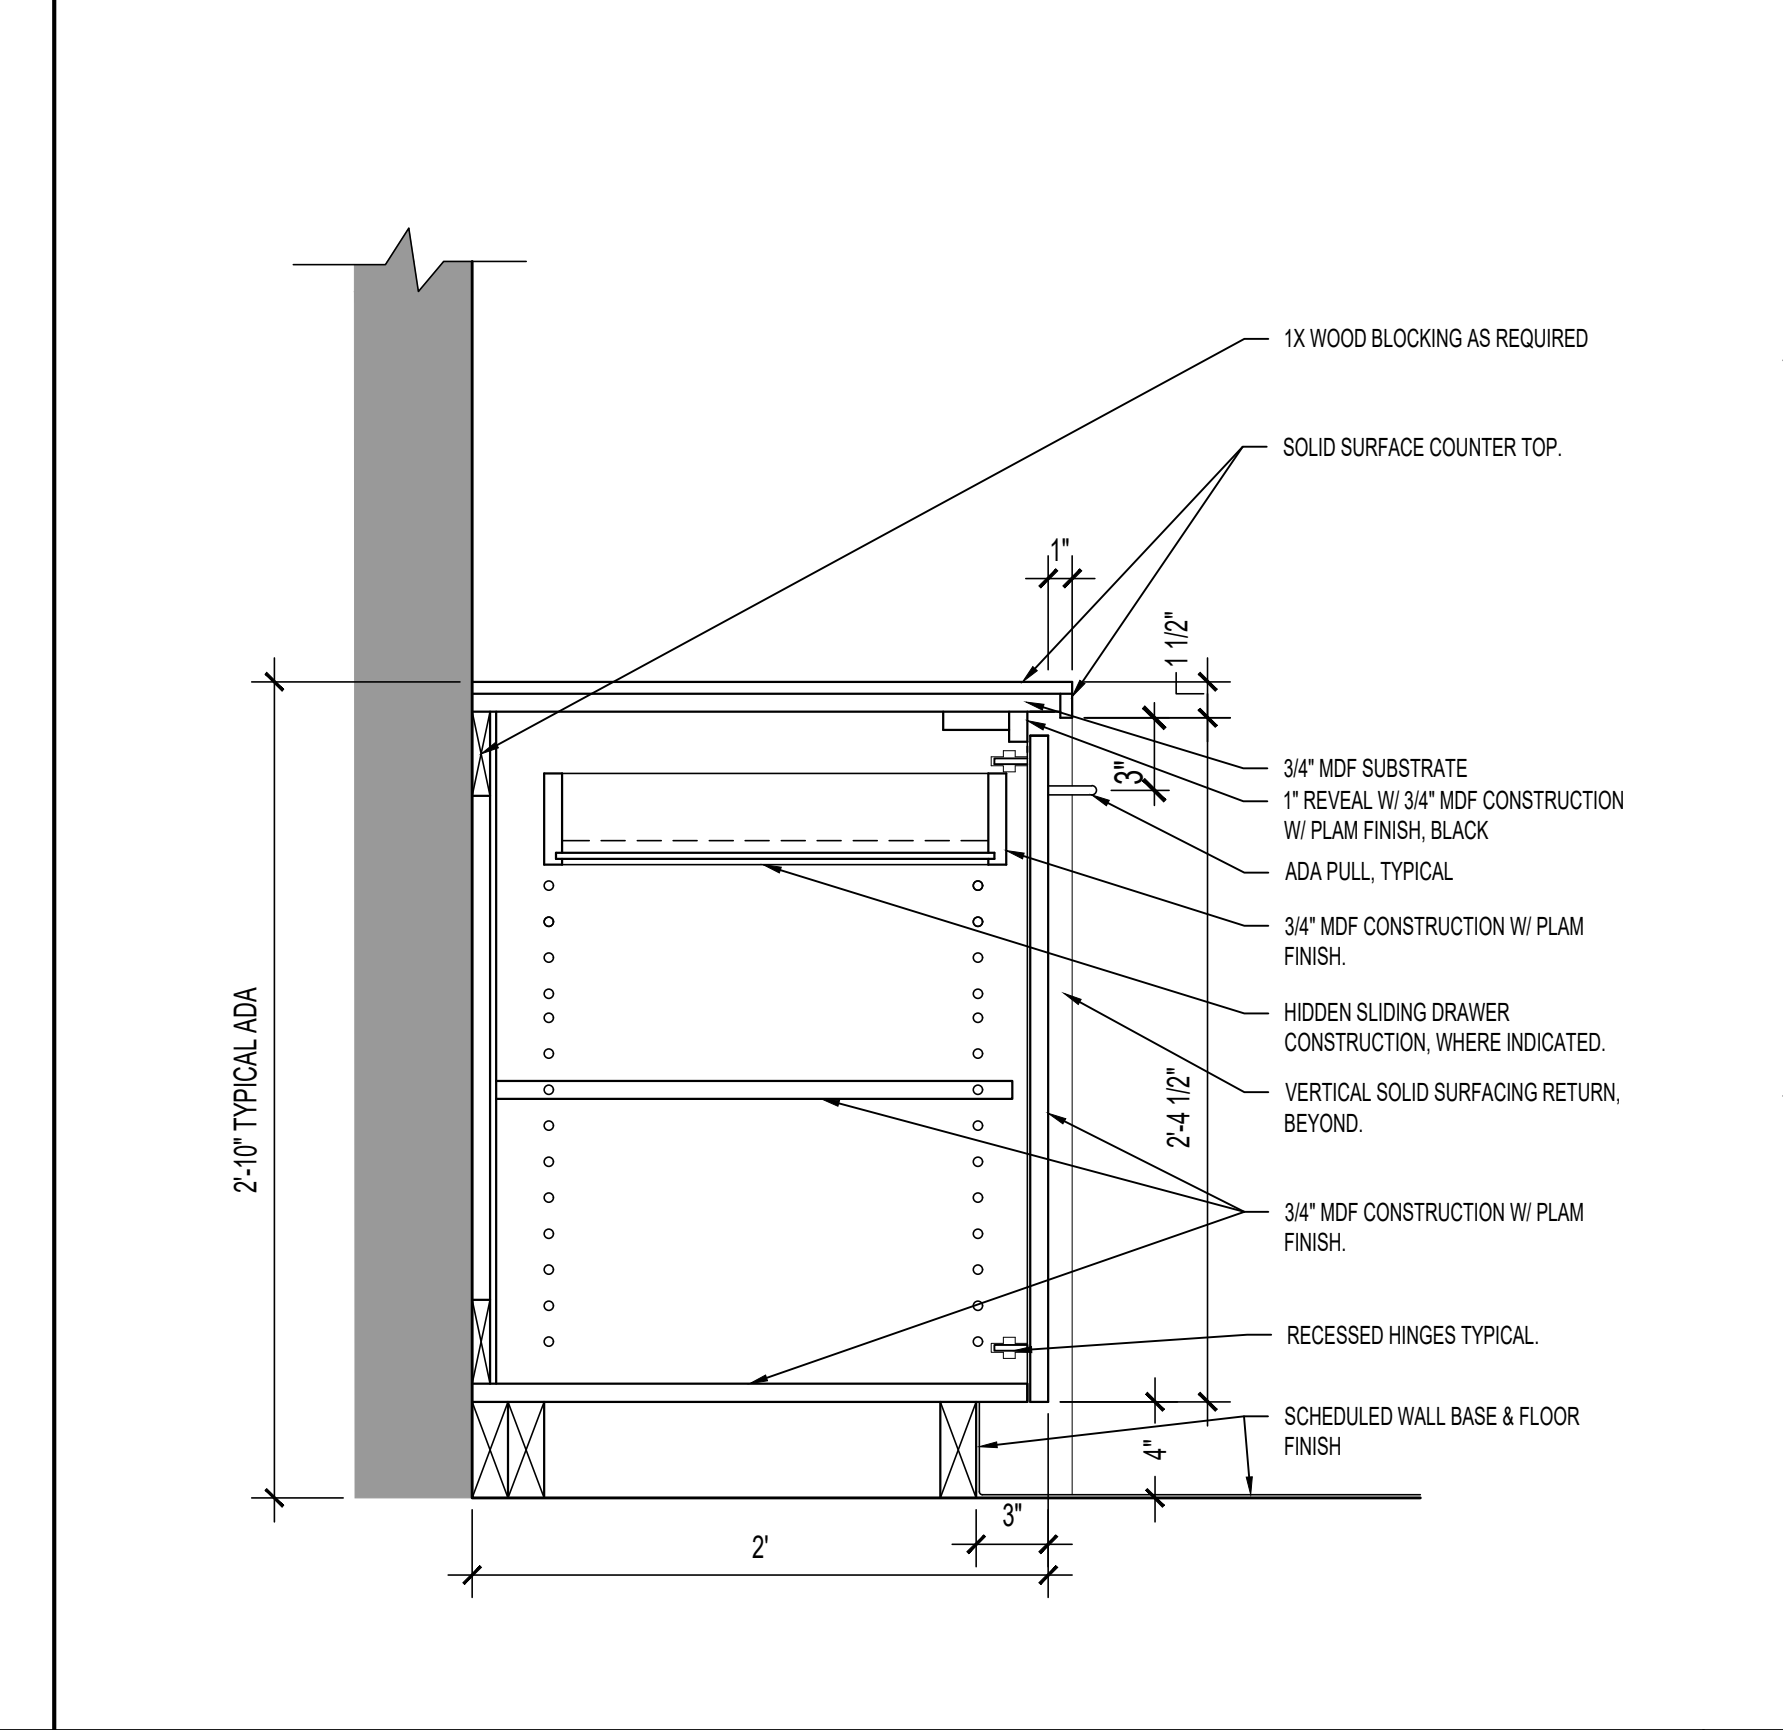

CONF. BASE CAB DETAIL A1

FARMERS & MERCHANTS
BANK
25 WESTMINSTER PIKE
REISTERTOWN, MARYLAND, 21136
INTERIOR ALTERATION

I CERTIFY THAT THESE DOCUMENTS WERE PREPARED OR APPROVED BY ME AND THAT I AM A DULY LICENSED ARCHITECT UNDER THE LAWS OF THE STATE OF MARYLAND.

LICENSE NO.: 8586
EXP. DATE: 21 MAY 2027

THESE DRAWINGS ARE NOT PERMITTED TO BE COPIED OR REPRODUCED, EITHER WHOLLY OR PARTIALLY, UNLESS WRITTEN PERMISSION IS FIRST OBTAINED FROM SANDERS DESIGNS, P.A.

SANDERS | DESIGNSP
ARCHITECTS PLANNERS
MAILBOX@SANDERSDESIGNS.COM
WWW.SANDERSDESIGNS.COM
9727 GREENSIDE DRIVE, SUITE 202, COCKEYSVILLE, MARYLAND 21030
T: (410) 560 2624

No.	Date	Revision


Project No.: 26.102
Date: 29 SEPTEMBER 2026
Scale: 1-1/2" = 1'-0"
Edition: PERMIT SET

Drawing Name: MILLWORK DETAILS
Drawing Number: A702


GENERAL NOTES

- 1) THE DRAWINGS ARE DIAGRAMMATIC AND REPRESENT THE GENERAL LOCATION AND ARRANGEMENT OF EQUIPMENT AND SYSTEMS. EXACT LOCATIONS CAN NOT BE REPRESENTED ON THIS SIZE AND SCALE OF A DRAWING. THE CONTRACTOR SHALL CLOSELY COORDINATE EXACT LOCATIONS IN THE FIELD WITH THE OWNER, OTHER TRADES AND OTHER EQUIPMENT, PIPING, ETC. TO ENSURE A "CLEAN" AND "FUNCTIONING" INSTALLATION WITH MANUFACTURER REQUIRED CLEARANCES, ETC.
- 2) ALL ITEMS THAT ARE INDICATED IN "BOLD" SHALL BE CONSIDERED NEW UNLESS OTHERWISE NOTED.
- 3) CONTRACTOR TO INSTALL, SIZE AND TRAP REFRIGERANT PIPING PER THE MANUFACTURER'S RECOMMENDATIONS.
- 4) DUCTWORK SYSTEMS IN AREAS WITH DRYWALL CEILINGS/BULKHEADS SHALL BE BALANCED PRIOR TO CLOSING OF THE CEILING. ALL AIR DEVICES MOUNTED IN DRYWALL CEILING TO HAVE TRIM PANELS.
- 5) COORDINATE ALL CEILING MOUNTED AIR DEVICES WITH LIGHTING AND SPRINKLER HEAD LAYOUT. ADJUST AS REQUIRED TO CONFORM TO GENERAL PATTERN AS INDICATED ON THE MECHANICAL NEW WORK PLANS.
- 6) ALL EXISTING H.V.A.C. AND PIPING/PLUMBING INFORMATION SHOWN WAS OBTAIN FROM FIELD SURVEYS. CONTRACTOR MUST VERIFY THIS INFORMATION PRIOR TO ANY WORK BEING PERFORMED.
- 7) ANY ITEM (AIR DEVICES INCLUDED) NOT BEING REUSED SHALL BE TURNED OVER TO A BUILDING COORDINATOR FOR BUILDING STOCKPILE.
- 8) ANY CUTTING OR PATCHING OF THE ROOF TO BE DONE BY THE OWNER'S ROOFING CONTRACTOR SO NOT TO VOID ANY ORIGINAL WARRANTIES.
- 9) ALL DOMESTIC WATER PIPING SHALL BE INSTALLED ON THE WARM SIDE OF THE BUILDING INSULATION.
- 10) A STRUCTURAL ENGINEER IS TO VERIFY THE WEIGHTS AND LOCATIONS OF ALL ROOF MOUNTED HVAC EQUIPMENT PRIOR TO INSTALLATION.
- 11) PLUMBING ROUGH-IN CONNECTIONS ARE APPROXIMATE LOCATIONS. ALL ROUGH-IN CONNECTIONS TO BE COORDINATED IN THE FIELD BY THE PLUMBING CONTRACTOR.
- 12) ALL DUCTWORK WILL BE FABRICATED OF GALVANIZED SHEET METAL. ALL FABRICATION AND INSTALLATION DETAILS SHALL BE PER THE SMACNA SHEET METAL MANUAL.
- 13) ALL NEW SUPPLY AND RETURN AIR DUCTWORK WITHIN 10'-0" OF HVAC UNIT SHALL BE LINED WITH 1" INTERIOR LINING FOR SOUND AND THERMAL INSULATION. DUCT SIZES INDICATED ON DRAWINGS ARE CLEAR INSIDE DIMENSIONS. INCREASE DUCT SIZES 2" IN EACH DIRECTION TO ACCOMMODATE LINING.
- 14) ALL UNLINED SUPPLY AND RETURN AIR DUCTWORK SHALL BE INSULATED WITH 2" FIBERGLASS DUCTWRAP WITH VAPOR BARRIER.
- 15) ALL H.V.A.C. EQUIPMENT SHALL BE PROVIDE COMPLETE WITH CONTROLS, THERMOSTATS AND FAN SWITCHES WHERE LOCATED ON DRAWINGS.
- 16) SUPPLY AIR DIFFUSERS, RETURN AIR GRILLES/REGISTERS AND EXHAUST AIR DEVICES SHALL HAVE SIZES AND QUANTITIES AS INDICATED ON DRAWINGS. ALL AIR DEVICES SHALL HAVE STEEL CONSTRUCTION AND OFF-WHITE BAKED ENAMEL FINISH.
- 17) ALL ITEMS AND EQUIPMENT AS SHOWN AND SCHEDULED SHALL BE INSTALLED WITH CAPACITIES AS SCHEDULED. ALL MANUFACTURES SHALL BE EQUAL TO THOSE INDICATED.
- 18) ALL SERVICE VALVES, UNIONS, GAS COCKS, ETC., SHALL BE MANUFACTURED BY NIBCO OR EQUAL.
- 19) ALL DOMESTIC WATER PIPING SHALL BE INSULATED WITH 1" PRE-MOLDED FIBERGLASS INSULATION WITH AN ALL SERVICE JACKET. FITTINGS SHALL BE INSULATED WITH FIBERGLASS AND COVERED WITH PVC JACKETS.
- 20) ALL SANITARY PIPING LOCATED ABOVE FOOD STORAGE RACKS, ABOVE FOOD PREPERATION AREAS OR ABOVE FOOD SERVING AREAS SHALL BE COPPER PIPE WITH SOLDERED COPPER DRAINAGE AND WASTE FITTINGS.
- 21) ALL REFRIGERANT PIPING SHALL BE WRAPPED WITH 1-1/2" ARMAFLEX INSULATION.
- 22) ALL SANITARY PIPING SHALL BE SLOPED AT MINIMUM 1/8" PER FOOT. ALL SANITARY PIPING 2" AND SMALLER SHALL BE SLOPED AT 1/4" PER FOOT.
- 23) ALL INDIRECT PIPING THAT IS EQUAL OR GREATER THEN 4'-0" LONG SHALL BE PROVIDED WITH TRAP AT EQUIPMENT CONNECTION.
- 24) THE CONTRACTOR SHALL COORDINATE THE DRAWINGS BETWEEN ALL SUB CONTRACTORS FOR CONFLICT AND NOTIFY THE ARCHITECT PRIOR TO BID OF ANY DISCREPANCIES AND/OR CONFLICTS BEFORE PROCEEDING WITH THE BID. CONTRACTOR SHALL ALSO VERIFY ALL DIMENSIONS AND CONDITIONS SHOWN ON DRAWINGS AT THE JOB SITE AND SHALL NOTIFY THE ARCHITECT AND THE OWNER OF ANY DISCREPANCIES, OMISSIONS, AND/OR CONFLICT BEFORE PROCEEDING WITH THE PROJECT. TO THE EXTENT THAT THE CONTRACTOR DISCOVERS ANY SUCH DISCREPANCIES AND FAILS TO NOTIFY THE ARCHITECT, NO EXCUSE WILL BE ENTERTAINED FOR FAILURE TO CARRY OUT THE WORK IN A SATISFACTORY MANNER ACCEPTABLE TO THE ARCHITECT AND THE OWNER.
- 25) ALL WORK SHALL CONFORM TO ALL APPLICABLE FEDERAL, STATE AND LOCAL BUILDING CODES. CONTRACTOR SHALL REVIEW THE DESIGN FOR CODE COMPLIANCE DURING THE BIDDING PROCESS. TO THE EXTENT CONTRACTOR DISCOVERS CODE DISCREPANCIES AND FAILS TO NOTIFY THE ARCHITECT, NO EXCUSE WILL THEREAFTER BE ENTERTAINED FOR FAILURE TO CARRY OUT THE WORK IN A SATISFACTORY MANNER ACCEPTABLE TO THE ARCHITECT AND THE OWNER.
- 26) THE GENERAL CONTRACTOR SHALL BE RESPONSIBLE FOR REMOVAL AND DISPOSAL OF ALL CONSTRUCTION DEBRIS AND REFUSE FROM THE JOB SITE.
- 27) UPON COMPLETION OF THE WORK, THE GENERAL CONTRACTOR SHALL PREPARE A PUNCH LIST FIRST AND NOTIFY ARCHITECT TO REVIEW AND VERIFY PUNCH-LIST FOR CORRECTIONS.

MECHANICAL LEGEND

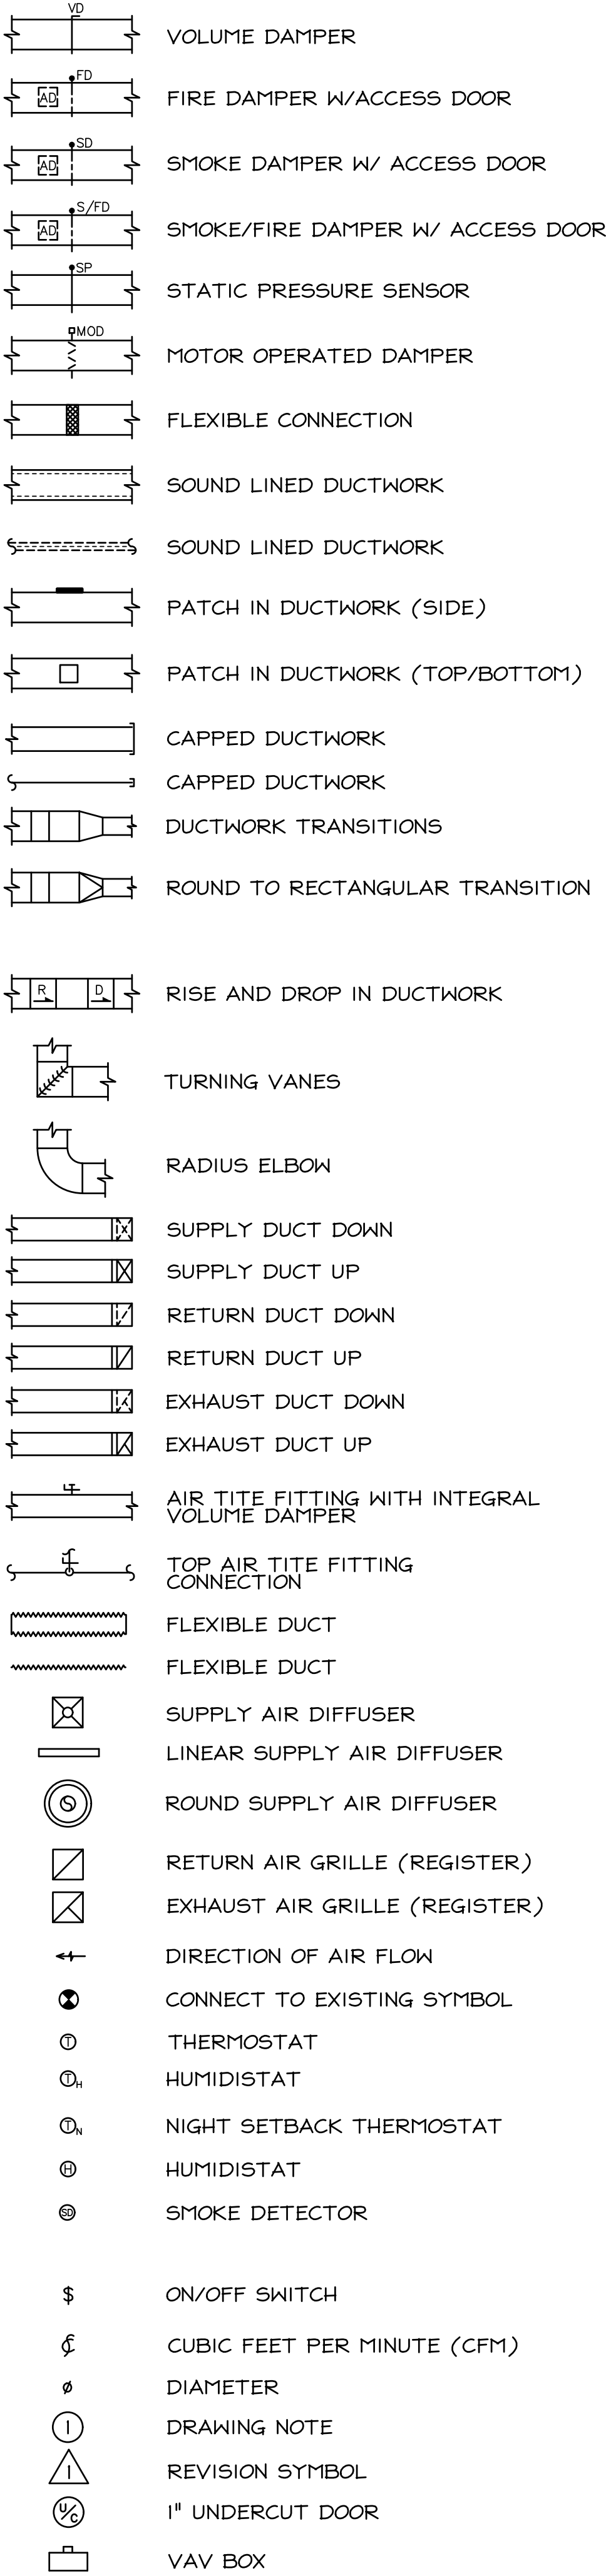


PIPING LEGEND

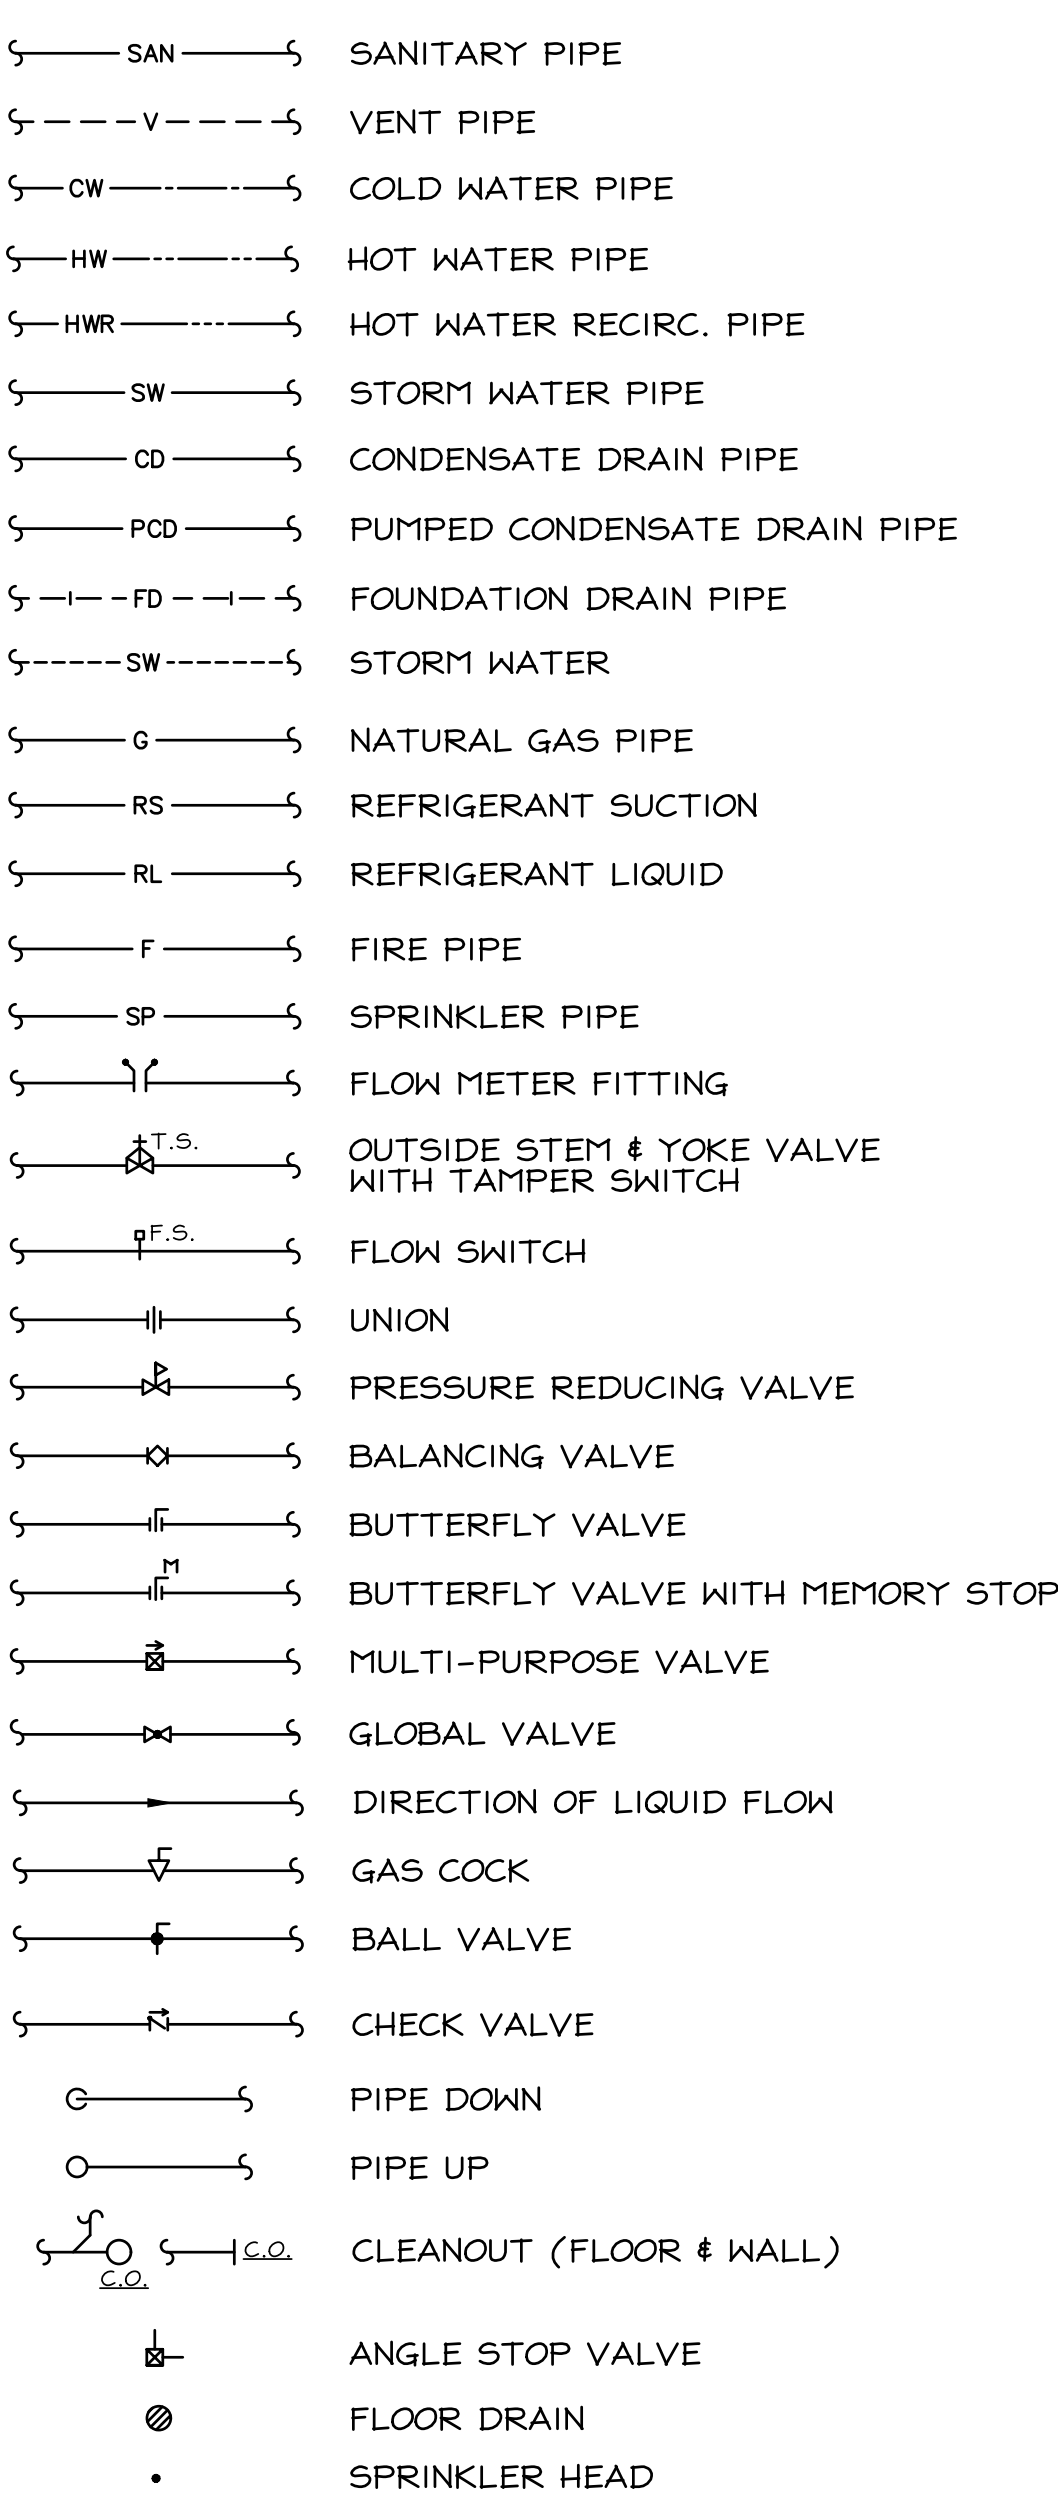

ABBREVIATIONS LIST

A.H.U.	AIR HANDLING UNIT
C.F.M.	CUBIC FEET PER MINUTE
E.A.T.	ENTERING AIR TEMPERATURE
L.A.T.	LEAVING AIR TEMPERATURE
E.W.T.	ENTERING WATER TEMPERATURE
L.W.T.	LEAVING WATER TEMPERATURE
EX.	EXISTING
F.D.	FLOOR DRAIN
F.S.	FLOOR SINK
F.P.M.	FEET PER MINUTE
F.O.	FLAT OVAL
FT.	FOOT
FT ²	SQUARE FEET
HP	HORSEPOWER
LBS.	POUNDS
LBS/HR	POUNDS PER HOUR
R.L.	RAIN LEADER
R.T.U.	ROOF TOP UNIT
RX.	REMOVE EXISTING
TYP.	TYPICAL
V.T.R.	VENT THRU ROOF

FARMERS & MERCHANTS
BANK
25 WESTMINSTER PIKE
REISTERTOWN, MARYLAND, 21136
INTERIOR ALTERATION

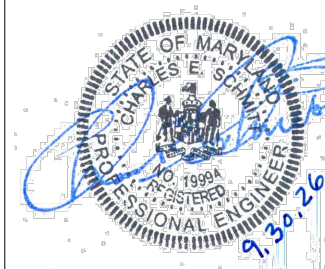

I CERTIFY THAT THESE DOCUMENTS WERE PREPARED OR APPROVED BY ME AND THAT I AM A DULY LICENSED PROFESSIONAL ENGINEER UNDER THE LAWS OF THE STATE OF MARYLAND.

LICENSE NO.: 19994

EXP. DATE: 3/31/2027

THESE DRAWINGS ARE NOT PERMITTED TO BE COPIED OR REPRODUCED, EITHER WHOLLY OR PARTIALLY, UNLESS WRITTEN PERMISSION IS FIRST OBTAINED FROM SANDERS DESIGNS, P.A.

MECHANICAL & ELECTRICAL
DESIGN CONSULTANTS, INC.
1907 N. Fountain Green Road
Bel Air, Maryland 21015-1411
410-869-2822 • Fax 410-869-0442
Web Site: www.jrsdesign.net

SANDERS | DESIGNS
ARCHITECTS PLANNERS
WWW.SANDERSDESIGNS.COM
MAILBOX@SANDERSDESIGNS.COM
9727 GREENSIDE DRIVE, SUITE 202, COCKEYSVILLE, MARYLAND 21030 T: (410) 860 2624

No.	Date	Revision

Project No.:
Date:
Scale:
Edition:
PERMIT SET

Drawing Name:
GENERAL NOTES AND LEGEND
Drawing Number:

M-1


NOTICE TO CONTRACTORS:

ALL CONTRACTORS PRIOR TO BID SUBMISSION PROCESS SHALL VISIT PROPOSED WORK SITE AND FIELD VERIFY ALL EXISTING CONDITIONS. ANY CONDITIONS THAT DIFFERS FROM THAT SHOWN ON THIS PLAN SHALL BE REPORTED TO ARCHITECT/ENGINEER SO THAT NEW AND REVISED BID DRAWINGS OR INFORMATION MAY BE ISSUED. MODIFICATIONS TO SCOPE OF WORK WHICH RESULTS FROM CONTRACTORS NEGLECT TO VISIT THE SITE PRIOR TO SUBMITTING BID, SHALL BE THE CONTRACTORS SOLE RESPONSIBILITY.

M-2




- EXISTING - SECOND FLOOR - DOMESTIC WATER
SCALE: 1/4"=1'-0"

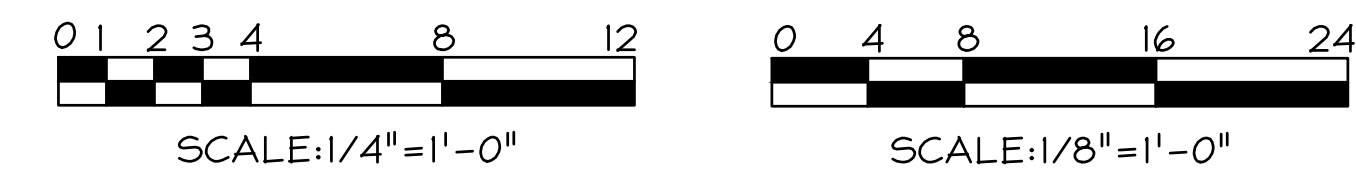


Project No.:	
Date:	
Scale:	
Condition:	
PERMIT SET	
Drawing Name:	
EXISTING AND DEMO FLOOR PLANS	
Drawing Number:	


M-3

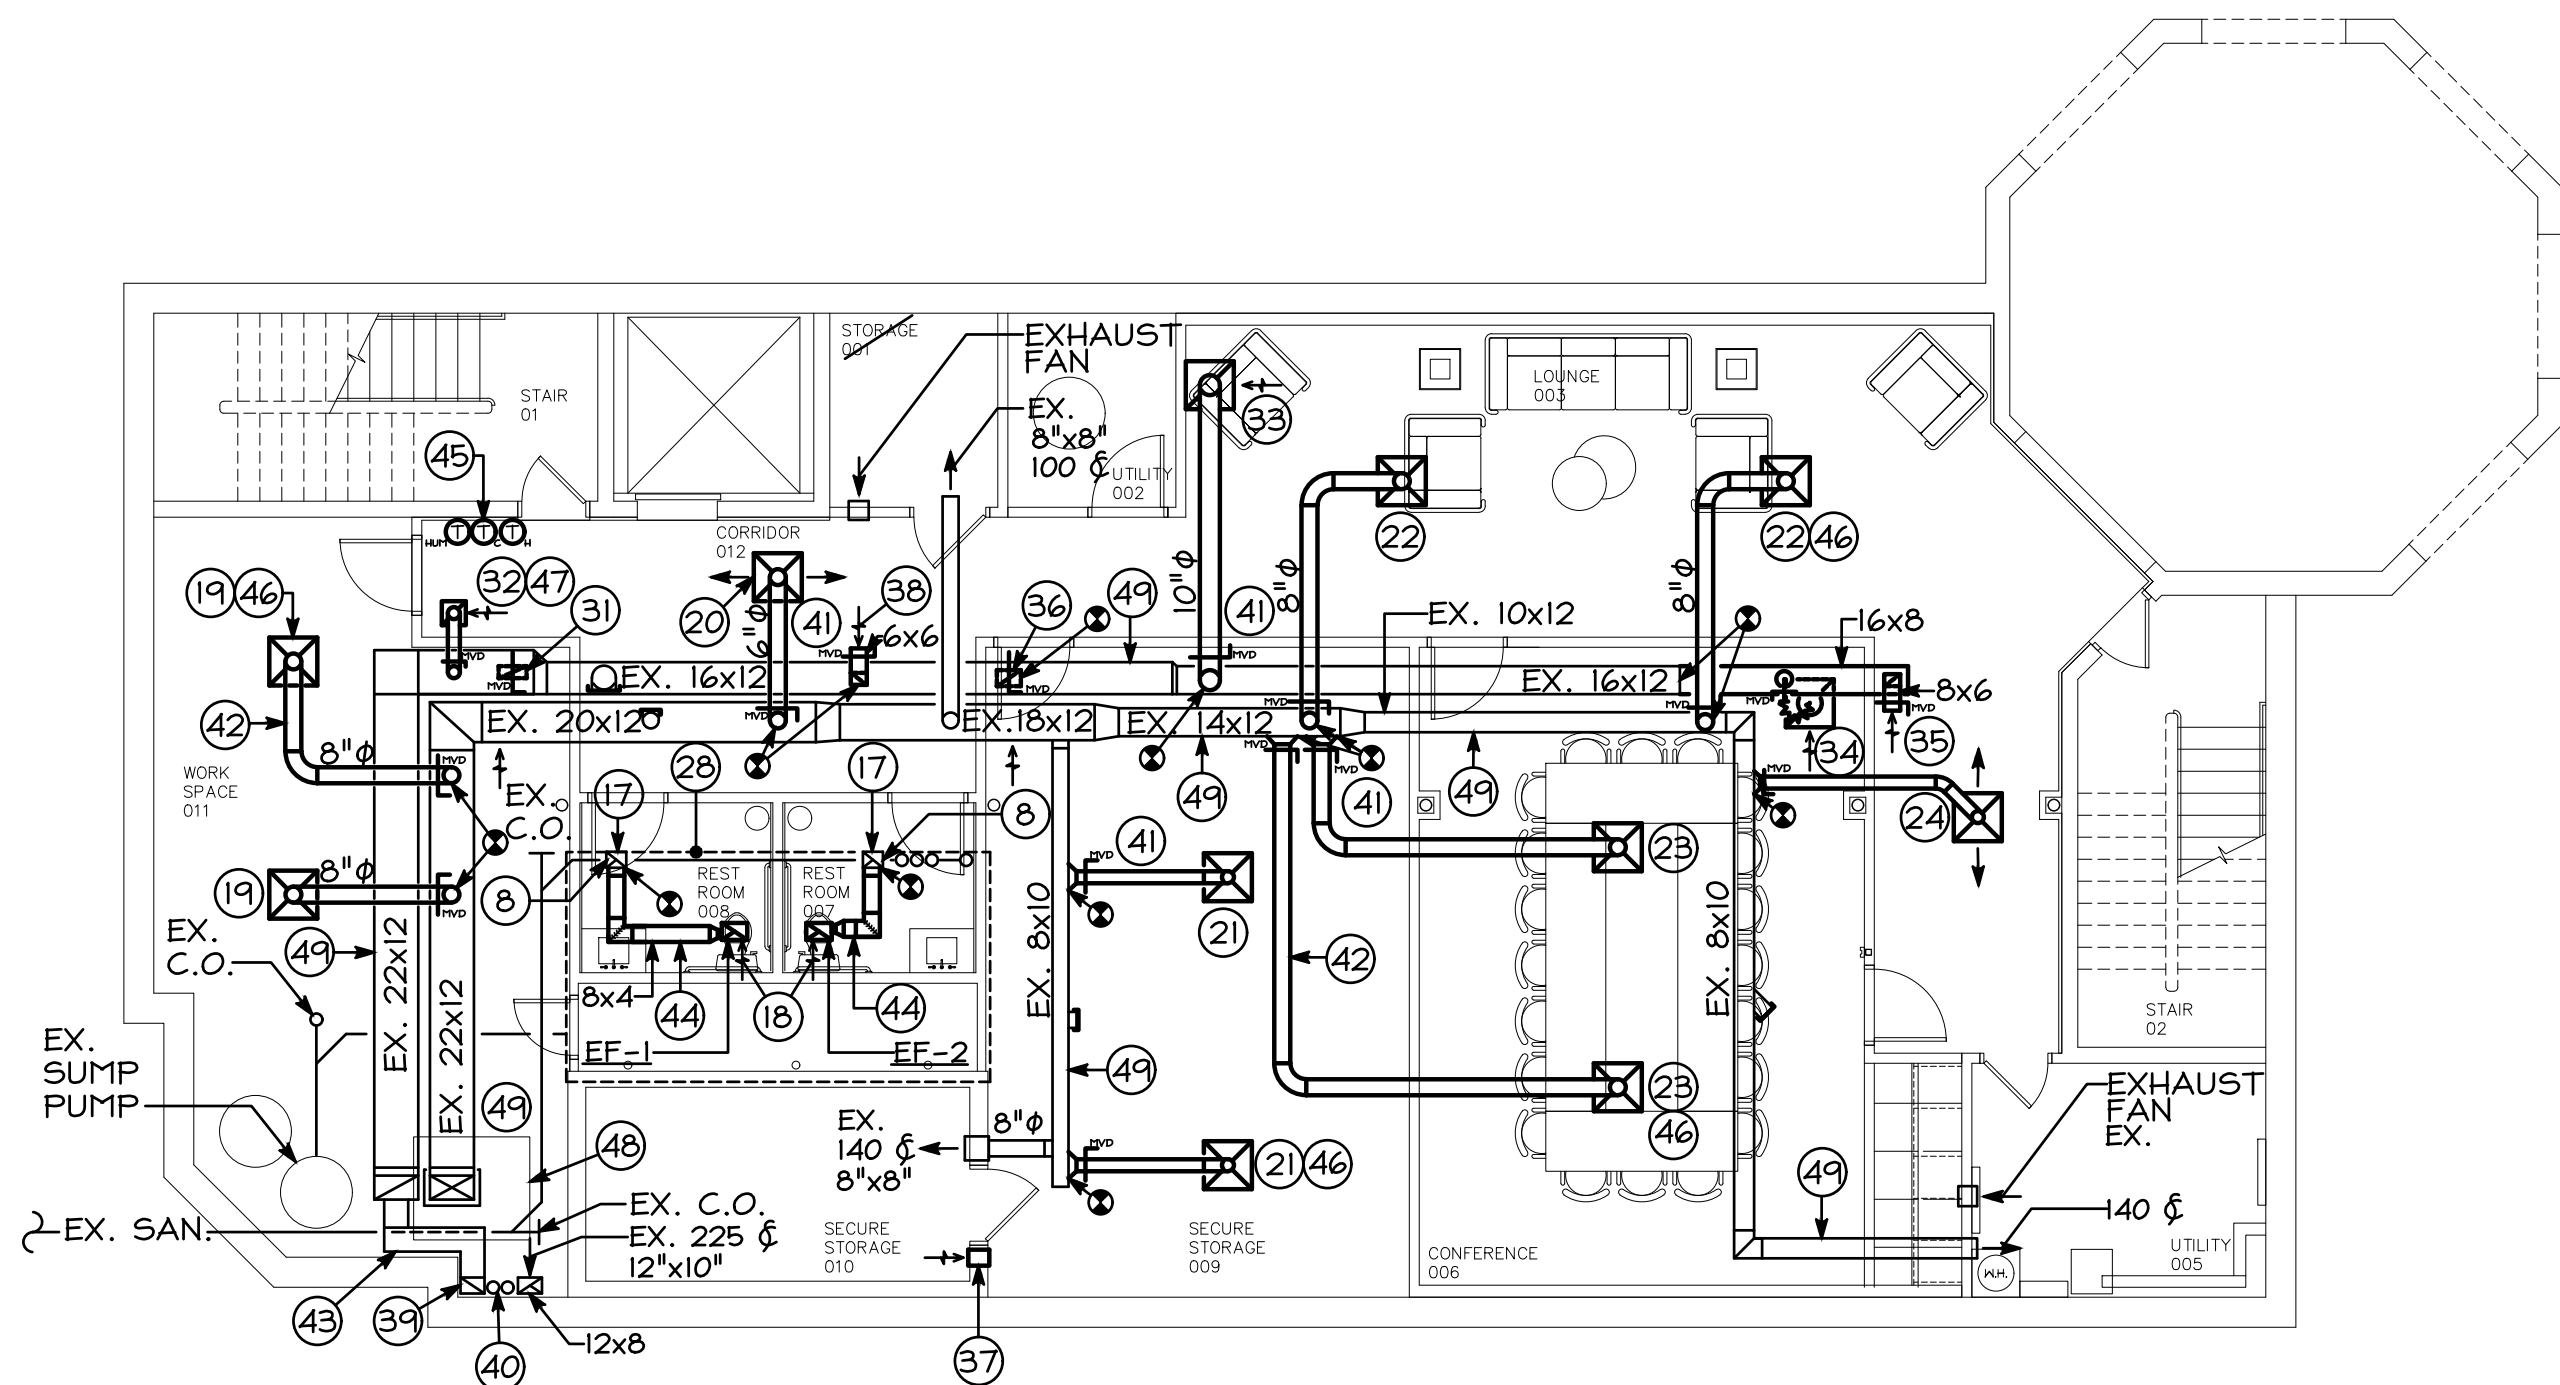


NEW WORK - BASEMENT FLOOR - MECHANICAL
SCALE: 1/8"=1'-0"

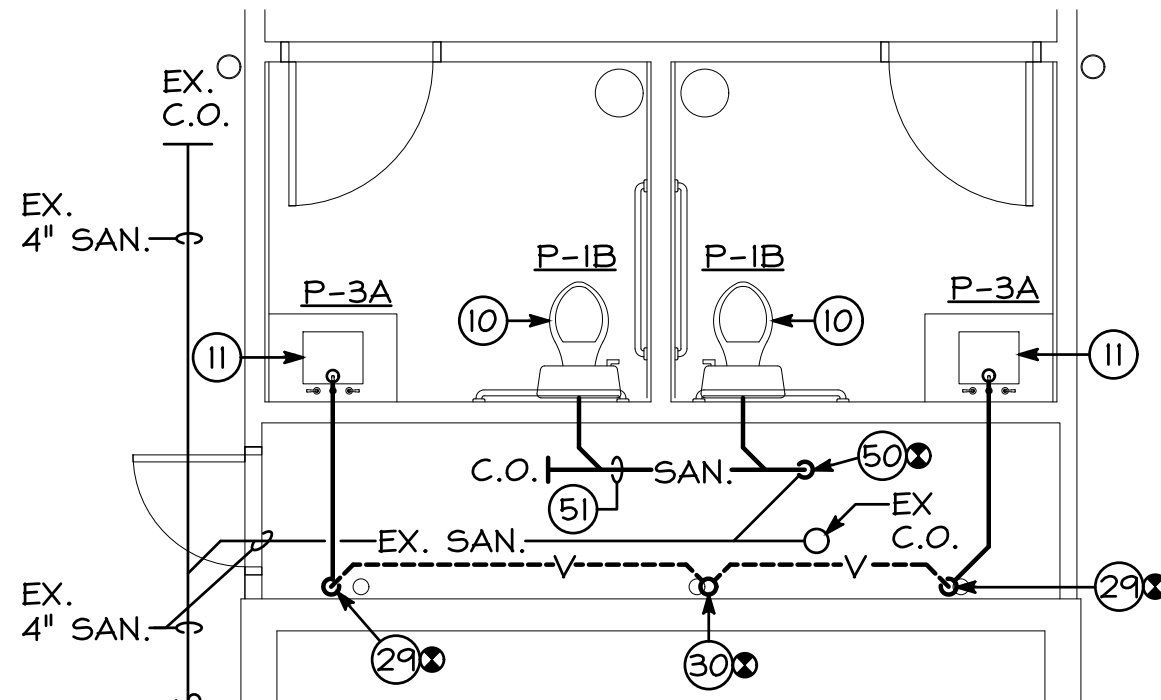


BASEMENT - SANITARY/VENT
SCALE: 1/4"=1'-0"

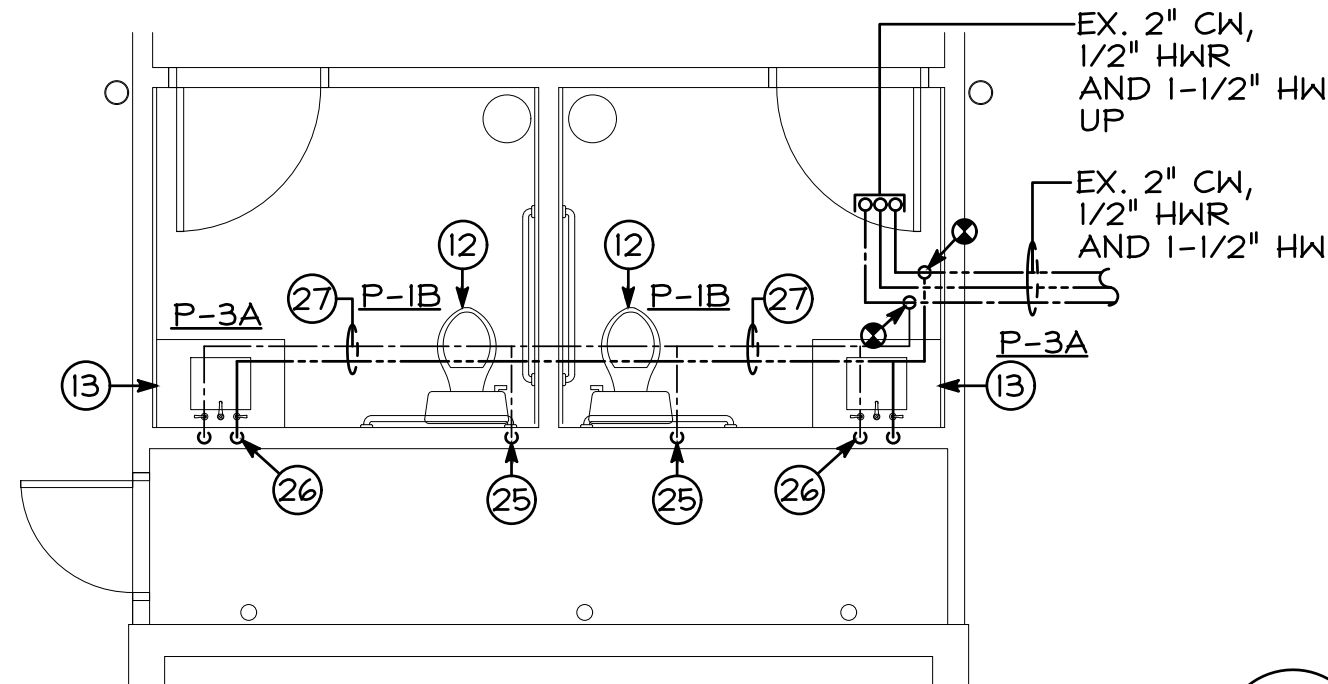


BASEMENT - DOMESTIC WATER
SCALE: 1/4"=1'-0"

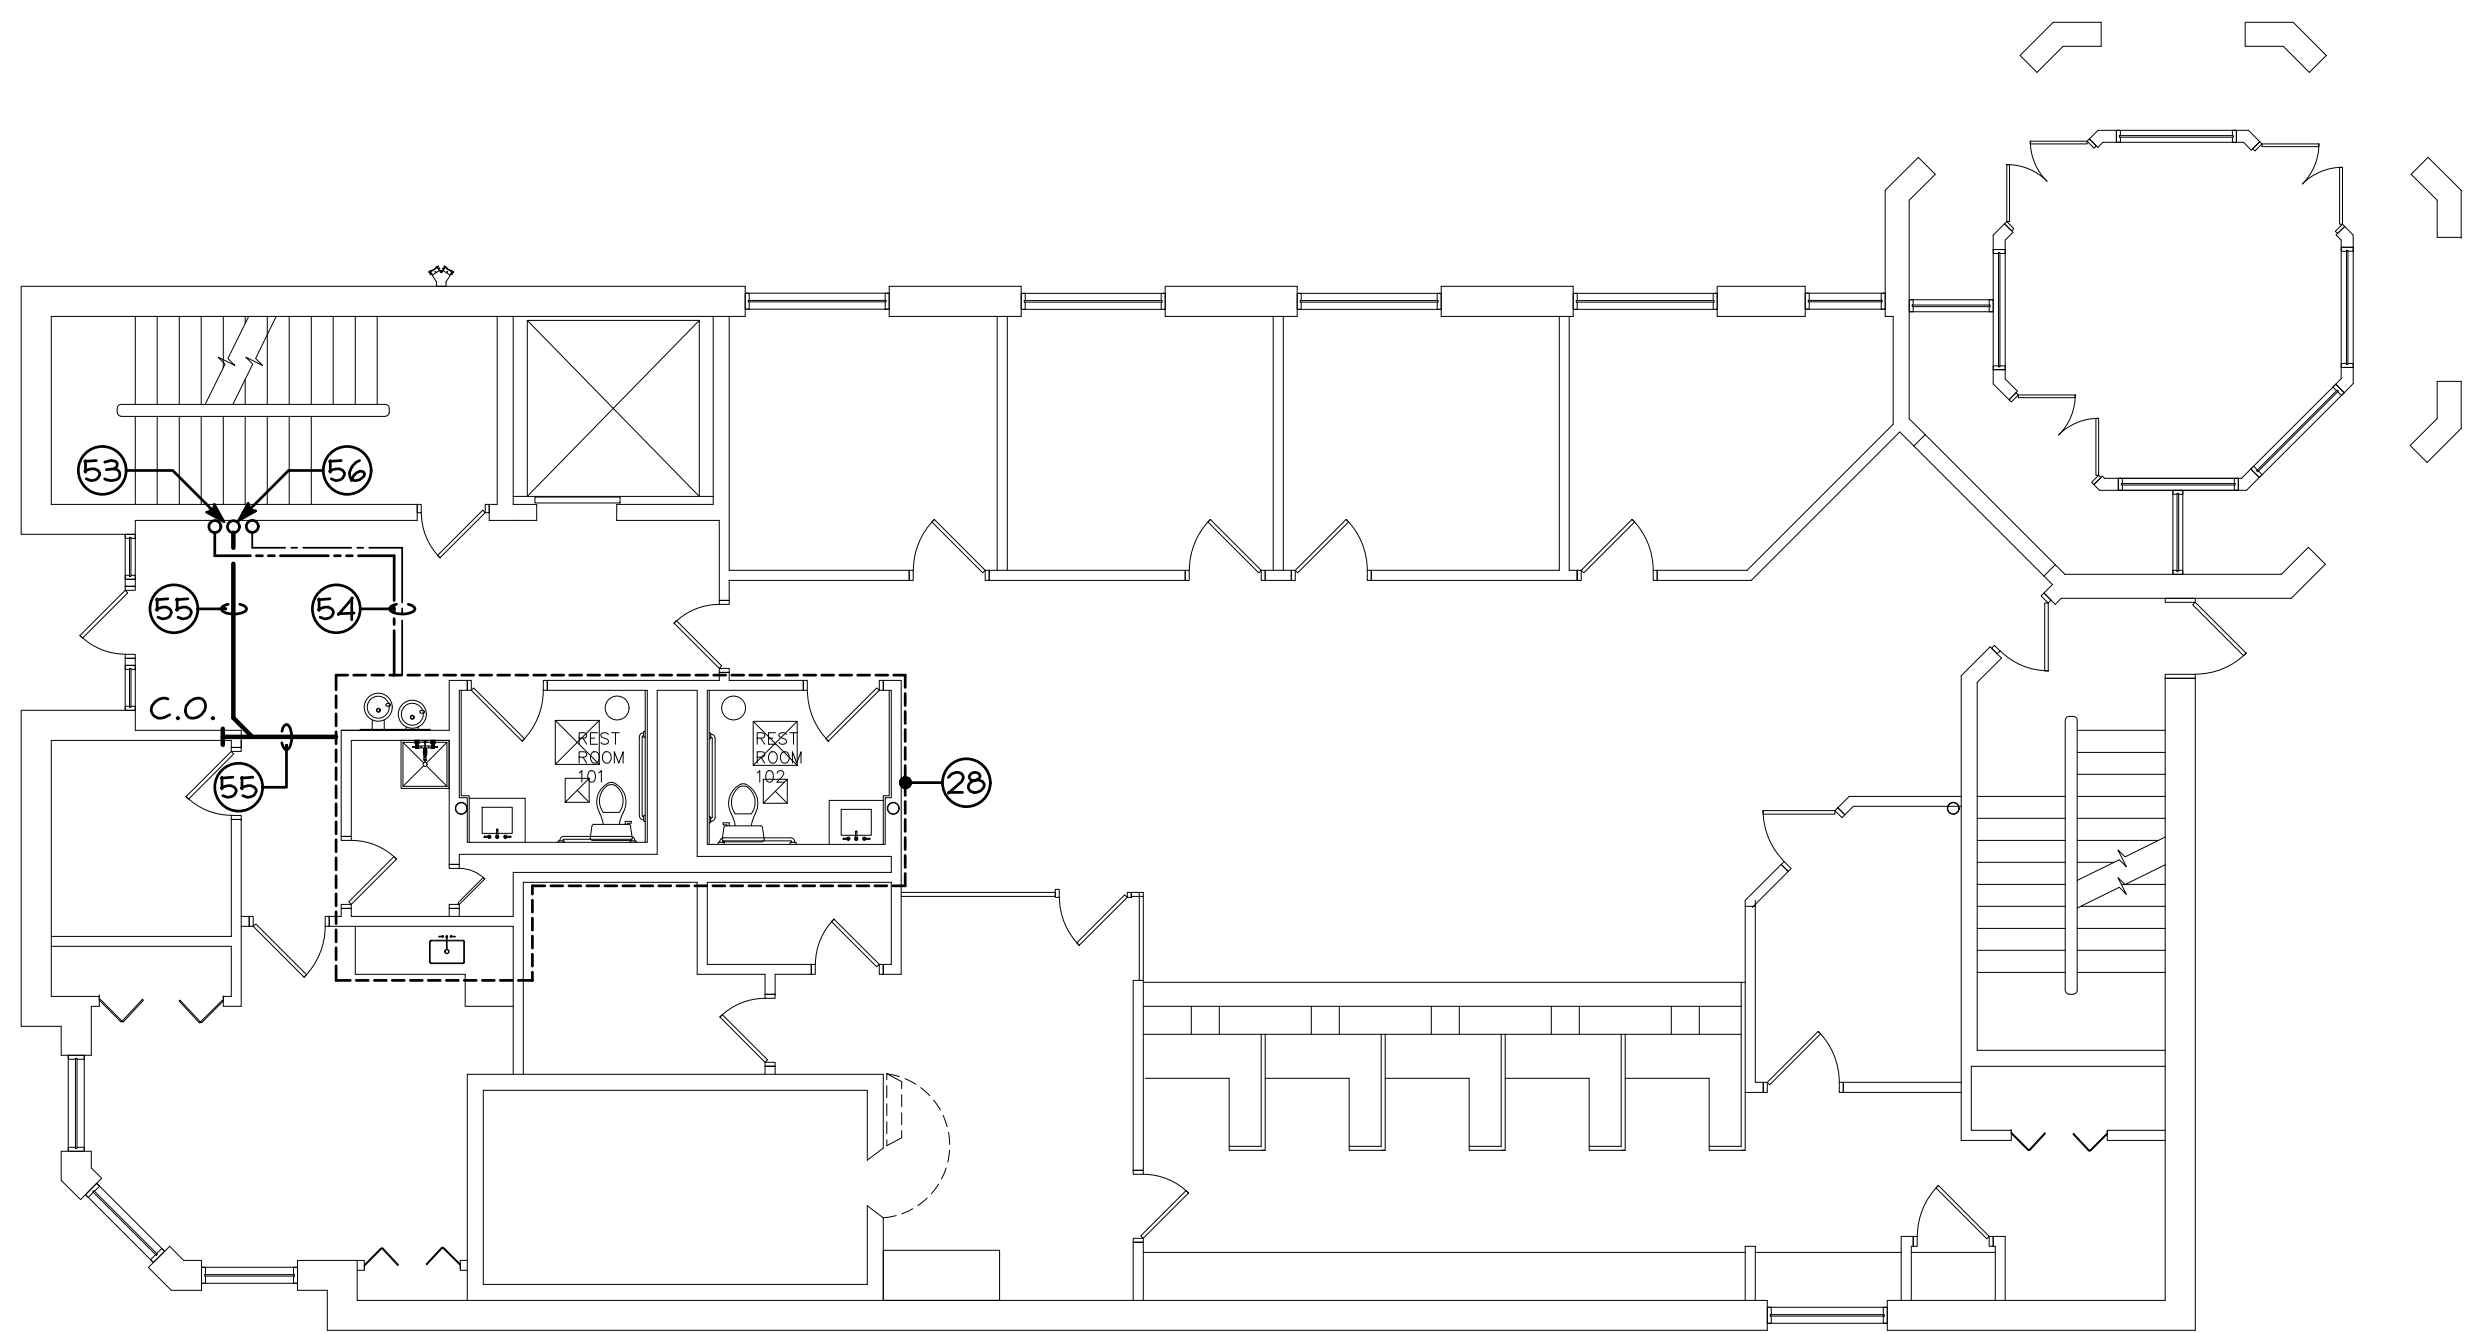

NEW WORK - FIRST FLOOR - MECHANICAL
SCALE: 1/8"=1'-0"

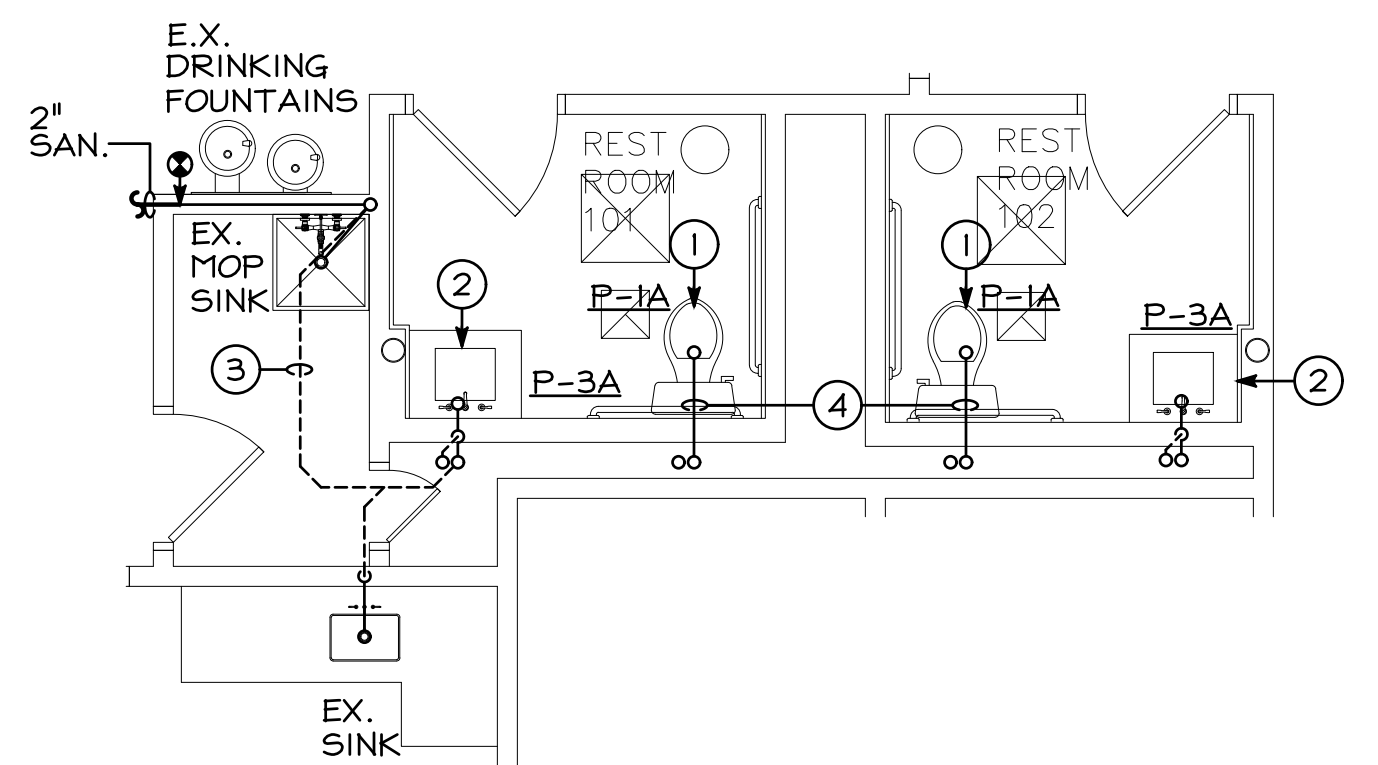


FIRST FLOOR - SANITARY VENT
SCALE: 1/4"=1'-0"

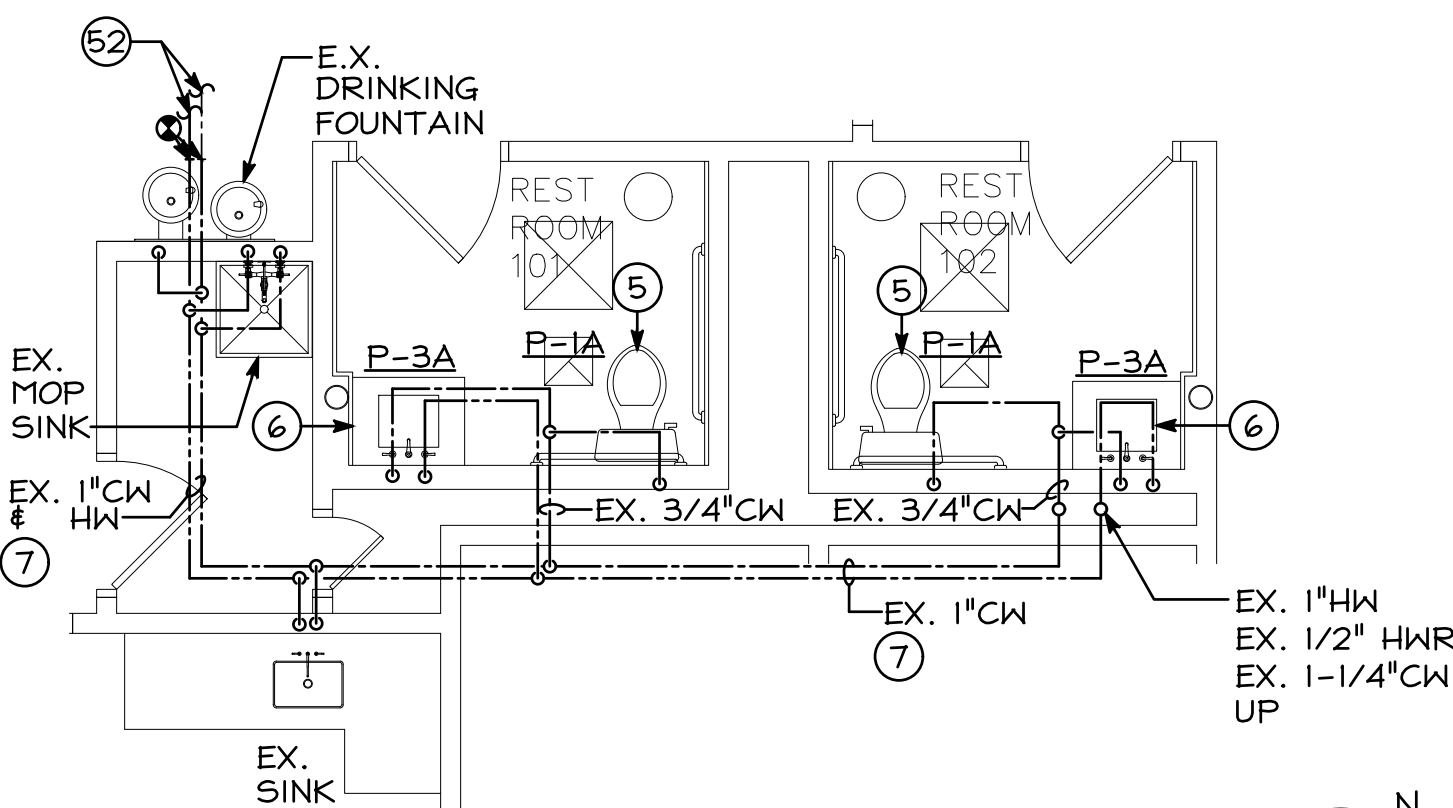

FIRST FLOOR - DOMESTIC WATER
SCALE: 1/4"=1'-0"

DRAWING NOTES

- 1 INSTALL NEW WATER CLOSET AND WAX RING.
- 2 INSTALL NEW LAVATORY AND FAUCET. INSTALL NEW SANITARY PIPING AND P-TRAP.
- 3 EXISTING VENT PIPING SUPPORTED ABOVE CEILING.
- 4 EXISTING SANITARY PIPING BELOW FLOOR.
- 5 INSTALL NEW WATER CLOSET AND CW CONNECTION.
- 6 INSTALL NEW LAVATORY, FAUCET AND NEW CW & HW CONNECTION.
- 7 EXISTING DOMESTIC WATER PIPING SUPPORTED ABOVE CEILING.
- 8 EXISTING 10x10 EXHAUST DUCT UP TO EXISTING EXHAUST AIR VENT LOCATED ON ROOF.
- 9 REFER TO PLUMBING FLOOR PLANS AND RISER DIAGRAMS.
- 10 INSTALL NEW WATER CLOSET AND ALL ASSOCIATED SANITARY/VENT PIPING.
- 11 INSTALL NEW LAVATORY AND ALL ASSOCIATED SANITARY/VENT PIPING.
- 12 INSTALL NEW WATER CLOSET AND ALL ASSOCIATED DOMESTIC WATER PIPING.
- 13 INSTALL NEW LAVATORY AND ALL ASSOCIATED DOMESTIC WATER PIPING.
- 14 EXISTING DOMESTIC WATER PIPING SUPPORTED ABOVE CEILING.
- 15 EXISTING VENT PIPING SUPPORTED ABOVE CEILING.
- 16 EXISTING SANITARY PIPING BELOW FLOOR.
- 17 EXISTING 10x6 EXHAUST AIR DUCT UP.
- 18 CEILING EXHAUST FAN MOUNTED FROM CEILING STRUCTURE ABOVE. REFER TO DETAIL AND SCHEDULE FOR MORE INFORMATION.
- 19 150 CFM, 8"Ø NECK, 24x24 SUPPLY AIR DIFFUSER.
- 20 75 CFM, 8"Ø NECK, 24x24 SUPPLY AIR DIFFUSER.
- 21 90 CFM, 6"Ø NECK, 24x24 SUPPLY AIR DIFFUSER.
- 22 125 CFM, 8"Ø NECK, 24x24 SUPPLY AIR DIFFUSER.
- 23 180 CFM, 8"Ø NECK, 24x24 SUPPLY AIR DIFFUSER.
- 24 55 CFM, 6"Ø NECK, 24x24 SUPPLY AIR DIFFUSER.
- 25 COORDINATE CW PIPE DOWN IN WALL.
- 26 COORDINATE CW & HW PIPE DOWN IN WALL.
- 27 DOMESTIC WATER SUPPORTED FROM STRUCTURE ABOVE.
- 28 REFER TO PLUMBING PART PLANS LOCATED ON THIS DRAWING FOR WORK IN THIS AREA.
- 29 VENT PIPE DOWN IN WALL. CONNECT TO EXISTING VENT PIPE STUBBED UP.
- 30 EXISTING VENT PIPE UP.
- 31 300 CFM, 14"x6" RETURN AIR REGISTER.
- 32 75 CFM, 12"x12" RETURN AIR DIFFUSER, 6"Ø NECK.
- 33 305 CFM, 24"x24" RETURN AIR DIFFUSER, 10"Ø NECK.
- 34 360 CFM, 24"x24" RETURN AIR DIFFUSER, 12"Ø NECK.
- 35 140 CFM, 8"x6" RETURN AIR DUCT OPENING WITH 1"x1" WIRE MESH SCREEN OVER OPENING.
- 36 320 CFM, 12"x8" RETURN AIR REGISTER.
- 37 8"x6" TRANSFER AIR DUCT.
- 38 100 CFM, 6"x6" RETURN AIR DUCT OPENING WITH 1"x1" WIRE MESH SCREEN OVER OPENING.
- 39 OUTSIDE AIR DUCT DN. TO EXISTING AIR HANDLING UNIT.
- 40 EXISTING REFRIGERANT PIPING FROM AIR HANDLING UNIT TO HEAT PUMP ON ROOF.
- 41 MANUAL BALANCING DAMPER (TYPICAL).
- 42 SUPPLY AIR DUCTWORK SUPPORTED FROM STRUCTURE ABOVE (TYPICAL).
- 43 EXISTING OUTSIDE AIR DUCTWORK SUPPORTED FROM STRUCTURE ABOVE (TYPICAL).
- 44 EXHAUST AIR DUCTWORK SUPPORTED FROM STRUCTURE ABOVE (TYPICAL).
- 45 EXISTING WALL MOUNTED THERMOSTAT MOUNTED 48" ABOVE FLOOR AND AND INTERLOCKED WITH UNIT INDICATED.
- 46 24"x24" CEILING MOUNTED VANED SUPPLY AIR DIFFUSER WITH NECK SIZE AND AIR QUANTITY INDICATED (TYPICAL).
- 47 12"x12" CEILING MOUNTED SUPPLY AIR DIFFUSER WITH NECK SIZE AND AIR QUANTITY INDICATED (TYPICAL).
- 48 EXISTING AIR HANDLING UNIT NO.3.
- 49 EXISTING DUCTWORK SUPPORTED FROM STRUCTURE ABOVE (TYPICAL).
- 50 CONNECT SANITARY PIPE TO EXISTING ROUGH IN LOCATED IN FLOOR. TEST PITT, FIELD VERIFY EXISTING CONDITIONS, PIPE SIZES, INVERT ELEVATION AND FLOW OF DIRECTION BEFORE COMMENCEMENT OF WORK.
- 51 3" SANITARY PIPE LOCATED ABOVE FLOOR. PROVIDE 2% SLOPE.
- 52 REFER TO FIRST FLOOR PLAN NEW WORK FOR CONTINUATION.
- 53 1/2" CW AND 1/2" HW UP TO KITCHEN SINK. REFER TO SECOND FLOOR NEW WORK PLAN FOR CONTINUATION.
- 54 DOMESTIC WATER SUPPORTED FROM STRUCTURE ABOVE CEILING.
- 55 SANITARY PIPE SUPPORTED FROM STRUCTURE ABOVE CEILING.
- 56 2" SANITARY PIPE UP TO KITCHEN SINK. REFER TO SECOND FLOOR NEW WORK PLAN FOR CONTINUATION.

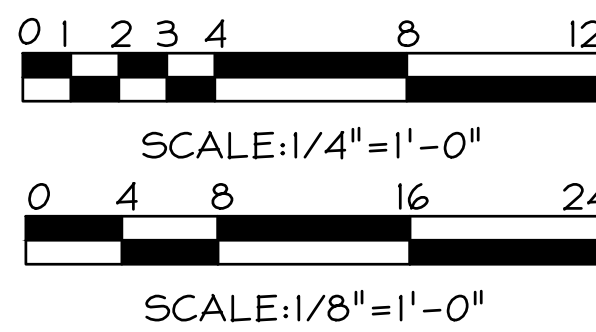

FARMERS & MERCHANTS
BANK
25 WESTMINSTER PIKE
REISTERTOWN, MARYLAND, 21136
INTERIOR ALTERATION



I CERTIFY THAT THESE DOCUMENTS WERE PREPARED OR APPROVED BY ME AND THAT I AM A DULY LICENSED PROFESSIONAL ENGINEER UNDER THE LAWS OF THE STATE OF MARYLAND.

LICENSE NO.: 19994
EXP. DATE: 3/31/2027

THESE DRAWINGS ARE NOT PERMITTED TO BE COPIED OR REPRODUCED, EITHER WHOLLY OR PARTIALLY, UNLESS WRITTEN PERMISSION IS FIRST OBTAINED FROM SANDERS DESIGNS, P.A.

MECHANICAL & ELECTRICAL
DESIGN CONSULTANTS, INC.
1907 N. Fountain Green Road
Bel Air, Maryland 21015-1411
410-893-2822 • Fax 410-893-0442
web site: www.jrsdesign.net

SANDERS | DESIGNS
ARCHITECTS PLANNERS
WWW.SANDERSDESIGNS.COM
MAILBOX@SANDERSDESIGNS.COM
9727 GREENSIDE DRIVE, SUITE 202, COCKEYSVILLE, MARYLAND 21030
T: (410) 560 2624

No.	Date	Revision

Project No.:
Date:
Scale:
Edition:
PERMIT SET
Drawing Name:
NEW WORK FLOOR AND PART PLANS
Drawing Number:


M-4

DRAWING NOTES


- ① DAISY CHAIN THE CONTROLS FOR ZONE DAMPERS 19 AND 20 SO THEY ARE SERVED BY THE SAME EXISTING THERMOSTAT.
- ② EXISTING THERMOSTAT.
- ③ RELOCATE EXISTING THERMOSTAT SERVING ZONE DAMPER 21.
- ④ INSTALL NEW WATER CLOSET AND WAX RING. INSTALL NEW SANITARY PIPING AND P-TRAP.
- ⑤ INSTALL NEW LAVATORY AND FAUCET. INSTALL NEW SANITARY PIPING AND P-TRAP.
- ⑥ INSTALL NEW KITCHEN SINK AND FAUCET. INSTALL NEW SANITARY PIPING AND P-TRAP.
- ⑦ EXISTING VENT PIPING SUPPORTED ABOVE CEILING.
- ⑧ EXISTING SANITARY PIPING BELOW FLOOR.
- ⑨ INSTALL NEW WATER CLOSET AND CW CONNECTION.
- ⑩ INSTALL NEW LAVATORY, FAUCET AND NEW CW & HW CONNECTION.
- ⑪ INSTALL NEW KITCHEN SINK AND CW & HW CONNECTION.

- ⑫ EXISTING DOMESTIC WATER PIPING SUPPORTED ABOVE CEILING.
- ⑬ EX. AHU-1 HUNG ABOVE THE CEILING SERVES IT ROOM1. EXTERIOR UNIT LOCATED ON THE ROOF.
- ⑭ 24"x24" SUPPLY AIR DIFFUSER @ 250 CFM, 10"Ø NECK (TYPICAL OF 3).
- ⑮ SPLIT SYSTEM AIR HANDLING UNIT HUNG ABOVE THE CEILING SERVES IT ROOM. EXTERIOR UNIT LOCATED ON THE ROOF.
- ⑯ 24"x24" PERFORATED SUPPLY AIR DIFFUSER @ 200 CFM, 8"Ø NECK (TYPICAL OF 4)
- ⑰ MOUNT HEAT PUMP ON EQUIPMENT RAILS.
- ⑱ SUPPORT RS&RL PIPING ON ROOF (TYPICAL).


- ⑲ RS&RL PIPING ROUTED DOWN IN EXISTING PITCH POCKET. ALL ROOF WORK MUST BE PERFORMED BY THE OWNERS ROOFER IN ORDER TO MAINTAIN THE ROOF WARRANTY.
- ⑳ 24"x24" PERFORATED RETURN AIR DEVICE.
- ㉑ SPLIT SYSTEM AIR HANDLING UNIT SUPPORTED FROM STRUCTURE ABOVE. REFER TO DETAIL AND SCHEDULE FOR MORE INFORMATION.
- ㉒ THERMOSTAT MOUNTED 48" A.F.F.
- ㉓ EX. 12x12 SUPPLY AIR DUCT SUPPORTED FROM STRUCTURE ABOVE.
- ㉔ EX. VAV BOX NO. 15 THERMOSTAT SERVING THIS ROOM.
- ㉕ 3" CONDENSATE DRAIN TRAP.
- ㉖ SLOPE CONDESATE DRAIN AT 1/4" PER FOOT TO EXISTING ROOF DRAIN.
- ㉗ SECURE CONDENSATE DRAIN PIPE TO PIPE SUPPORT BLOCKS (TYPICAL).
- ㉘ DISCHARGE CONDENSTAE INTO ROOF DRAIN.
- ㉙ 1" CW AND 1/2" HW UP FROM FIRST FLOOR LOCATED IN WALL. CONNECT TO SINK.
- ㉚ DOMESTIC WATER PIPING LOCATED ABOVE CEILING.
- ㉛ CW UP FROM FIRST FLOOR CEILING LOCATED IN WALL. CONNECT TO WATER DISPENSER.
- ㉜ 2" SANITARY PIPE DOWN TO FIRST FLOOR CEILING. REFER TO NEW WORK PLAN FOR CONTINUATION.
- ㉝ 2" VENT PIPE UP TO SECOND FLOOR CEILING.
- ㉞ 3/4" CONDENSATE PIPED TO STORM WATER PIPE ABOVE CEILING, PROVIDE TRAP AND SLOPE PIPE 1/8" PER FOOT.

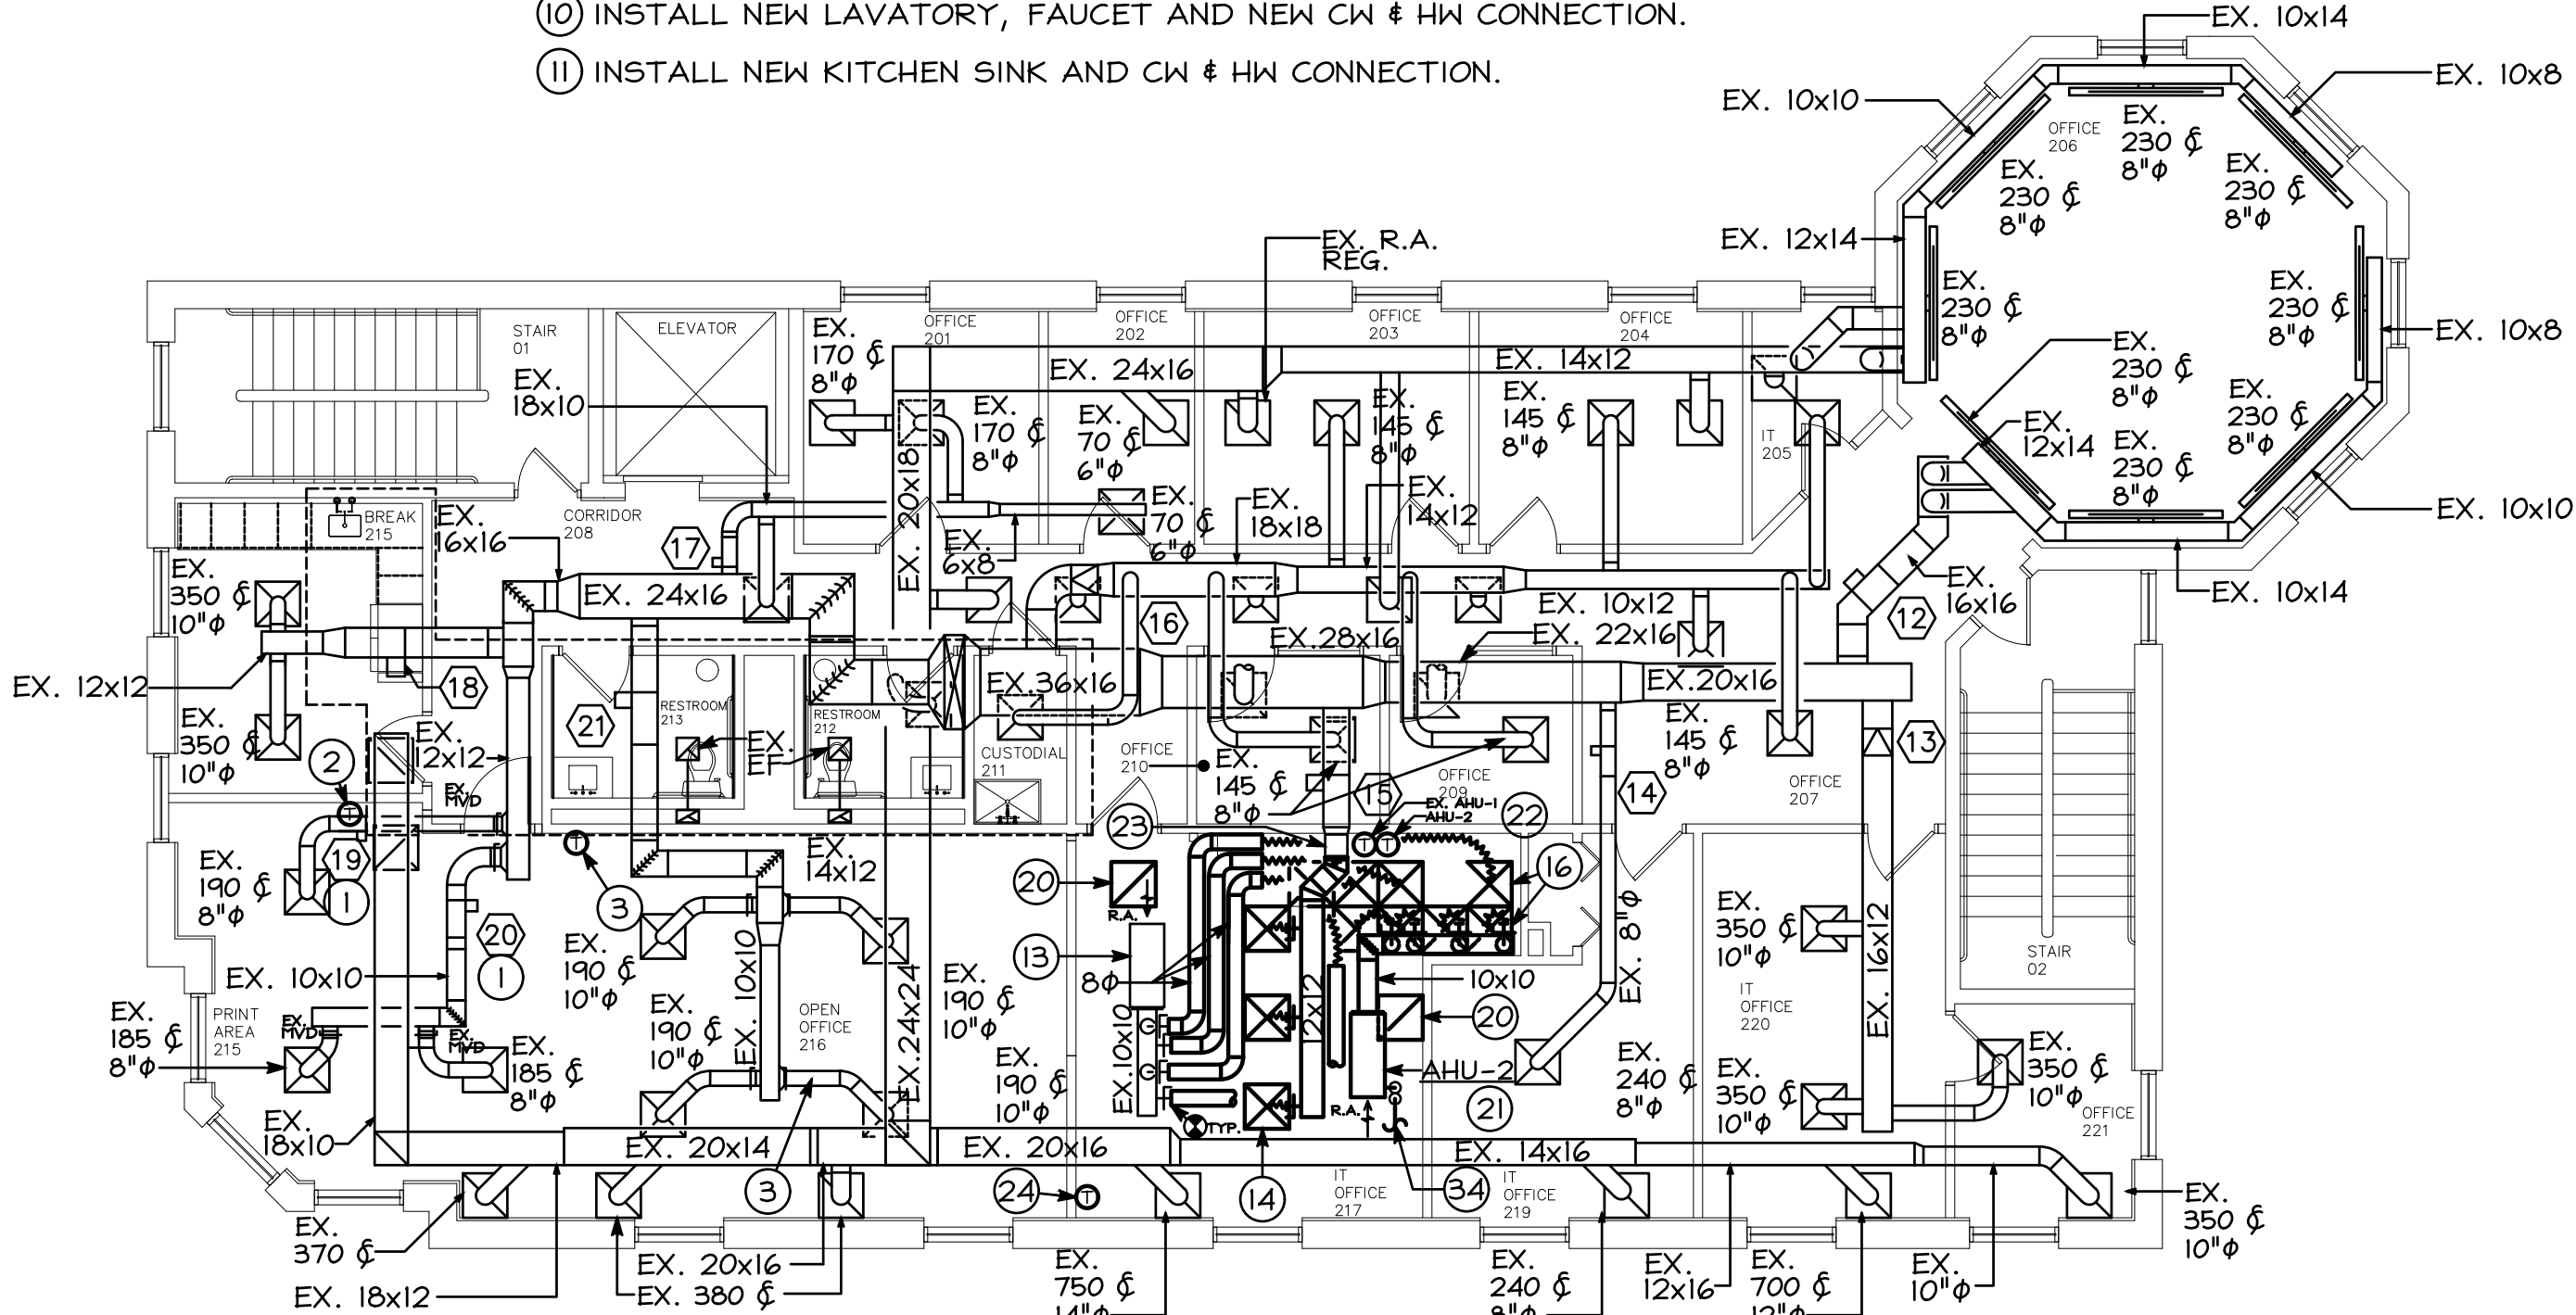


NEW WORK - SECOND FLOOR - MECHANICAL
SCALE: 1/8"=1'-0"

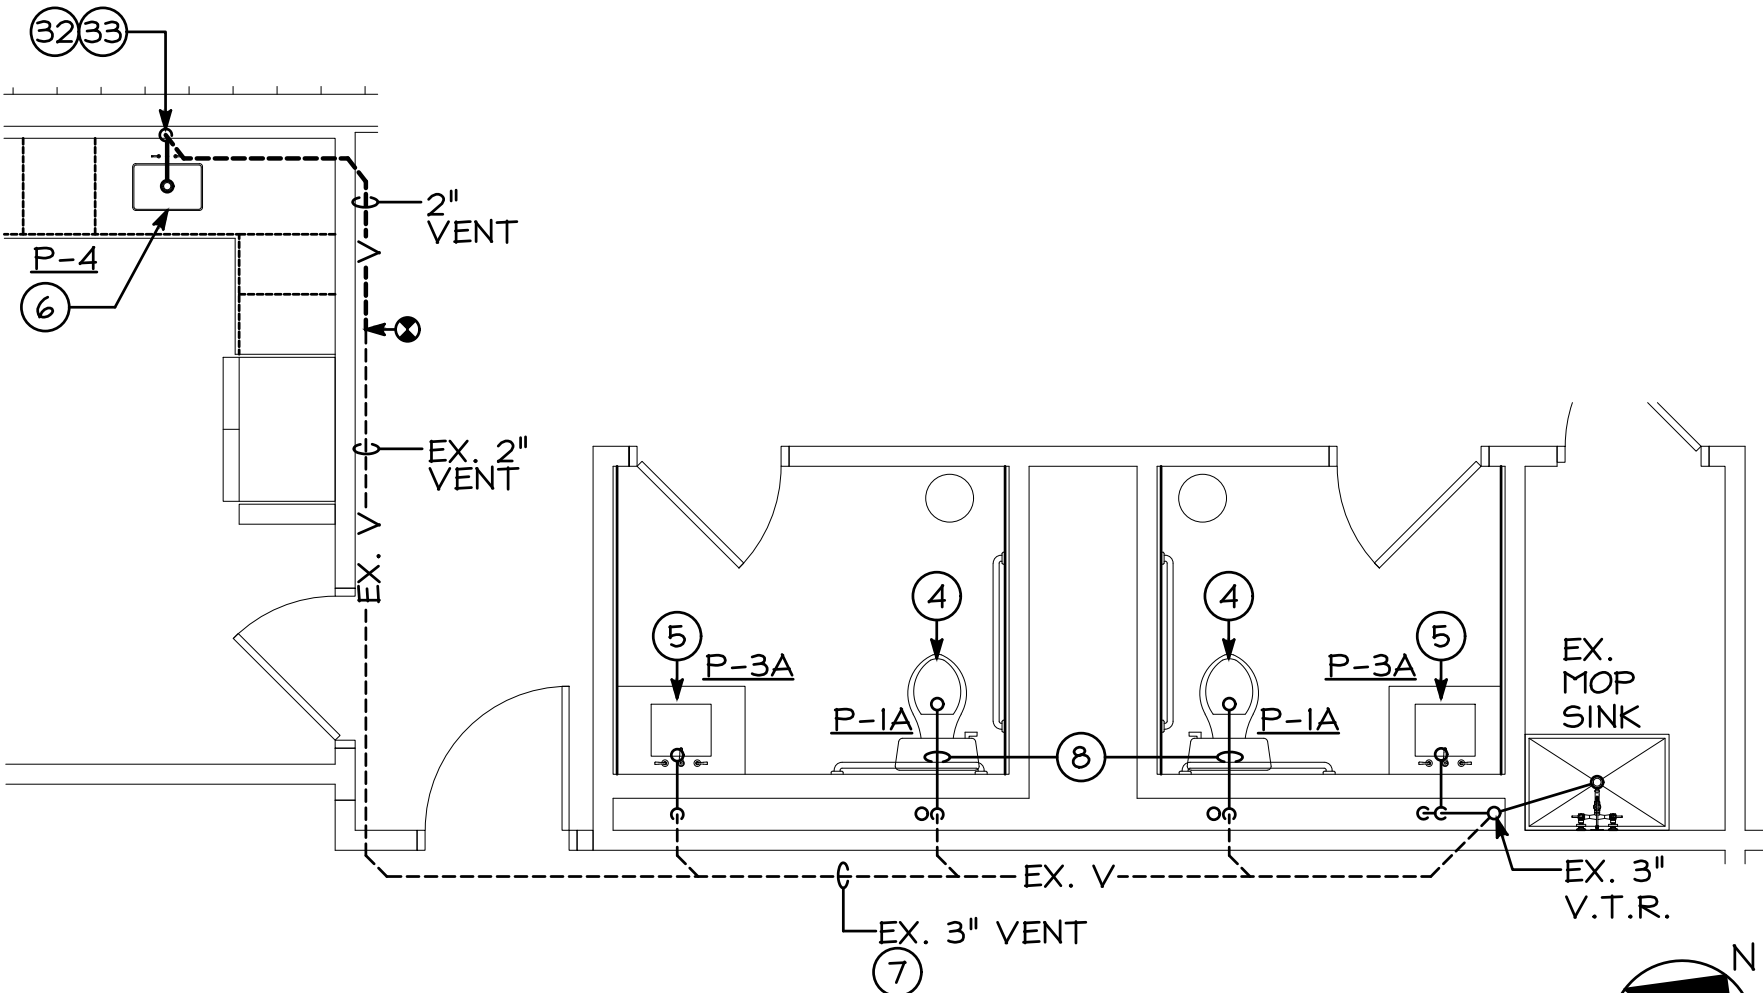


SECOND FLOOR - SANITARY/VENT
SCALE: 1/4"=1'-0"

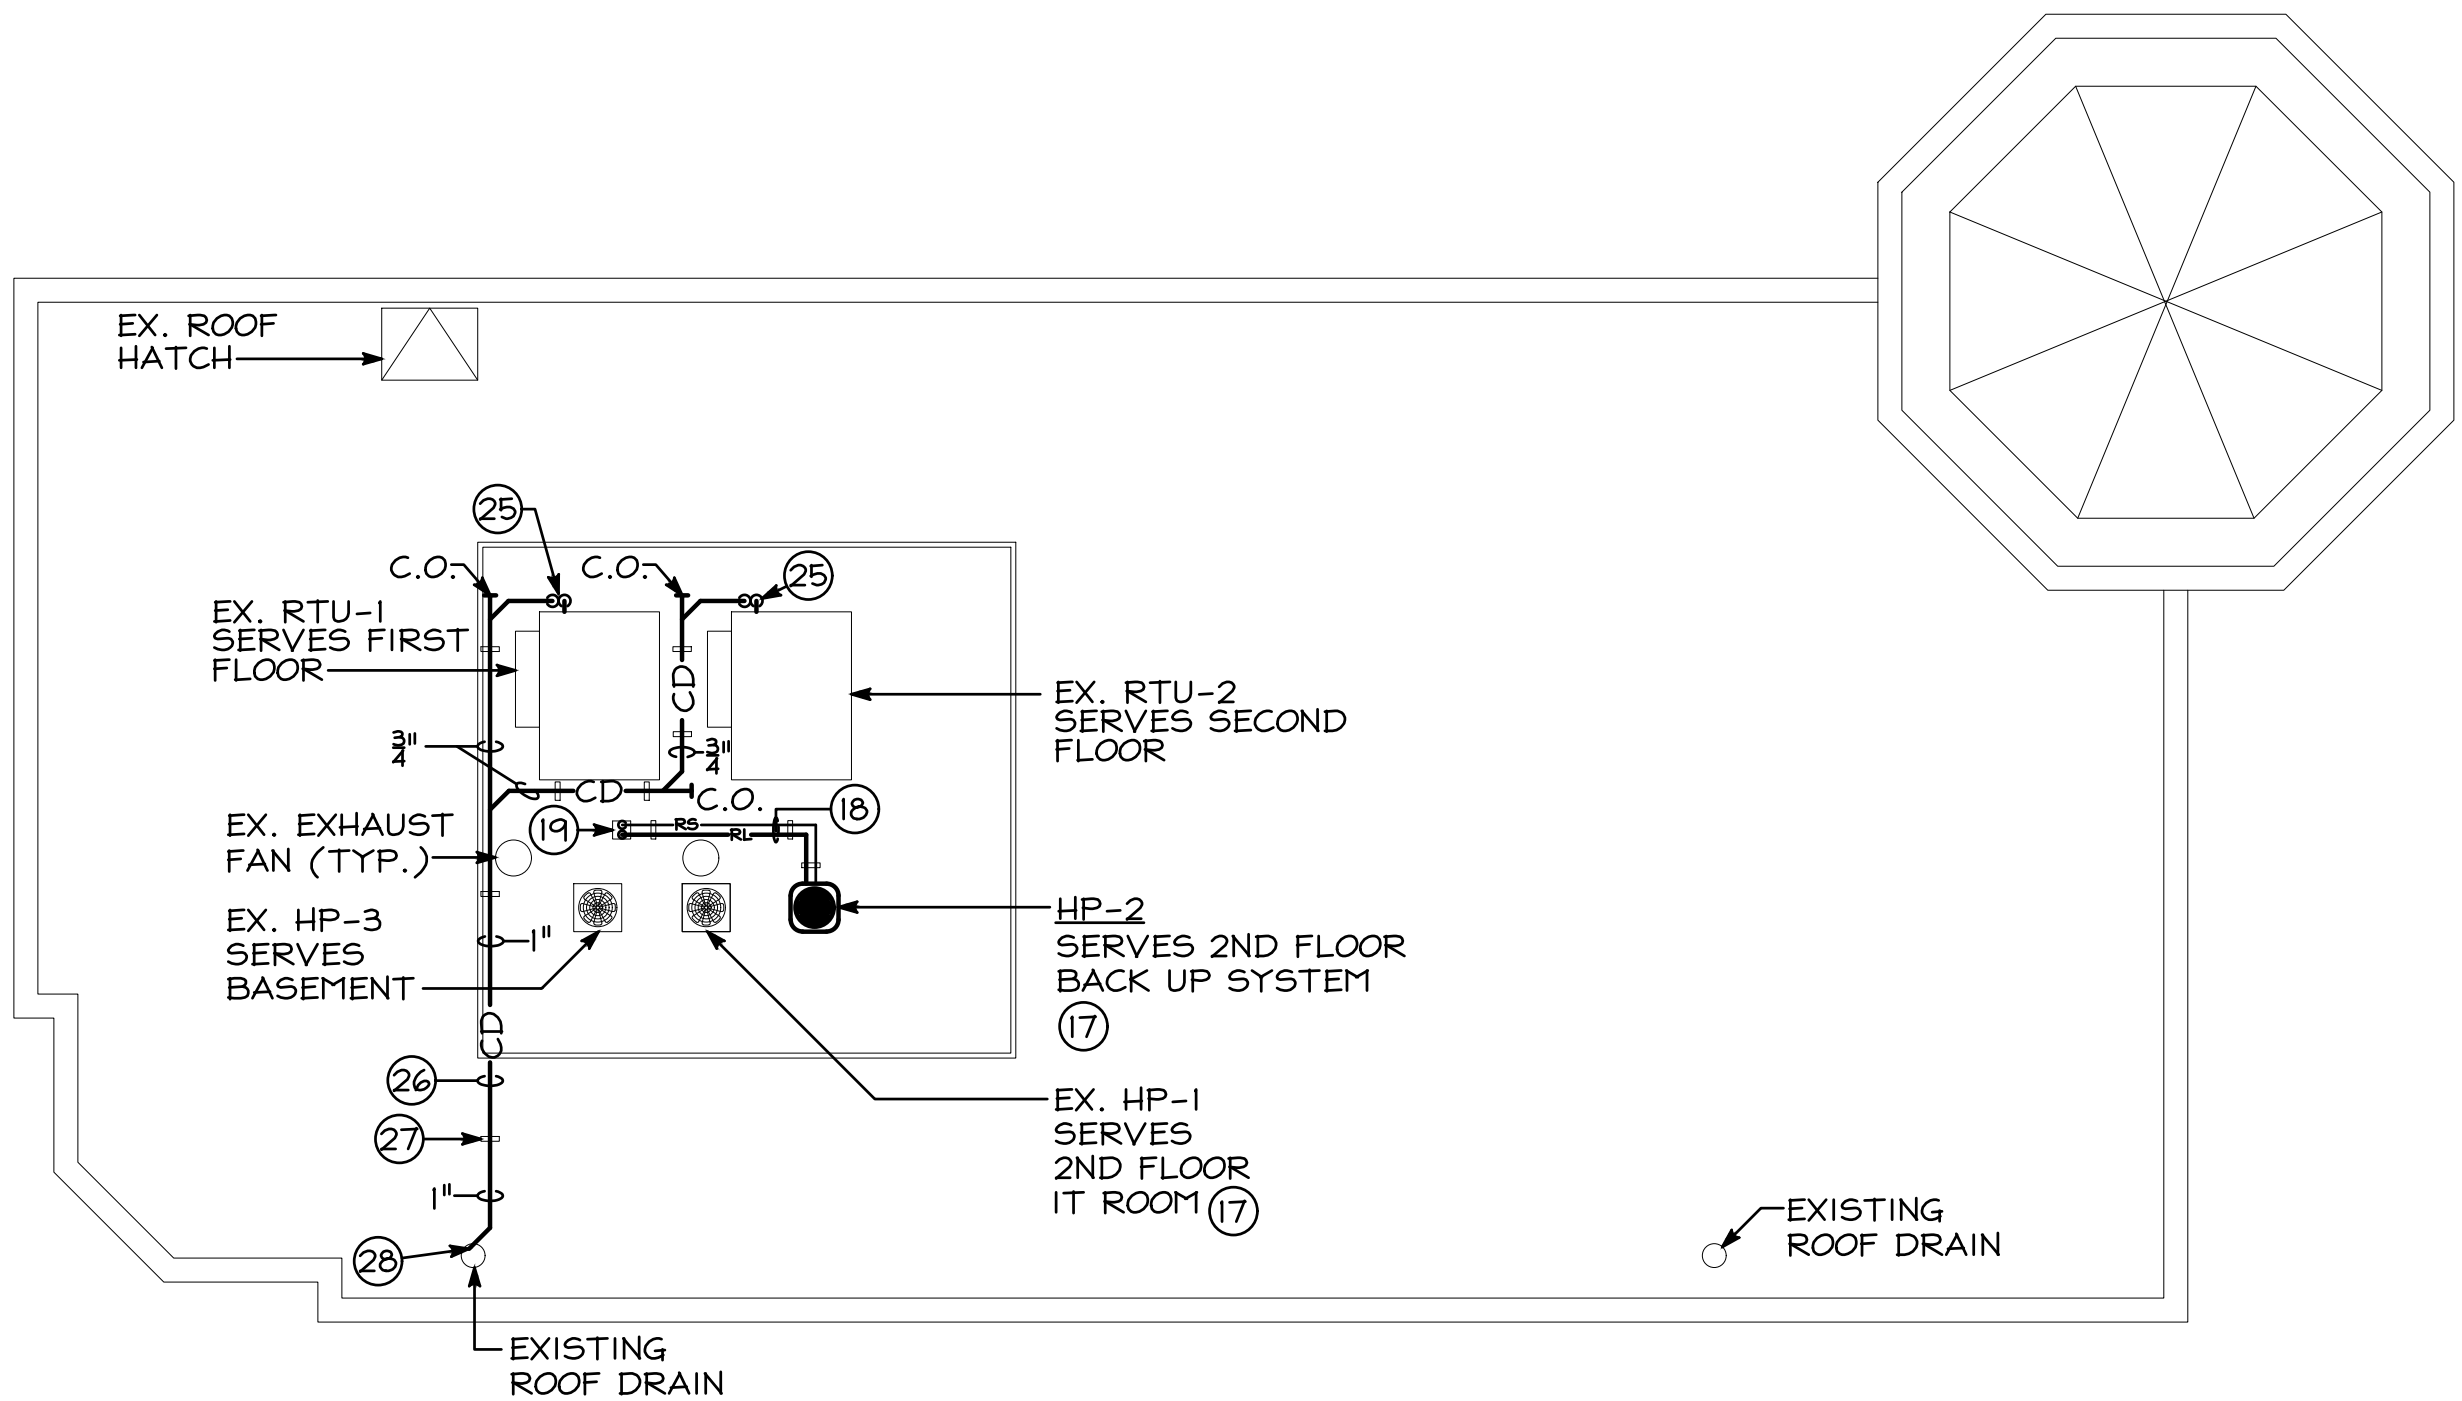


NEW WORK - ROOF PLAN - MECHANICAL
SCALE: 1/8"=1'-0"

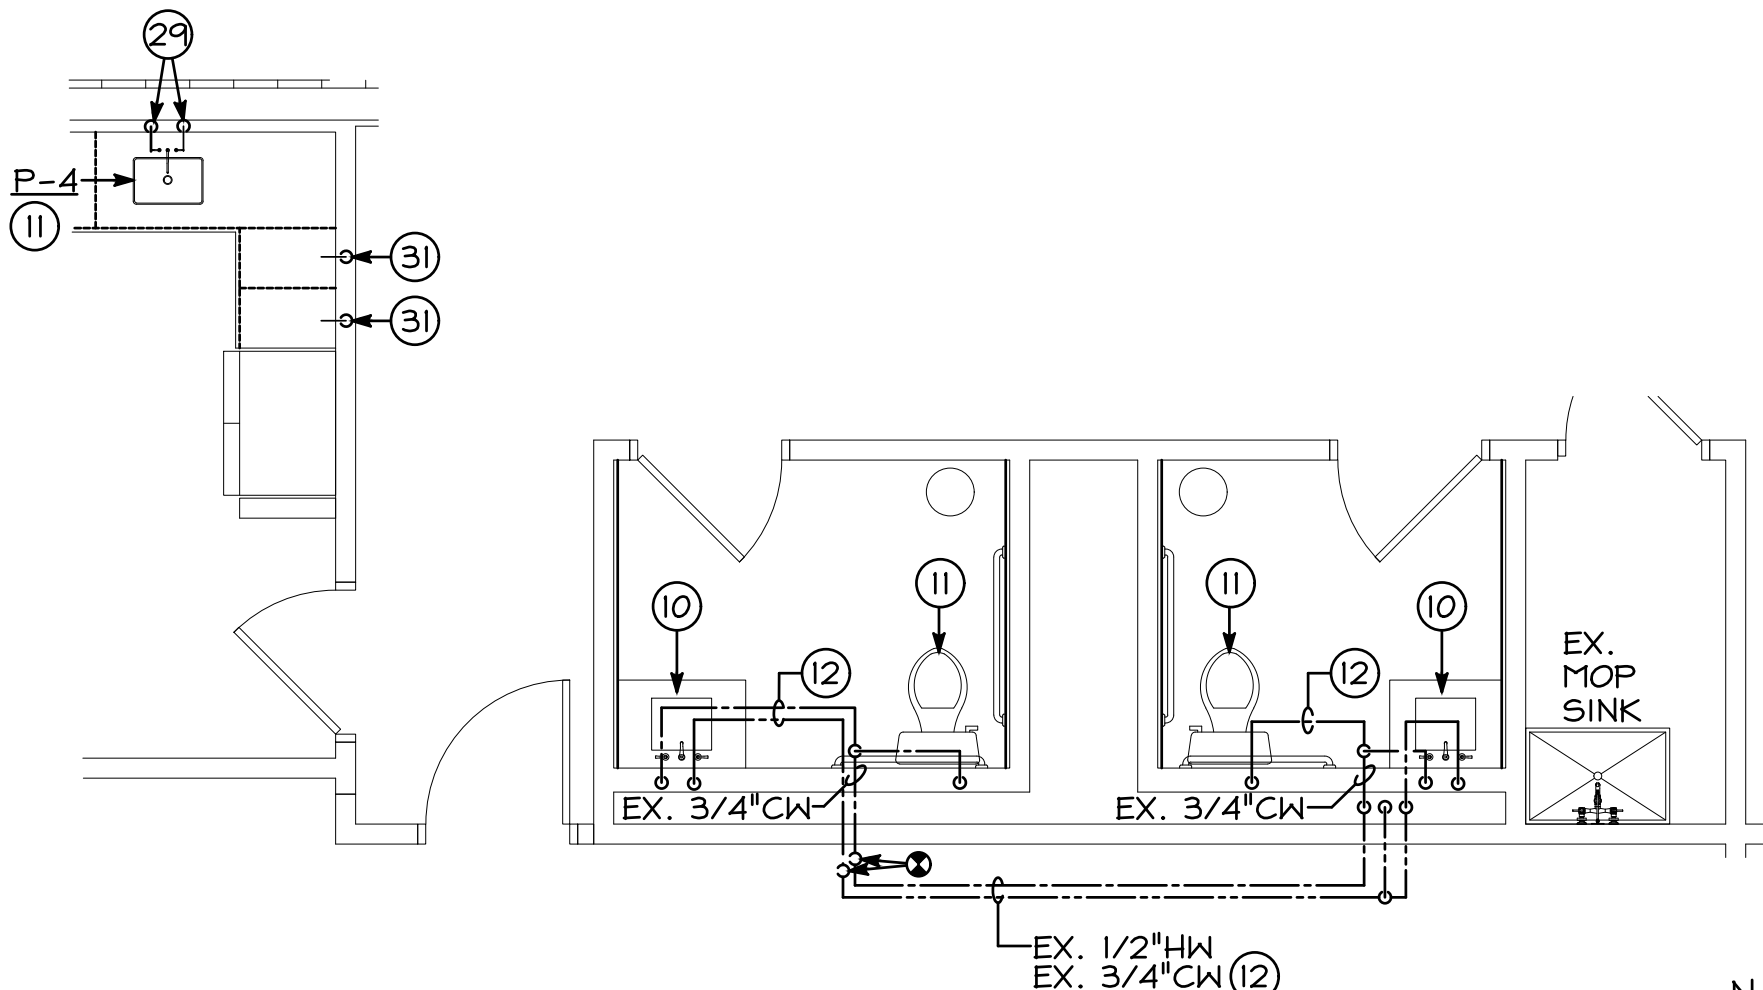

SECOND FLOOR - DOMESTIC WATER
SCALE: 1/4"=1'-0"

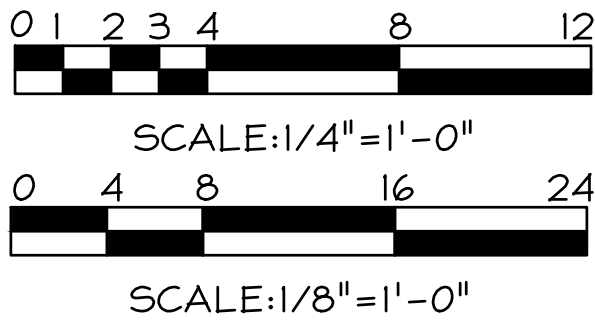

FARMERS & MERCHANTS
BANK
25 WESTMINSTER PIKE
REISTERTOWN, MARYLAND, 21136
INTERIOR ALTERATION

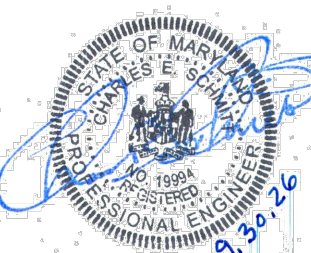

I CERTIFY THAT THESE DOCUMENTS WERE PREPARED OR APPROVED BY ME AND THAT I AM A DULY LICENSED PROFESSIONAL ENGINEER UNDER THE LAWS OF THE STATE OF MARYLAND.

LICENSE NO.: 19994
EXP. DATE: 3/31/2027

THESE DRAWINGS ARE NOT PERMITTED TO BE COPIED OR REPRODUCED, EITHER WHOLLY OR PARTIALLY, UNLESS WRITTEN PERMISSION IS FIRST OBTAINED FROM SANDERS DESIGNS, P.A.

MECHANICAL & ELECTRICAL
DESIGN CONSULTANTS, INC.
1907 N. Fountain Green Road
Bel Air, Maryland 21015-1411
410-869-2822 • Fax 410-869-0442
Web Site: www.jrsdesign.net

SANDERS | DESIGNS
ARCHITECTS PLANNERS
WWW.SANDERSDESIGNS.COM
9727 GREENSIDE DRIVE, SUITE 202, COCKEYSVILLE, MARYLAND 21030
T: (410) 860 2624

No.	Date	Revision

Project No.:
Date:
Scale:
Edition:
PERMIT SET

Drawing Name:
NEW WORK FLOOR AND PART PLANS
Drawing Number:

M-5

SPLIT SYSTEM HEAT PUMP AIR HANDLING UNIT SCHEDULE

ITEM#	AREA SERVED	FAN DATA					DX COOLING DATA (R454B)					HEAT PUMP HEATING DATA (KW=TOTAL POWER)					INDOOR UNIT					OUTDOOR UNIT						
		C.F.M.	E.S.P.	H.P.	R.P.M.	C.F.M. O.A.	TOTAL BTU/HR.	SENS. BTU/HR.	# COIL ROWS	ENTERING AIR DB°F	WB°F	HI-TEMP HEAT 47 O.A.T. BTU/HR.	KW	C.O.P.	LOW-TEMP HEAT 17 O.A.T. BTU/HR.	KW	C.O.P.	ELECTRICAL DATA	MCA/ MOP	WEIGHT (LBS.)	MANUFACTURER	MODEL #	SEER	ELECTRICAL DATA	MCA/ MOP	WEIGHT (LBS.)	MANUFACTURER	MODEL #
AHU-2/HP-2	IT OFFICE	800	0.5"	1/3	HIGH	0	24,000	17,100	3	80	67	22,800	6.6	4.0	14,700	2.7	2.7	208V/1Ø	5/15	120	TRANE	5TEM4B02AC21SA	14.0	208V/1Ø	15/20	175	TRANE	5TWR402A1000A

NOTE:
1) CAPACITIES ARE BASED ON 80°F DB/67°F WB ENTERING AIR.

EXISTING ELECTRIC WATER HEATER SCHEDULE


ITEM#	AREA SERVED	NOMINAL TANK SIZE (GAL.)	PIPE CONNECTIONS INLET	PIPE CONNECTIONS OUTLET	K.W. UPPER/ LOWER	ELECTRICAL DATA	MANUFACTURER	MODEL #
EXISTING WATER HEATER	ALL FLOORS	40	3/4"	3/4"	4.5/4.5	208V/1Ø	A.O. SMITH	DEN-40 110

EXHAUST FAN SCHEDULE

ITEM#	AREA SERVED	C.F.M.	SONES	H.P./ WATTS	FAN TYPE	E.S.P.	DRIVE TYPE	R.P.M.	ELECTRICAL DATA	CONTROL	WEIGHT (LBS.)	MANUFACTURER	MODEL #
EF-1	BASEMENT TOILET ROOM	100	3.0	45	CEILING	0.375	DIRECT	1,100	120V-1PH	LIGHT SWITCH	15	COOK	GN-148
EF-2	BASEMENT TOILET ROOM	100	3.0	45	CEILING	0.375	DIRECT	1,100	120V-1PH	LIGHT SWITCH	15	COOK	GN-148

INTERNATIONAL MECHANICAL VENTILATION CODE

SPACE NAME	SQ.FT. (Az)	AREA OUTDOOR AIR RATE (Ra) table 403.3 CFM/ SQ.FT.	AREA OUTDOOR AIR (RaAz)	OCCUPANT LOAD RATE table 403.3 #PEOPLE/ 1,000 SQ.FT.	TOTAL # OF PEOPLE (Pz)	OCCUPANT OUTDOOR AIR RATE (Rp) table 403.3 CFM/ PERSON	OCCUPANT OUTDOOR AIR (RpPz)	BREATHING ZONE OUTDOOR AIR (Vbz) =RpPz+RaAz	ZONE AIR DISTRIBUTION EFFECTIVENESS (Ez) table 403.3.1.2 (FACTOR)	ZONE OUTDOOR AIR (Voz) =Vbz/Ez	TOTAL "SUPPLY" AIR TO SPACE (Vpz)	OUTDOOR AIR FRACTION (Zp) =Voz/Vpz
215 Print Area	255	.06	15.3	5	1	5	6.4	21.7	0.8	27.1	375	0.07
216 Open Office	415	.06	24.9	5	2	5	10.4	35.3	0.8	44.1	760	0.06
209 Office	65	.06	3.9	5	0	5	1.6	5.5	0.8	6.9	145	0.05
210 Office	65	.06	3.9	5	0	5	1.6	5.5	0.8	6.9	145	0.05
TOTALS=	800		48.0		4		20.0	68.0		85.0	1,425	

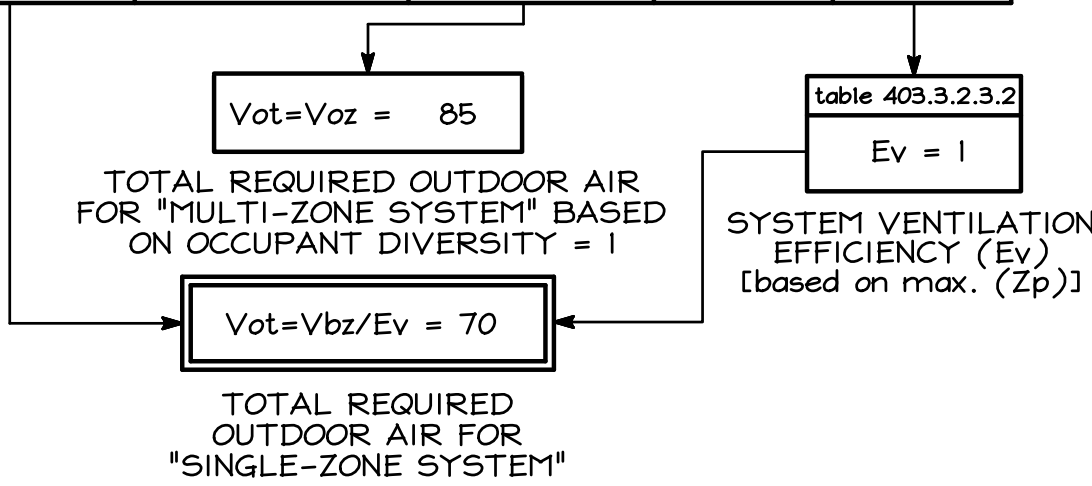

EXISTING SPLIT SYSTEM HEAT PUMP SCHEDULE

ITEM#	AREA SERVED	FAN DATA				COOLING DATA (BTUH)		HEATING DATA (BTUH)		INTERIOR MODEL #	EXTERIOR MODEL #
		C.F.M.	OUTSIDE AIR	H.P.	E.S.P.	TOTAL	ENTERING AIR DB°F	WB°F	INPUT		
EX. AHU-1/EX. HP-1	IT ROOM	800	-	1/3	0.375"	24,000	80	67	22,800	TRANE 5TEM4B02	TRANE 5TWR4024
EX. AHU-3/EX. HP-3	BASEMENT	1,600	470	3/4	0.50"	48,000	80	67	34,120	CARRIER FB4A-048	CARRIER 38YCKC48

PLUMBING FIXTURE SCHEDULE


ITEM#	DESCRIPTION	PIPE SIZES				TRAP TYPE	REMARKS
		C.I.W.	H.W.	SAN.	VENT		
P-1A	WATERCLOSET (FLUSH VALVE)	1/2"		4"	2"	INTEGRAL	HANDICAPPED
P-3A	COUNTERTOP LAVATORY	1/2"	1/2"	2"	2"	"P"	HANDICAPPED
P-4	KITCHEN SINK	1/2"	1/2"	2"	2"	"P"	

EXISTING GAS FIRED ROOFTOP UNIT SCHEDULE

ITEM#	AREA SERVED	FAN DATA				COOLING DATA (BTUH)		HEATING DATA (BTUH)		MODEL #
		C.F.M.	OUTSIDE AIR	H.P.	E.S.P.	TOTAL	ENTERING AIR DB°F	WB°F	INPUT	
EX. RTU-1	FIRST FLOOR	5,500	680	1.0	0.80"	184,600	77.5	64.8	275,000	48HJD017
EX. RTU-2	SECOND FLOOR	6,900	440	1.0	0.55"	189,000	76.3	63.8	275,000	48HJD017

INTERNATIONAL MECHANICAL VENTILATION CODE


SPACE NAME	SQ.FT. (Az)	AREA OUTDOOR AIR RATE (Ra) table 403.3 CFM/ SQ.FT.	AREA OUTDOOR AIR (RaAz)	OCCUPANT LOAD RATE table 403.3 #PEOPLE/ 1,000 SQ.FT.	TOTAL # OF PEOPLE (Pz)	OCCUPANT OUTDOOR AIR RATE (Rp) table 403.3 CFM/ PERSON	OCCUPANT OUTDOOR AIR (RpPz)	BREATHING ZONE OUTDOOR AIR (Vbz) =RpPz+RaAz	ZONE AIR DISTRIBUTION EFFECTIVENESS (Ez) table 403.3.1.2 (FACTOR)	ZONE OUTDOOR AIR (Voz) =Vbz/Ez	TOTAL "SUPPLY" AIR TO SPACE (Vpz)	OUTDOOR AIR FRACTION (Zp) =Voz/Vpz
001 Storage	55	.12	6.6	0	0	0	0.0	6.6	0.8	8.2	100	0.08
003 Lounge	620	.06	37.2	10	6	5	31.0	68.2	0.8	85.3	305	0.28
005 Utility	120	.06	7.2	10	1	5	6.0	13.2	0.8	16.5	140	0.12
006 Conference Room	500	.06	30.0	50	25	5	125.0	155.0	0.8	193.8	360	0.54
007 Restroom	55	0	0.0	0	0	0	0.0	0.0	0.8	0.0	0	####
008 Restroom	55	0	0.0	0	0	0	0.0	0.0	0.8	0.0	0	####
009 Secure Storage	475	.12	57.0	0	0	0	0.0	57.0	0.8	71.2	180	0.40
010 Secure Storage	135	.12	16.2	0	0	0	0.0	16.2	0.8	20.2	140	0.14
011 Work Space	480	.06	28.8	5	2	5	12.0	40.8	0.8	51.0	300	0.17
012 Corridor	310	.06	18.6	0	0	0	0.0	18.6	0.8	23.3	75	0.31
TOTALS=	2,805		201.6		35		174.0	375.6		469.5	1,600	

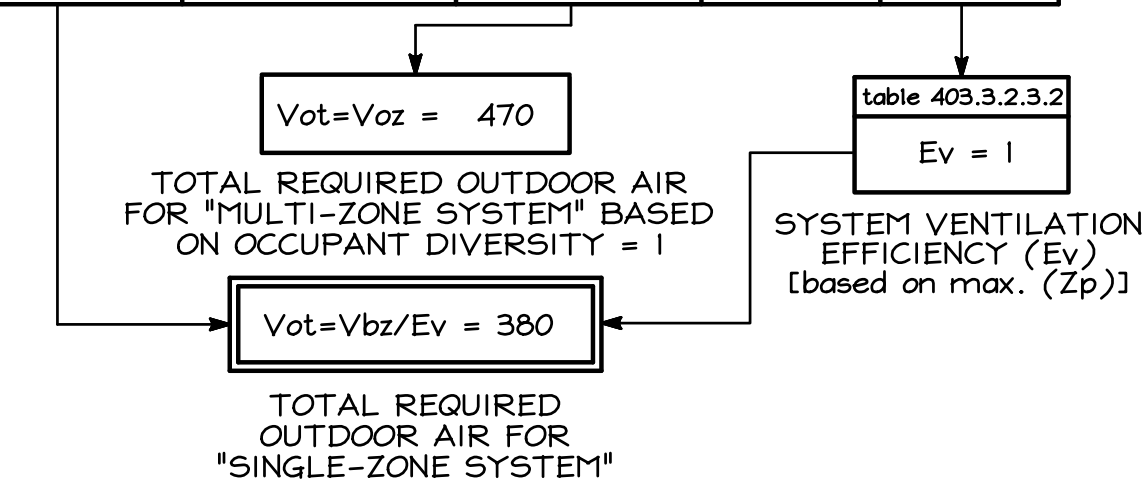

EXISTING SCHEDULE VARIABLE AIR ZONE DAMPERS

ITEM#	COOLING DATA		P.D. IN H ² O	INLET AREA SQ.FT.	DAMPER SIZE	MANUFACTURER	MODEL #
	MAX. C.F.M.	MAX. F.P.M.					
①	544	700	0.02	0.79	12"Ø	CARRIER	ZDI2
②	320	700	0.02	0.55	10"Ø	CARRIER	ZDI0
③	675	700	0.02	1.07	14"Ø	CARRIER	ZDI4
④	1000	714	0.02	1.40	16"Ø	CARRIER	ZDI6
⑤	550	700	0.02	0.79	12"Ø	CARRIER	ZDI2
⑥	640	700	0.02	1.07	14"Ø	CARRIER	ZDI4
⑦	295	700	0.02	0.55	10"Ø	CARRIER	ZDI0
⑧	560	700	0.02	0.78	14"x8"	CARRIER	RDO814
⑨	745	600	0.02	1.07	14"Ø	CARRIER	ZDI4
⑩	2745	1500	0.02	2.0	18"x16"	RUSKIN	-
⑪	2745	1500	0.02	2.0	18"x16"	RUSKIN	-
⑫	900	700	0.02	1.4	16"Ø	CARRIER	ZDI6
⑬	1050	700	0.02	1.5	16"x14"	RUSKIN	-
⑭	240	700	0.02	0.35	8"Ø	CARRIER	ZD08
⑮	750	700	0.02	1.07	16"Ø	CARRIER	ZDI4
⑯	1150	700	0.02	1.64	18"x14"	RUSKIN	-
⑰	640	700	0.02	0.35	8"Ø	CARRIER	ZD08
⑱	700	600	0.02	1.4	16"Ø	CARRIER	ZDI6
⑲	190	600	0.02	0.35	8"Ø	CARRIER	ZD08
⑳	370	700	0.02	0.55	10"Ø	CARRIER	ZDI0
㉑	760	700	0.02	1.07	14"Ø	CARRIER	ZDI4
㉒	6900	1500	0.02	4.6	36"x18"	RUSKIN	-

FARMERS & MERCHANTS
BANK
25 WESTMINSTER PIKE
REISTERTOWN, MARYLAND, 21136
INTERIOR ALTERATION

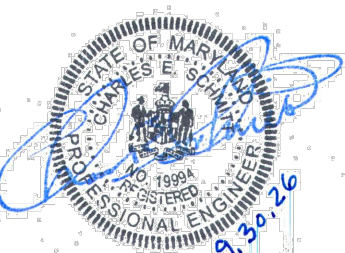

I CERTIFY THAT THESE DOCUMENTS WERE PREPARED OR APPROVED BY ME AND THAT I AM A DULY LICENSED PROFESSIONAL ENGINEER UNDER THE LAWS OF THE STATE OF MARYLAND.

LICENSE NO.: 19994
EXP. DATE: 3/31/2027

THESE DRAWINGS ARE NOT PERMITTED TO BE COPIED OR REPRODUCED, EITHER WHOLLY OR PARTIALLY, UNLESS WRITTEN PERMISSION IS FIRST OBTAINED FROM SANDERS DESIGNS, P.A.


MECHANICAL & ELECTRICAL
DESIGN CONSULTANTS, INC.
1907 N. Fountain Green Road
Bel Air, Maryland 21015-1411
410-869-3282 • Fax 410-869-0442
Web Site: www.jrdesign.net

SANDERS | DESIGNS
ARCHITECTS PLANNERS
WWW.SANDERSDESIGNS.COM
MAILBOX@SANDERSDESIGNS.COM
9727 GREENSIDE DRIVE, SUITE 202, COCKEYSVILLE, MARYLAND 21030
T: (410) 860 2624


No.	Date	Revision

Project No.:
Date:
Scale:
Edition:
PERMIT SET
Drawing Name:
MECHANICAL SCHEDULES
Drawing Number:

M-7

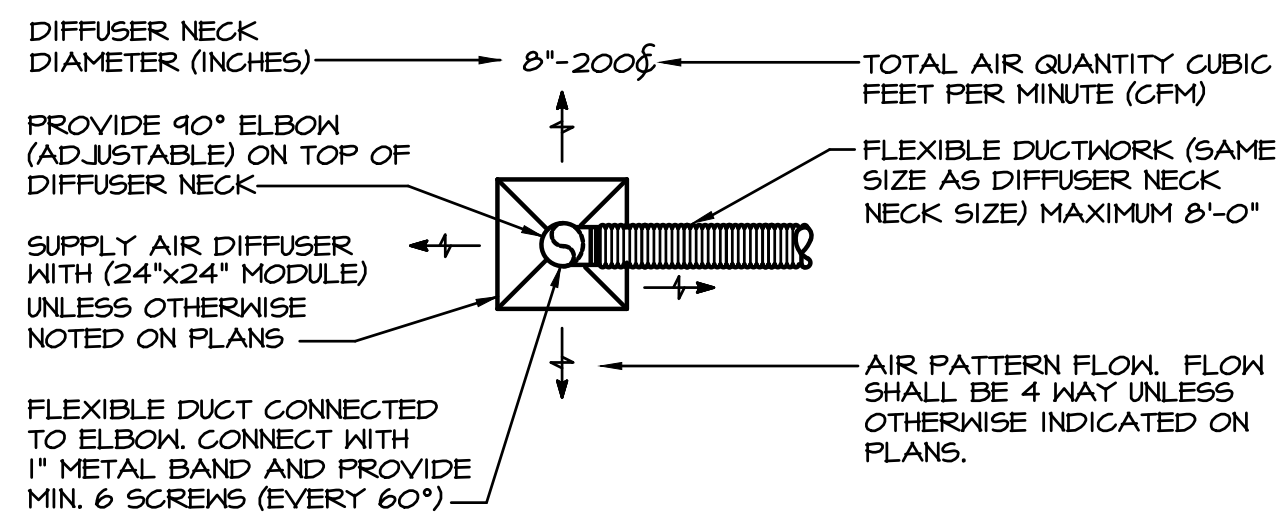


SUPPLY AIR DIFFUSER KEY
NO SCALE

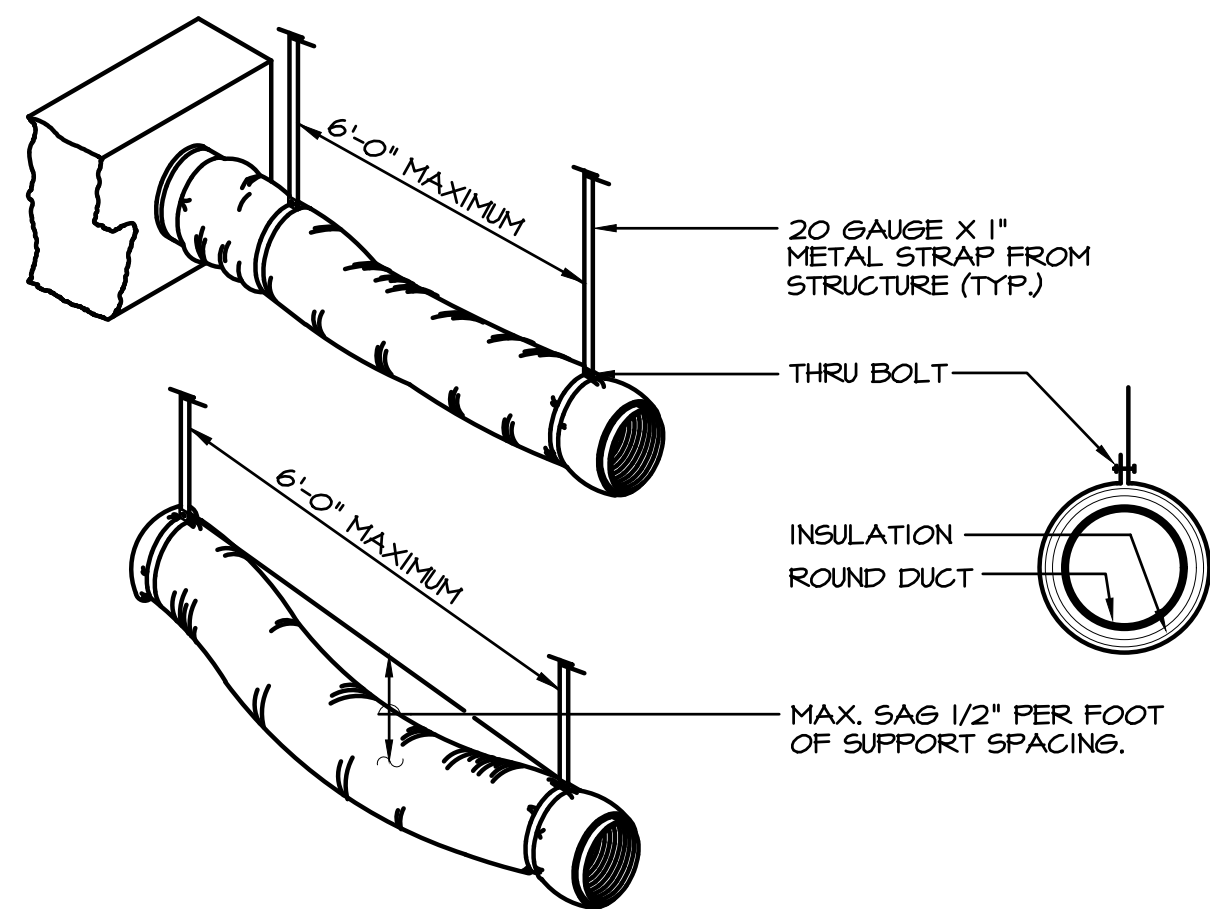

FLEXIBLE DUCT RUN-OUT SUPPORT DETAIL
NO SCALE


- NOTES:
- 1) FLEXIBLE DUCT SHOULD EXTEND STRAIGHT FOR SEVERAL INCHES FROM RECTANGULAR DUCT CONNECTION BEFORE BENDING.
 - 2) USE RIGID DUCTWORK WHEN FLEXIBLE DUCT LENGTH EXCEEDS 8'-0" IN LENGTH.

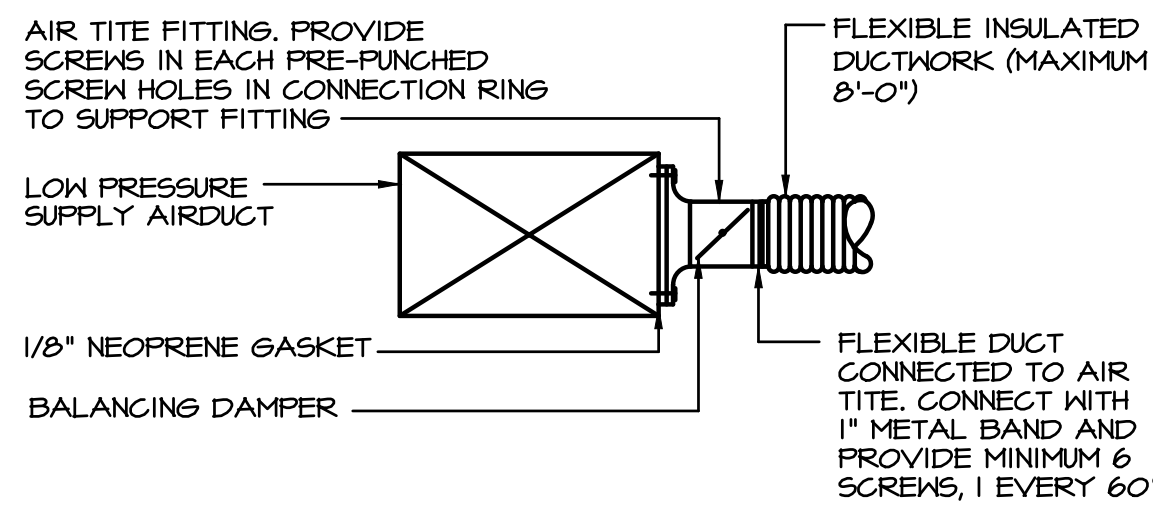

AIR TITE FITTING DETAIL
NO SCALE


AIR TITE SIZE CHART			
DUCT SIZE	CONNECTION RING	DUCT SIZE	CONNECTION RING
5"	8"	9"	12"
6"	9"	10"	13"
7"	10"	11"	15"
8"	11"	12"	17"

NOTE:
WHERE CONNECTION RING SIZE IS LARGER THAN SUPPLY DUCT, THEN CONNECTION RING SHALL BE CRIMPED OVER DUCT AND CONNECTED, SCREWED & SEALED ON TOP AND BOTTOM OF SUPPLY DUCT.

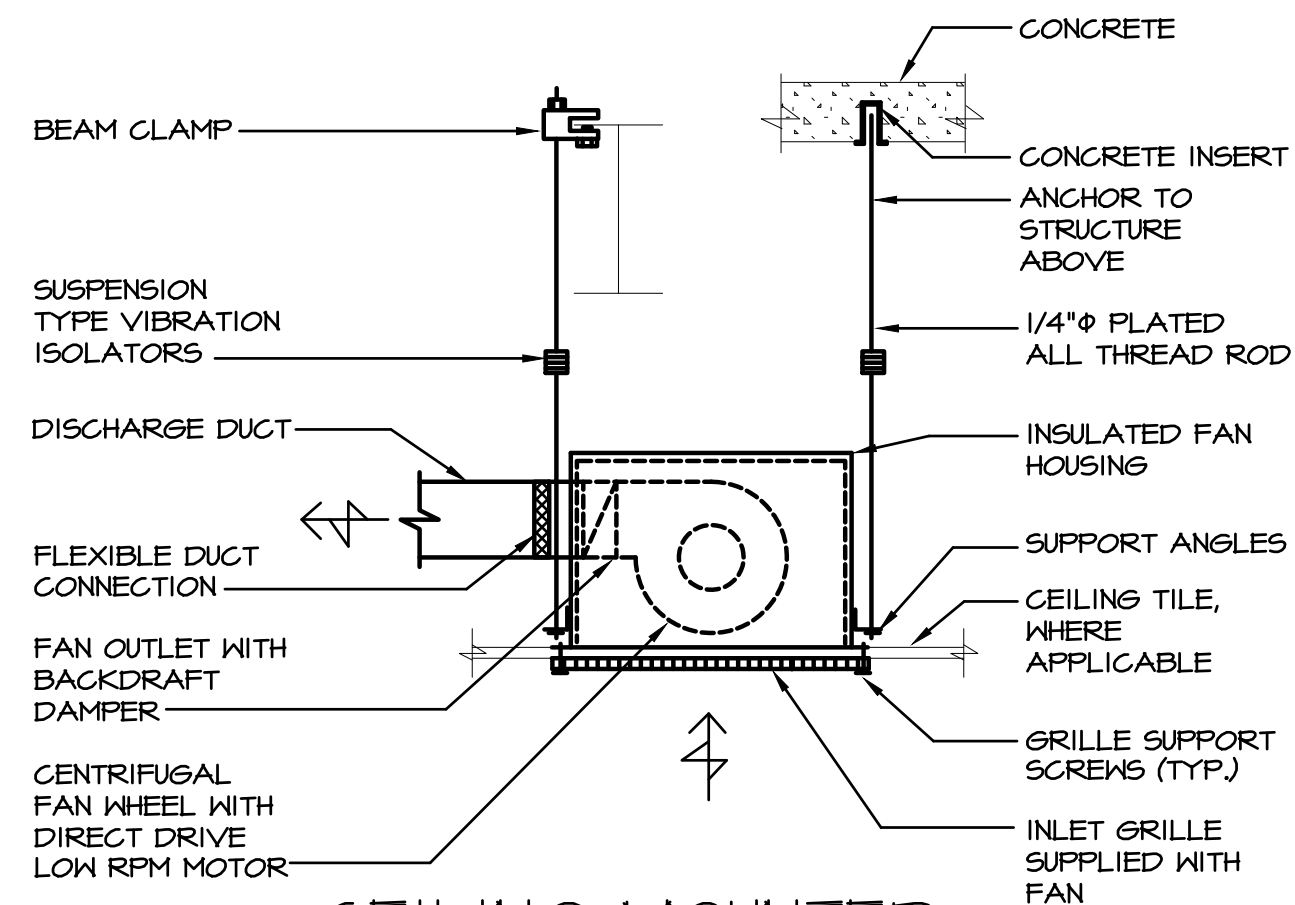


CEILING MOUNTED EXHAUST FAN DETAIL
NO SCALE

NOTE:
PROVIDE VARIABLE SPEED SWITCH ON THE SIDE OF THE CASING FOR FINAL AIR BALANCE.

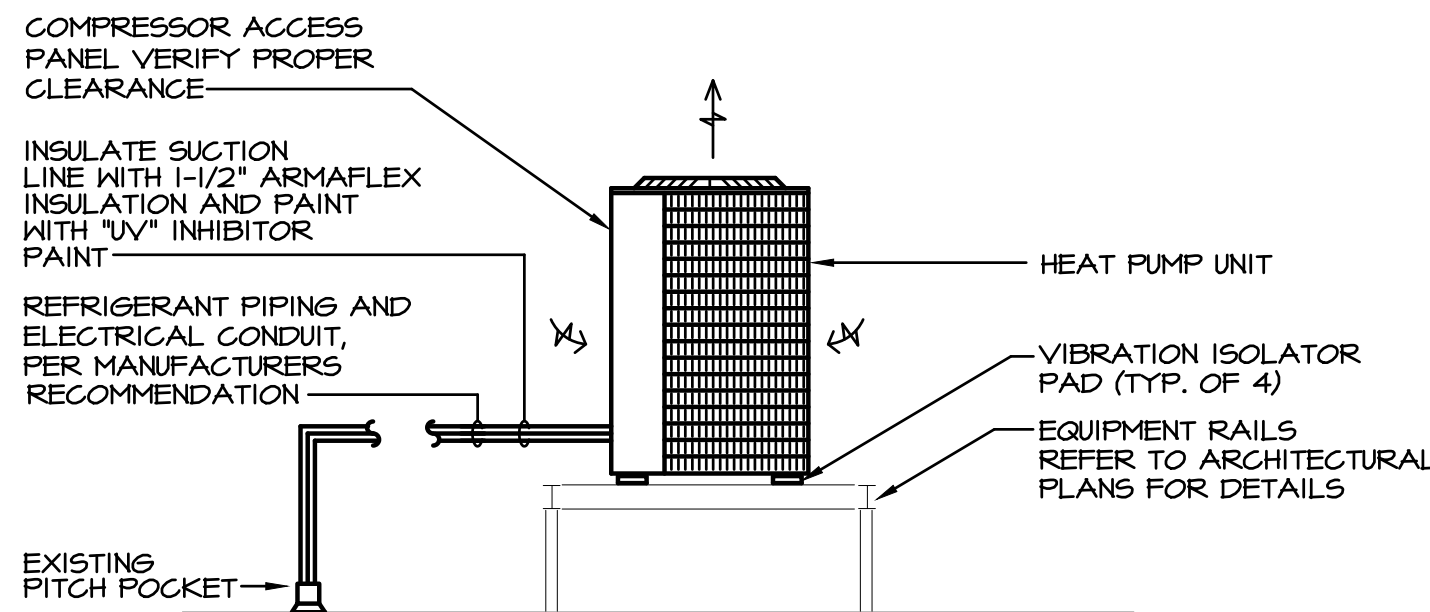


ROOF MOUNTED HEAT PUMP DETAIL
NO SCALE

- NOTES:
- 1) COORDINATE EXACT LOCATION OF "NEW" HEAT PUMP UNIT WITH "EXISTING" UNITS ON EXISTING EQUIPMENT FRAMING AND MAINTAIN PROPER CLEARANCE AROUND EACH UNIT PER MANUFACTURERS RECOMMENDATIONS.
 - 2) TRAP AND SIZE REFRIGERANT PIPING PER MANUFACTURE'S RECOMMENDATIONS.
 - 3) PROVIDE CROSS BRACING SUPPORT AS REQUIRED.

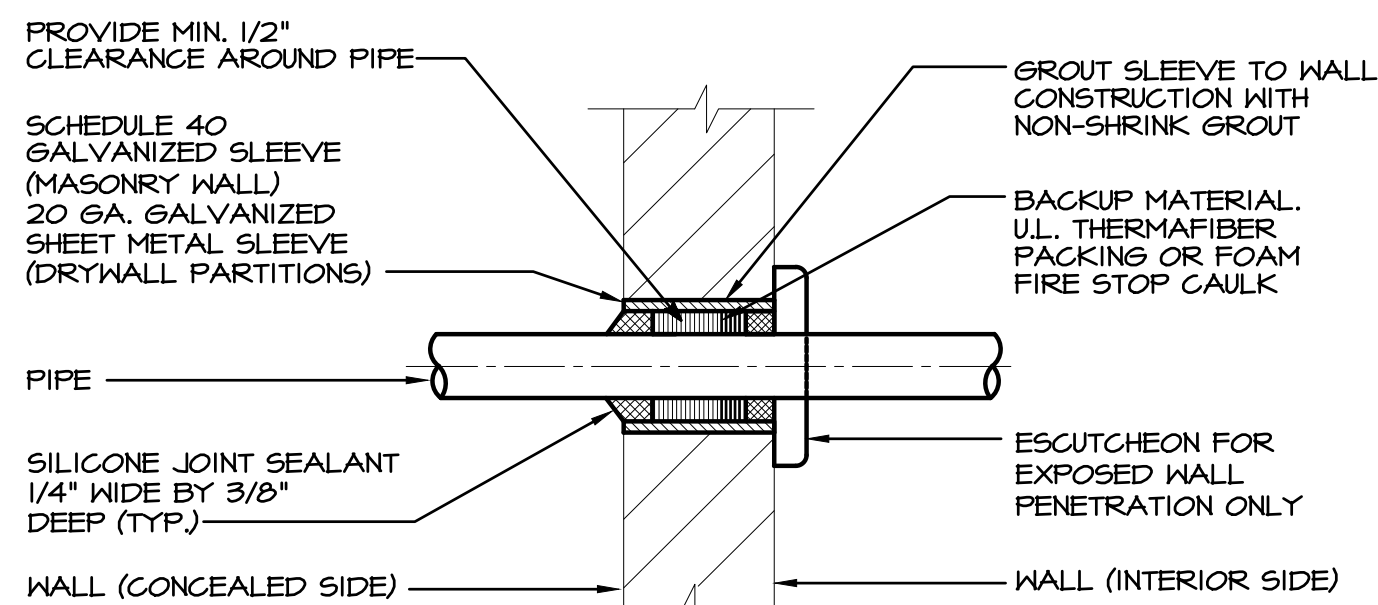

BARE PIPE

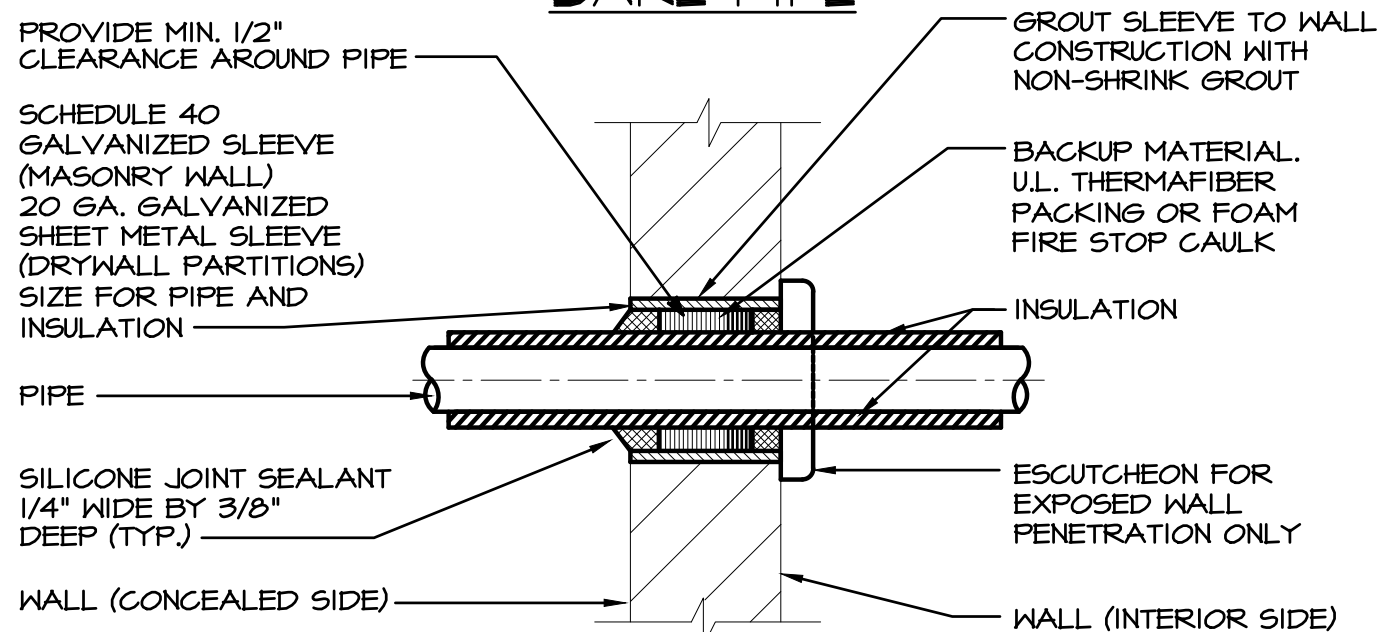


INSULATED PIPE

PIPE SLEEVE THRU WALL DETAIL


NO SCALE

- NOTES:
- 1) AT THE CONTRACTORS' OPTION A U.L. LISTED/APPROVED FIRE STOP PIPE SLEEVE ASSEMBLY MAY BE SUBMITTED FOR APPROVAL.
 - 2) FOR EXISTING POURED CONCRETED WALLS, CORE DRILL OR STAR DRILL OPENING THRU EXISTING WALL FOR PIPE SLEEVES AS DIRECTED.
 - 3) GALVANIZED SLEEVE SHALL BE CAST INTO NEW CONCRETE WALL POURS.

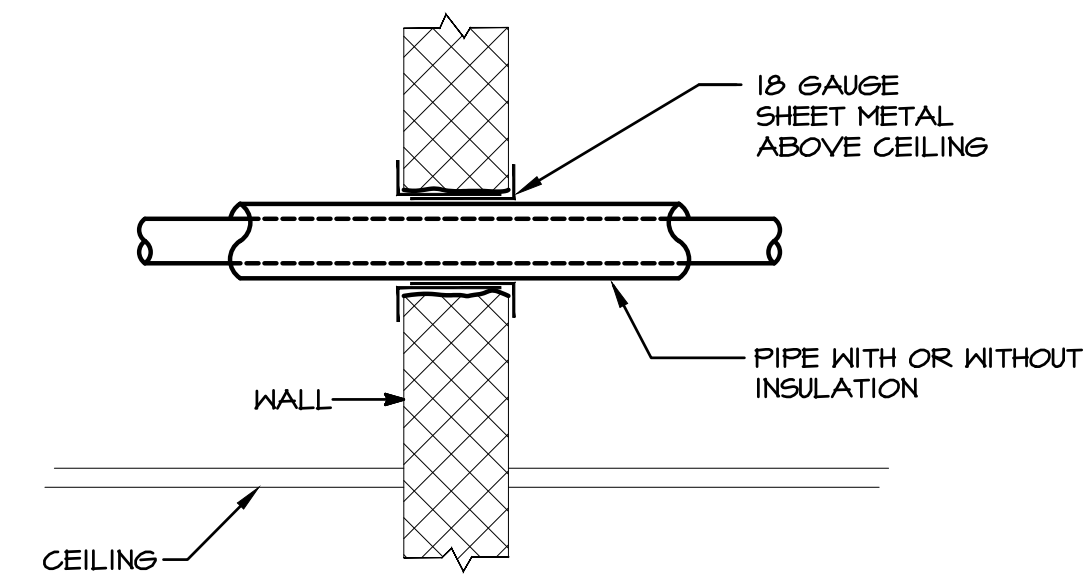


PIPE PENETRATION THRU WALL ABOVE CEILING
NO SCALE

- NOTES:
- 1) TYPICAL FOR NON-INSULATED PIPE AND CONDUIT.
 - 2) TYPICAL FOR MASONRY, CONCRETE OR DRYWALL WALL.
 - 3) FIRE RATED WALLS MUST BE SEALED WITH APPROPRIATE FIRE RETARDED CAULKING.

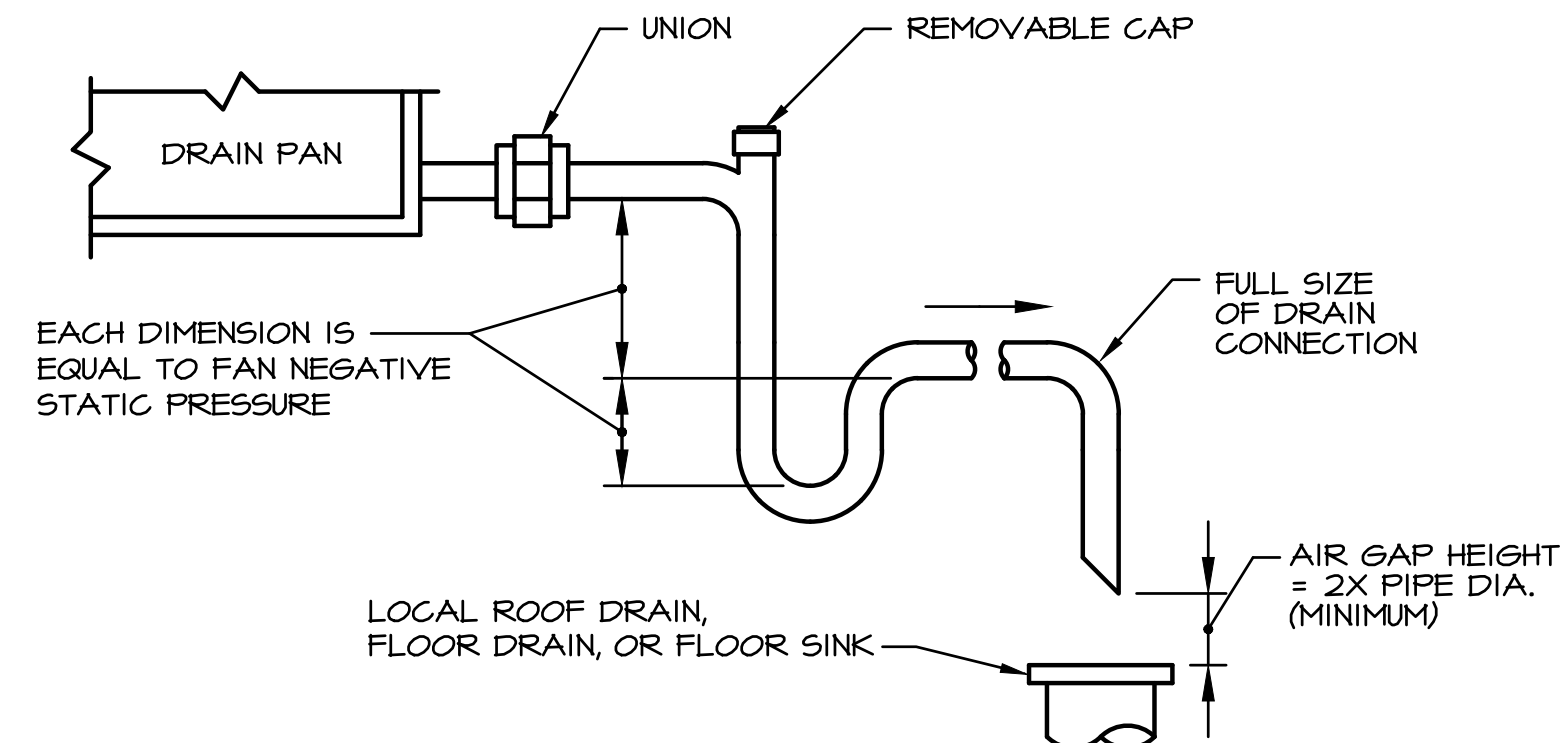


CONDENSATE DRAIN DETAIL
NO SCALE

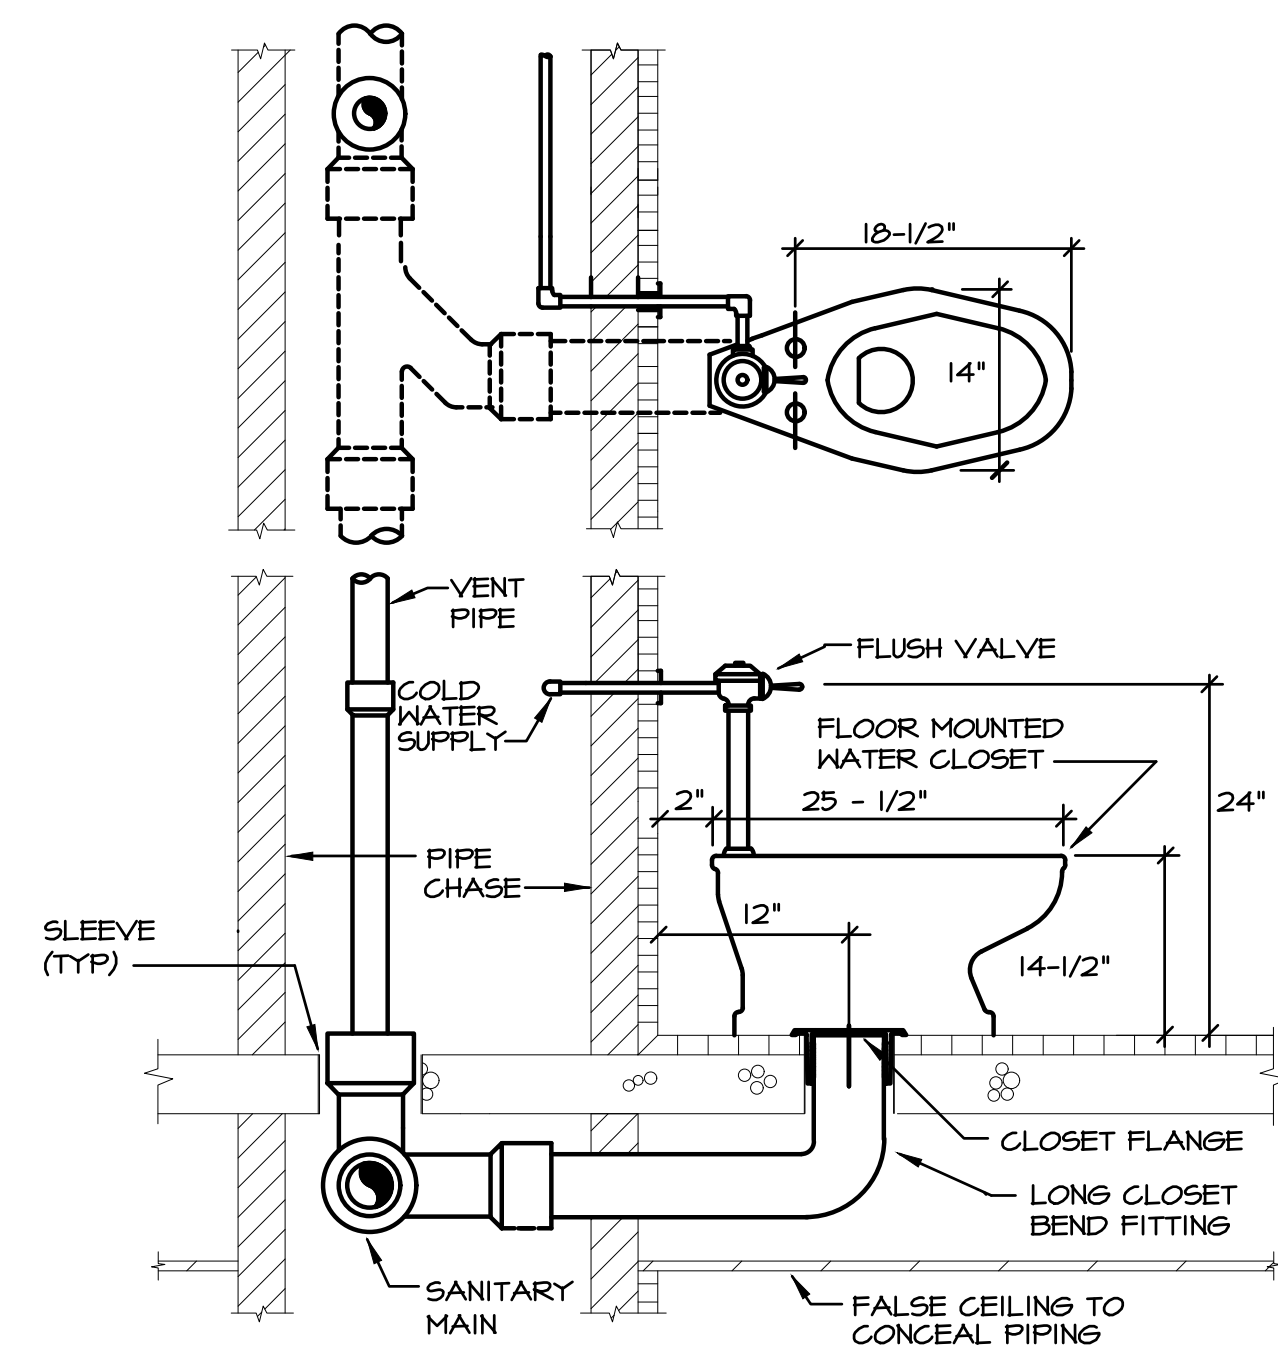

FLOOR MOUNTED WATER CLOSET
NO SCALE

FARMERS & MERCHANTS BANK
25 WESTMINSTER PIKE
REISTERTOWN, MARYLAND, 21136
INTERIOR ALTERATION

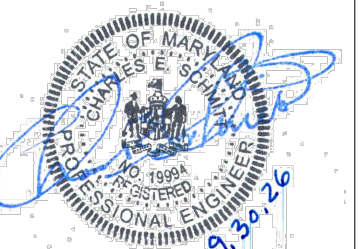

I CERTIFY THAT THESE DOCUMENTS WERE PREPARED OR APPROVED BY ME AND THAT I AM A DULY LICENSED PROFESSIONAL ENGINEER UNDER THE LAWS OF THE STATE OF MARYLAND.

LICENSE NO.: 19994

EXP. DATE: 3/31/2027

THESE DRAWINGS ARE NOT PERMITTED TO BE COPIED OR REPRODUCED, EITHER WHOLLY OR PARTIALLY, UNLESS WRITTEN PERMISSION IS FIRST OBTAINED FROM SANDERS DESIGNS, P.A.

Mechanical & Electrical Design Consultants, Inc.
1907 N. Fountain Green Road
Bel Air, Maryland 21015-1411
410-869-2822 • Fax 410-869-0442
Web Site: www.jrsdesign.net

SANDERS | DESIGNS ARCHITECTS PLANNERS
MAILBOX@SANDERSDESIGNS.COM
WWW.SANDERSDESIGNS.COM
9727 GREENSIDE DRIVE, SUITE 202, COCKEYSVILLE, MARYLAND 21030
T: (410) 860 2624

No.	Date	Revision

Project No.:
Date:
Scale:
Edition:
PERMIT SET
Drawing Name:
MECHANICAL DETAILS
Drawing Number:

M-8

MECHANICAL SPECIFICATIONS

I. SECTION I5010 - BASIC MECHANICAL REQUIREMENTS

- A. The work of each of the mechanical sections includes furnishing and installing the material, equipment and systems complete as specified and/or indicated on the drawings. The mechanical installations, when finished, shall be complete and coordinated, ready for satisfactory service.
- B. All work under this contract shall be done in strict accordance with all applicable municipal, state, Baltimore County, NFPA, International and local codes that govern each particular trade.
- C. The contractor shall make applications and pay all charges for all necessary permits, licenses and inspections as required under the above codes. Upon completion of the work, the customary certifications of approval shall be furnished.
- D. No materials or equipment shall be used in the work until approved. Before submission of the shop drawings, and not more than thirty(30) days after award of the contract, the contractor shall submit for approval a complete list of materials and equipment which he intends to furnish, giving manufacturer and catalog numbers. A complete list of proposed sub-contractors shall also be submitted.
- E. The contractor shall examine all drawings and specifications and shall inspect the existing conditions of the site. Failure to comply with this requirement will not relieve the contractor of responsibility for complying with the intent of the contract documents.
- F. The drawings indicate the general arrangement of the mechanical installations. Details of proposed departures due to actual field conditions or other causes shall be submitted for approval prior to installation. Reworking of completed items due to improper field coordination shall be at the contractor's expense.
- G. Provide sufficient access and clearance for all items of equipment requiring servicing and maintenance, such as valves, dampers, controls, drives, drains, vents, starters, switches, filters, traps and major items of equipment.
- H. The contractor shall perform all necessary cutting and patching as required to complete the installation of the mechanical work. Patching of walls, floors, ceilings, roof, etc. shall match the adjacent surfaces.
- I. The contractor shall prepare three (3) copies of a record and information booklet. The booklet shall be bound in a three ring loose-leaf binder. Provide the following data in the booklet.
- 1) Catalog data on each piece of equipment furnished
- 2) Approved shop drawings on each piece of equipment furnished
- 3) Maintenance, operation and lubrication instruction on each piece of equipment furnished
- 4) Simplified temperature control diagram
- 5) Manufacturer's and contractor's guarantees
- 6) Air and water balancing reports
- 7) Commissioning reports
- 8) Schedule/description of all service work/maintenance inspections required by the paragraphs of this section
- J. The entire new plumbing system shall be tested hydrostatically before insulation covering is applied and proved tight under the following gauge pressures:
- Sanitary piping as specified below
- Domestic water piping 100 psig
- Refrigeration liquid and suction piping 225/400 psig
- Fire protection piping Per NFPA
- K. All soil, waste and vent piping shall be tested by the contractor. The entire new drainage system and venting system shall have all necessary openings plugged and filled with water to the level of ten (10) feet above the main or branch being tested. The system shall hold this water for thirty (30) minutes without showing a drop greater than four (4) inches.
- Note: If any code or authority requires testing which is different than the test listed above, the more stringent test shall be performed.
- L. All parts of the heating, ventilating, air conditioning and exhaust systems shall be adjusted, checked, balanced and tested by an independent A.A.B.C. certified testing and balancing contractor approved by the owner. The contractor shall put all systems and equipment into full operation, and shall test and balance all devices to within ten (10) percent of capacities indicated on the drawings. Submit copies of the balancing reports as required by the contract. Permanently mark the position of each balancing damper.
- M. Upon completion of the mechanical installations, the contractor shall provide a complete set of prints of the mechanical contract drawings which shall be legibly marked in red pencil to show all changes and departures of the installation as compared with the original design. They shall be suitable for use in preparation of record drawings.
- N. All piping and valve systems shall be identified with labels and tags. Materials shall be as manufactured by Seton name plate corporation.
- O. All new mechanical installations, including all materials and labor shall be guaranteed for a period of one (1) year from date of owner acceptance. The above shall not in any way void or abrogate equipment manufacturer's guarantee or warranty. Certificates of guarantee shall be delivered to the owner.
- P. Contractor shall also provide one (1) year free service to keep the equipment in operating condition. This service shall be provided per the following schedule and rendered upon request when notified of any equipment malfunction.
- Q. In addition to the first year warranty period, the contractor shall provide, at no additional cost to the owner, a minimum of four (4) service calls and maintenance inspections. A complete outline of the required maintenance and the proposed schedule shall be included in the "record and information booklet" detailed in Section I5010-Basic Mechanical Requirements, paragraph I, for review and acceptance by the owner/representative and engineer. The inspections are to be performed at three (3) month intervals for a total of four (4) service calls and inspections during the first year warranty period [three (3) times during the year plus the original system start-up commissioning. The service work and inspections shall include, but not be limited to the following:

- Replace all disposable air filters;
- Clean all permanent air filters;
- Lubricate all motor and fan bearings as required;
- Clean drain pans and drain lines;
- Check and tighten all electrical connections;
- Inspect all belts for adjustment and condition and replace as required;
- Inspect and clean all water strainers;
- Check operating pressures and refrigerant charge;
- Inspect all controls for correct operation and calibrate as required;
- Perform all maintenance as outlined in the equipment manufacturers operation and maintenance manuals.

Upon completion of each scheduled inspection, the contractor shall deliver to the building owner/owner's representative within (48) hours of completion, two (2) copies the completed inspection report for record purposes.

- R. The mechanical or service contractor shall, at the ninth month, advise the owner of the termination date of the above service. This contractor shall also provide the owner with a detailed proposal, reflecting annual escalation, for the continuation of the service and inspections described above.

2. SECTION I5050 - BASIC MECHANICAL PIPING MATERIAL & METHODS

- A. Provide all labor and materials necessary to furnish and install all piping systems on this project, including interior storm, sanitary, sanitary vent, domestic water, condensate drainage, heating water, chilled water, condenser water, steam, steam condensate, natural gas, refrigerant and medical gas piping systems.

- B. Piping and valves shall be as follows:

1) Storm and sanitary drains and sanitary vents above floor inside building:

Piping: Cast iron no-hub soil pipe and/or schedule 40 galvanized steel pipe and/or type DWV copper.

Fittings: Cast iron no-hub soil pipe fittings and/or galvanized drainage fittings and/or copper solder joint cast drainage fittings.

Joints: No-hub stainless steel gasketed fittings and/or solvent sealer and/or solder type wrought copper.

- OR -

Piping: Schedule 40 PVC DWV pipe.

Fittings: Solvent weld joints.

** Sanitary piping located above food prep/storage/display, serving or dining areas shall be copper piping with soldered connections. Any water closets located on floor above these same areas shall be wall mounted fixtures.

2) Domestic hot and cold water piping inside building:

Piping: All water pipings shall be hard copper, type L above ground, type K below ground.

Fittings: Lead free solder type wrought copper.

Gate Valves: 2-1/2" or 3"= 150 psi, union bonnet, rising stem, solid wedge, bronze body, bonnet and stem. Nibco S-134.

Ball Valves: 2" or smaller= 150 psi, two piece body, full port, blowout-proof stem, chrome plated ball, bronze body and stem, reinforced TFE seat ring. Nibco S-585-70.

Unions: 125 psi., wrought copper, ground joint solder ends.

3) T&P relief piping:

Piping: type DWV seamless copper tubing

Fittings: wrought copper solder drainage fittings

4) Atmospheric condensate and indirect waste:

Piping: 1-1/4" or smaller= type DWV seamless copper tubing or schedule 40 plastic pipe. 2" or larger= schedule 40 plastic pipe.

Fittings: 1-1/4" or smaller= wrought copper solder drainage fittings or solvent sealed plastic fittings. 2" or larger= solvent sealed plastic fittings.

** All indirect waste lines shall be bolted to wall/floor with supports and flanges.

** All indirect waste piping greater than 24" in horizontal developed length or 48" in total developed length shall be provided with trap at equipment drain connection.

5) Refrigerant piping:

Piping: Type L hard copper refrigerant tube, dehydrated and sealed.

Fittings: Wrought copper solder type with silfos.

6) Fire protection: Piping and fittings as required by N.F.P.A. regulations and as hereinafter specified.

3. SECTION I5250 - MECHANICAL INSULATION

- A. All supply, return, make-up air, outside air ductwork and all storm water, domestic water, chilled water, heating water, dual temperature water and steam and steam condensate piping systems shall be insulated with fiberglass insulation.

- B. Ductwork shall be wrapped with nominal 2" thick glass fiber blanket insulation with thermal conductivity 'K' value of 0.27 at 75°F mean temperature and "installed" thermal resistance 'R' value of 8.0 at 1-1/2" compressed/installed thickness. Owens Corning "SOFTFR" fiberglass type ISO with foil faced vapor barrier. Insulation shall be neatly installed and suitable for 40°F-250°F duct temperatures.

- C. Pipe insulation shall be premolded fiberglass insulation with an all service jacket, Owens Corning fiberglass SSL-111. Fittings shall be insulated and covered with PVC covers. All piping 1-1/4" and smaller shall have 1" of insulation and all piping between 1-1/2" and 3-1/2" shall have 1-1/2" of insulation.

- D. All refrigerant piping shall be wrapped with 1-1/2" armaflex insulation. Insulation exposed to the weather shall be protected from damage, including that caused by sunlight, moisture, equipment maintenance and wind, and shall have shielding from solar radiation that can cause degradation of material. Adhesive tape shall not be permitted.

- E. (per 2021 IECC) All refrigerant suction piping (compressor outdoor) shall have 1" of insulation and all suction piping (compressor indoors) shall have 1-1/2" insulation. Liquid line piping shall not require insulation.

- F. Interior duct lining shall be as specified under section I5880.

4. SECTION I5300 - FIRE PROTECTION

- A. All work, materials, equipment and accessories shall comply with the standards of the National Fire Protection Association and all state and local regulations. System shall be in accordance with NFPA 13 for sprinkler design, NFPA 13 for general storage protection and NFPA 13 for rack storage.

- B. Under the existing/new addition design the plumbing contractor shall coordinate the incoming combination water system and split inside the building. The plumbing contractor shall install the OS&Y valves and a double U.L. double check valve/backflow preventer. The final rough in from the plumber for the sprinkler contractor shall be a flanged/ capped connection in the sprinkler room.

- C. Install a new wet pipe sprinkler system to properly cover/protect the new architectural design. System shall generally be light hazard, except ordinary hazard in all storage rooms, electrical rooms, etc. The sprinkler contractor shall extend the wet pipe sprinkler system from stub, to properly cover/protect entire building. Final density flow per square foot shall be determined by fire marshal.

- D. The new installation shall include, but are not limited to valves, flow switches, sprinkler heads and escutcheons, piping, fittings, hangers, signs and other identification markings, as required.

- E. The sprinkler contractor shall carefully examine all documents during the bidding period. He shall familiarize himself with project conditions such as building construction, pipe and ductwork locations and elevations.

- F. All new sprinkler heads shall be as required per NFPA 13. Sprinkler heads shall be installed to properly cover and protect the entire building. Any sprinkler heads installed in finished ceilings shall be brushed chrome semi recessed type. All heads in open structure or bay areas with no ceiling shall be bronze upright type.

- G. The sprinkler contractor shall arrange for approval of the new sprinkler systems and conduct tests in accordance with NFPA 13.

- H. The sprinkler contractor shall provide a detailed shop drawing showing piping layout, head location, elevations and coordination with all building structure, electrical and plumbing trades. The contractor shall submit detailed sprinkler shop drawings with actual heads for architect approval prior to any fabrication.

- I. The sprinkler contractor must submit one set of sprinkler shop drawings and hydraulic calculations to the local county fire marshal and/or fire department.

- J. The sprinkler contractor shall apply for and obtain a county permit for the work. The permit submittals usually include three copies of shop drawings, hydraulic calculations and catalog documentation of sprinklers and other system components.

5. SECTION I5400 - PLUMBING

- A. The work covered by this section of the specifications consists of furnishing all labor, equipment and materials in connection with the rough-in, final setting and connections to all plumbing fixtures. The contractor shall carefully review the conditions at the site and all of the contract drawings to determine the extent of the new and renovation plumbing work required.

- B. All plumbing fixtures shall be complete in every detail with all trimmings and connections. All fixtures shall be designed to prevent the backflow of polluted water or waste into the water supply system. Fixtures shall be as listed below or approved equal:

P-1A Water Closet (handicapped): American Standard #2467.100.020 Cadet, floor mounted, bottom outlet, elongated rim bowl, 1.1 GPF with vitreous china construction, 2" trapway, 16-5/8" high, pressure-assisted EcoFlush technology, trim bolt caps, closet flange, 12" rough-in, Church open front white seat with cover, rigid supply with angle stop valve. Tank mounted flush handle must be on the side of the ADA turning radius.

P-1B Water Closet (handicapped): kohler #K-3578 floor mounted, rear outlet, elongated rim bowl, 1.0 GPF with vitreous china construction, 2" trapway, 16-5/8" high, flush mate technology, trim bolt caps, closet flange, 12" rough-in, Church open front white seat with cover, rigid supply with angle stop valve. Tank mounted flush handle must be on the side of the ADA turning radius.

P-3A Counter Top Lavatory (handicapped): Formica Everform Model #1513 Acrylic undermount single bowl rectangular vanity sink. Acrylic white finish. 7-1/6" deep x 16-3/4" Length x 14-15/16" Width Provide escutcheons, chrome tailpiece, offset "P" trap and trap nipple. Provide Moen #4425 "Chateau" 4" center set lavatory faucet with lever handles, brushed chrome finish plated deck mounted faucet with 1.2 gpm flow rate. Provide ASSE 1070 listed thermostatic mixing valve with optional thermal gauge.

P-4 Kitchen Sink (handicapped): Elkay #ECTSRAD33226TBG "Crosstown" double compartment with 18 gauge, type 304 stainless steel, self-rimming, 4 hole, with undercoating, 33"x22"x6" overall size. Sink shall be fitted with Elkay #LK100ICR faucet with ADA single lever handle, suing spout and side spray. Sink shall be complete with crumb cup strainer, rigid supplies with loose key stops, cast brass clean out, tubing to wall and escutcheons.

- C. Undersink thermostatic mixing valve shall be Nibco H-7721IK-TG or approved equal with ASSE1070 listing. Valve shall have lead free bronze body construction with adjustment cap, internal check valves, temperature gauge, and complete with 3/8" compression, elbow, and tee fittings. Temperature setting range shall be 80°F-120°F with a flow range of 0.5-2.5 gpm.

- D. Potable water systems shall be disinfected prior to use. The method to be followed shall be that prescribed by the health authority and code requirements.

6. SECTION I5500 - HEATING, VENTILATING & AIR CONDITIONING (HVAC)

- A. The work to be performed shall include all labor, materials and equipment necessary to furnish and install complete, all H.V.A.C. mechanical equipment as shown on drawings and/or hereinafter specified. It is the intent that the systems be installed complete with all items necessary to provide satisfactory service.

- B. All heating, ventilating and air conditioning equipment which contains compressors shall be provided with extended warranties covering the compressors for a minimum of four (4) years.

Air Cooled Heat Pump Unit:

Unit shall be outdoor mounted, air cooled, split system heat pump unit suitable for roof or grade installation. Unit shall consist of a hermetic compressor, an air cooled coil, propeller type condenser fan and a control box and shall discharge supply air as shown on the drawings. Unit shall be used in a refrigerant circuit to match up to a packaged fan coil or coil unit.

Unit shall be rated in accordance with the latest edition of ARI standard 210 and 270 and shall be certified for capacity, efficiency and sound. Unit shall also be listed in the latest ARI directory.

Unit construction shall comply with latest edition of ANSI/ASHRAE and with NEC. The Unit shall be constructed in accordance with U.L. standards and shall carry the U.L. label of approval. Unit cabinet shall be capable of withstanding Federal Test Method Standard No. 141(method 6061) 500-hour salt spray test. Air cooled condenser coils shall be leak tested at 150 psig and pressure tested at 300 psig.

Unit shall be factory assembled, single piece, air cooled air conditioner unit, contained within the unit enclosure is all factory wiring, piping, control compressor, refrigerant charge (R-410A) and special features required prior to field start-up.

Unit cabinet shall be constructed of galvanized steel, bonderized and coated with a powder coat paint. Condenser fan shall be direct drive propeller type, discharging air upward. Condenser fan motors shall be totally enclosed with class B insulation and permanently lubricated bearings. Shroud will be corrosion resistant. Fan blades shall be statically and dynamically balanced. Condenser fan openings shall be equipped with PVC coated steel wire safety guards.

Unit Compressor shall be hermetically sealed and mounted on rubber vibration isolators.

The heat pump coil shall be air cooled. Coil shall be constructed of aluminum fins mechanically bonded to copper tubes which are then cleaned, dehydrated and sealed.

Refrigeration circuit components shall include liquid line shut-off valve with sweat connections, suction shut-off valves with sweat connections, system charge of refrigerant R-410A and compressor oil.

Nominal unit electrical characteristics shall be as indicated on the drawings. Unit electrical power shall be single point connection. Control circuit will be 24v.

Unit accessories shall include Motor master head pressure control which shall permit unit to operate down to -20 degrees F and maintain normal system pressure operation. Low outdoor ambient temperatures, service entry shall lock compressor in case of safety switch trip and light a 24 volt signal light. Compressor shall have a 5 year warranty.

Unit shall be Trane, York, Carrier, or approved equal.

7. SECTION I5880 - AIR DISTRIBUTION

- A. Furnish all labor and materials necessary to complete the sheet metal work associated with the heating, ventilating, air conditioning and exhaust systems, and other miscellaneous items shown and required.

- B. All supply, return, make-up air, exhaust and Type 2 ductwork shall be constructed and installed in accordance with the sheet metal and air conditioning contractors national association (SMACNA) standards and ASHRAE standards.

- C. Flexible ductwork shall be ATCO # 031 or approved equal. Flexible duct shall comply with NFPA bulletin 90A and shall be U.L. Listed as class I air duct and connector, standard 181. Ductwork shall be insulated with R-8.0 insulation.

- D. Support horizontal ducts with hangers spaced not more than six (6) feet apart. Use strapangers for ducts up to thirty (30) inches wide, angle hangers or rods for ducts over thirty (30) inches wide. Strapangers to be one (1) inch wide, 20 gauge minimum; fasten to sides and bottom of duct with sheet metal screws.

- E. Ducts shall be straight and smooth on the inside, with joints neatly finished. Ducts shall be suspended from the construction and shall be free from vibration. Curved elbows shall have a center radius equal to one and one-half (1-1/2) times the width of the duct. All square turns shall be vaned. Vanes consisting of curved metal blades shall permit the air to make abrupt turns without turbulence.

- F. All joints in the heating, ventilating, and air conditioning and exhaust system ductwork shall be sealed. Sealant shall be as manufactured by Hard Cast Inc. or approved equal and shall consist of a mineral impregnated woven fiber tape and an actuator adhesive.

Sealant shall be SMACNA and U.L. approved, with a flame spread of 10 and a smoke developed of 0, non-toxic and non-flammable. Sealant shall be approved for operating temperatures from 0 degrees F. to 200 degrees F.

Sealant system shall be installed in strict accordance with the manufacturer's recommendations and when applied shall provide a permanent seal without any deterioration.

- G. All supply and return air ductwork within fifteen (15) feet of each air handling unit shall be lined on the interior for sound attenuation. Lining shall have a one (1) inch thickness and shall be glued with one hundred (100) percent coverage and additionally secured with pins. Increase duct sizes indicated two (2) inches direction to accommodate the interior lining. Dimensions shown on drawings are clear inside dimensions. Liner shall be a non-fibrous elastomeric thermal (and acoustical) material, closed cell, moisture resistant with anti-microbial agent. Material shall meet ASTM E84 25/50 fire rating (NFPA 90A # 90B), ASTM G 21 # 22, VOC guidelines, ASTM C 518, etc.. Lining shall be Nomaco K-Flex Gray, Evonikfoams Solcaoustic or approved equal.

- H. Supply air diffusers shall have all steel construction with louvered face and finished with #26 off-white enamel. Titus model TMS, Metal-Aire, Metal-Aire, Krueger or approved equal.

- I. Supply air diffusers shall have all steel construction with perforated face and finished with #26 off-white enamel. Titus model PSS, Metal-Aire, Krueger or approved equal.

- J. Return air grilles shall have all steel construction with perforated face and finished with #26 off-white enamel. Titus model PAR, Metal-Aire, Krueger or approved equal.

- K. Ceiling mounted fans shall be as manufactured by Cook. Fans shall have acoustically insulated housings and shall have a maximum sound level rating of 6.0 sones. Air deliveries shall be as indicated on the drawings and all fans shall bear the AMCA certified ratings seal and the U.L. label. Integral backdraft damper shall be totally chatter proof with no metal contact. Fan shall have true centrifugal wheels with inlet perpendicular, or remote from, inlet grille. Grille shall be of aerodynamic design of white molded plastic eggcrate shape and provide eighty-five (85) percent free open area, terminal box shall be provided on the housing with cord, plug, and receptacle inside the housing. Entire fan, motor and wheel assembly shall be easily removable without disturbing the housing. Motor speeds shall not exceed 1600 rpm and all fan motors shall be suitably grounded and mounted on rubber-in-shear vibration isolators.

8. SECTION I5950 - CONTROLS

- A. The controls contractor under this heading shall furnish and install all wiring necessary for a complete system of automatic temperature control, ventilation systems, exhaust systems, etc. as indicated on the drawings. The system shall include all necessary thermostats, relays, switches, transformers, contactors, etc. required for successful operation of all equipment as described in the sequence of operations. Electrical work in connection with all control systems shall be performed by the controls contractor and coordinated with the electrical contractor as needed to provide a full and complete package.

- B. Each (rooftop, split-systems, heat pumps, hot/chilled water systems) shall be controlled by a wall mounted heating/ cooling thermostat with a (7) day/(24) hour program clock capable of (2) occupied/ non-occupied periods, with (2) heating/ (2) cooling set points, remote temperature sensor capability and auxiliary contact for economizer controls. Thermostat shall have a 5 degree dead band during occupied mode and set for 70°F heating and 75°F cooling. During unoccupied mode, unit shall maintain 55°F heating and 85°F cooling. Thermostat shall be compatible with the unit's economizer and/or accessory package as specified under section I5500. Coordinate control requirements with the proposed H.V.A.C. Equipment.

- C. The automatic temperature control contractor shall be responsible for the commissioning of the project to assure a fully functional, fine-tuned H.V.A.C. system upon occupancy. The commissioning of the project shall be performed in accordance with american society of heating, refrigerating and air conditioning engineers, inc. (ASHRAE) pamphlet 1-1989 guideline for commissioning of H.V.A.C. systems. Commissioning is defined as verification of the proper operation of all equipment, alarms, safeties and control and energy management systems serving mechanical systems installed or modified on this project as defined within the specifications and indicated on the contract drawings.


Proper operation is defined as the activation of all controls, field or factory installed, to assure the correct sequencing of equipment and systems, including activation of all operating and safety controls, as hereinbefore described.

The automatic temperature control contractor shall report all system deficiencies to the mechanical contractor. The mechanical contractor shall instruct the proper trade to correct any deficiencies reported by the automatic temperature control contractor so that the project commissioning can be completed.

Prior to the commencement of any commissioning work, the automatic temperature control contractor shall provide the engineer with a commissioning report format for review and approval. The report format shall be delivered to the engineer not more than thirty (30) days after award of the A.T.C. contract or not less than sixty (60) days prior to start of A.T.C. work, whichever is earlier.

Commissioning report format shall include a list of all items to be verified, with the initials of the mechanic who verified the particular item/control and the date on which each item/control operation was verified.

Three (3) commissioning reports are required. The first report shall be completed during the initial commissioning of the project prior to occupancy. The hazard and third reports shall be completed no more than two (2) months (1 report/month) after occupancy of the building. All controls/safeties shall be verified in the presence of the owner or the owner's representative. The final report shall also contain the signature of the owner or owner's representative for each item verified.

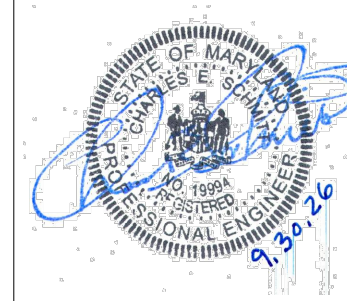

I CERTIFY THAT THESE DOCUMENTS WERE PREPARED OR APPROVED BY ME AND THAT I AM A DULY LICENSED PROFESSIONAL ENGINEER UNDER THE LAWS OF THE STATE OF MARYLAND.

LICENSE NO.: 19994

EXP. DATE: 3/31/2027

THESE DRAWINGS ARE NOT PERMITTED TO BE COPIED OR REPRODUCED, EITHER WHOLLY OR PARTIALLY, UNLESS WRITTEN PERMISSION IS FIRST OBTAINED FROM SANDERS DESIGNS, P.A.

MECHANICAL & ELECTRICAL DESIGN CONSULTANTS, INC.
1907 N. Fountain Green Road
Bel Air, Maryland 21015-1411
410-869-3282 • Fax 410-869-0442
Web Site: www.jrsdesign.net

JRS

SANDERS | DESIGNS ARCHITECTS PLANNERS
WWW.SANDERSDESIGNS.COM
MAILBOX@SANDERSDESIGNS.COM
9727 GREENSIDE DRIVE, SUITE 202, COCKEYSVILLE, MARYLAND 21030
T: (410) 860 2624

No.	Date	Revision

Project No.:
Date:
Scale:
Edition:
PERMIT SET
Drawing Name:
MECHANICAL SPECIFICATIONS
Drawing Number:

GENERAL PROJECT NOTES

- UNLESS NOTED OTHERWISE, ALL WIRING & CONDUIT / CABLING SHOWN IS FOR DIAGRAMMATIC PURPOSES ONLY. COORDINATE INSTALLATION WITH ACTUAL FIELD CONDITIONS AND INSTALL PER SPECIFICATIONS. ALL WORK TO BE VERIFIED ON SITE. ANY CONFLICTS ARE TO BE REPORTED BACK TO THE ENGINEER FOR REVIEW PRIOR TO PROCEEDING.
- WHERE APPLICABLE, ALL 2X2 LIGHT FIXTURES ARE TO BE INSTALLED IN THE SAME ORIENTATION SO SUSPENDED BASKETS, LENSES, VISIBLE LAMPS, ETC. ARE ALL FACING THE SAME DIRECTION.
- REFER TO ARCHITECTURAL OR PHASING DRAWINGS FOR OVERALL PROJECT PHASING. PLAN AND COORDINATE THE WORK AS REQUIRED.
- ANY EXISTING PANELBOARDS THAT WERE MODIFIED UNDER THIS CONTRACT ARE TO BE PROVIDED WITH NEW UPDATED DIRECTORIES.
- ALL AREAS INDICATED WITH VACANCY SENSORS (VS) ARE TO BE WIRED FOR "MANUAL ON / AUTO OFF" (20 MINUTE MAX) OPERATION..
- ALL PANELBOARD SCHEDULES ARE BASED ON THE USE OF COPPER CONDUCTORS. WHERE ALUMINUM CONDUCTORS ARE PERMITTED BY THE SPECIFICATIONS, ADJUST CONDUCTOR AND CONDUIT SIZES TO MAINTAIN SAME AMPACITY RATINGS.
- ALL CONDUIT BOXES, CABLE TRAY, ETC. SHALL GENERALLY BE INSTALLED A MINIMUM OF 12" ABOVE CEILINGS. COORDINATE WITH OTHER TRADES PRIOR TO INSTALLATION.
- ALL CEILING MOUNTED DEVICES SHALL BE CENTERED IN 2X2 CEILING TILES OR IN HALF OF 2X4 TILES, AS APPLICABLE.
- ALL PROJECT CONDUIT AND CABLING SHALL BE INSTALLED ABOVE FINISHED CEILINGS WHERE POSSIBLE TO MINIMIZE VISIBILITY OF SUCH ITEMS. ALL CABLING INSTALLED IN EXPOSED STRUCTURE AREAS SHALL BE IN EMT CONDUIT INSTALLED TIGHT TO DECK ABOVE, EXCEPT FOR SHORT FINAL CONNECTIONS TO FIRE ALARM DEVICES, LIGHT FIXTURES, ETC. MC CABLE SHALL BE PERMITTED WHERE INSTALLED ABOVE FINISHED CEILINGS OR CONCEALED IN PARTITION WALLS.
- ALL CABLING TO BE PROPERLY SECURED FROM THE STRUCTURE ABOVE. DO NOT SUPPORT CABLE/CONDUIT FROM OTHER OBJECTS IN THE CEILING SPACE, INCLUSIVE OF CEILING TILE HANGERS.
- REFER TO ARCHITECTURAL DRAWINGS FOR CEILING TYPES, FINISHES, ETC. COORDINATE ALL LIGHT FIXTURE MOUNTING, FRAME KITS, ETC. AS REQUIRED.
- TEMPORARILY REMOVE EXISTING LAY-IN TILES AND / OR CEILING GRID SYSTEMS, AS REQUIRED TO PERFORM THE WORK OF THIS CONTRACT. REINSTALL ALL COMPONENTS AT COMPLETION OF WORK AND REPLACE ANY DAMAGED COMPONENTS.
- WHERE THE WORK OF THIS CONTRACT, INCLUDING THAT OF OTHER DISCIPLINES, REQUIRES THE REMOVAL AND REPLACEMENT OF THE CEILING, PROVIDE FOR REMOVAL AND REINSTALLATION OF ELECTRICAL DEVICES AND EQUIPMENT MOUNTED IN OR ON THE CEILING. ALTERNATIVELY, THE CONTRACTOR MAY PROVIDE TEMPORARY SUPPORT FOR SUCH DEVICES, INCLUDING REINSTALLATION INTO NEW CEILING.
- ALL LOW VOLTAGE CABLING INSTALLED ABOVE CEILINGS AND NOT IN RACEWAY SHALL BE PLENUM RATED.
- ALL BRANCH CIRCUITS SHALL UTILIZE INDIVIDUAL NEUTRAL CONDUCTORS. SHARED NEUTRALS AND MULTI-WIRE CIRCUITS ARE NOT PERMITTED UNLESS SPECIFICALLY PROVIDED WITH BREAKER/HANDLE TIES.
- ALL BRANCH CIRCUITS AND FEEDERS SHALL INCLUDE AN EQUIPMENT GROUNDING CONDUCTOR. CONDUIT IS NOT PERMITTED AS THE SOLE GROUND PATH.
- WHERE VOICE/DATA AND POWER OUTLETS APPEAR ON PLAN AS BACK TO BACK, OUTLETS SHALL BE STAGGERED TO REDUCE NOISE TRANSMISSION THROUGH WALL.
- ALL EMERGENCY AND EGRESS LIGHTING FIXTURES SHALL BE CONNECTED TO THE LIFE SAFETY EMERGENCY BRANCH CIRCUITS AHEAD OF ANY SWITCHING, UNLESS INDICATED OTHERWISE.
- PROVIDE ACCESS PANELS FOR ALL DUCT SMOKE DETECTORS, JUNCTION BOXES AND OTHER EQUIPMENT REQUIRING ACCESS OR ADJUSTMENT, AND LOCATED IN HARD CEILINGS OR BEHIND WALL PARTITIONS, IN CHASES, ETC.
- UNLESS NOTED OTHERWISE, BRANCH CIRCUIT WIRING SHALL BE SIZED AS FOLLOWS TO COMPENSATE FOR VOLTAGE DROP. ADJUST CONDUIT SIZE AS NECESSARY:
 - 120V, 0-90LF - #12AWG
 - 120V, 91-140LF - #10AWG
 - 120V, 140LF - #8AWG
- FOR LIGHT FIXTURES, WIRING SHALL NOT PASS THROUGH ANY LUMINAIRE INTEGRAL JUNCTION BOX UNLESS LUMINAIRE IS IDENTIFIED FOR THROUGH-WIRING.
- REFRIGERATOR RECEPTACLES SHALL BE MOUNTED AT 42" AFF AND 6" FROM ADJACENT COUNTER.
- MULTIPLE SWITCHES IN THE SAME LOCATION SHALL USE A SINGLE MULTI-GANG DEVICE BOX AND COVERPLATE.
- ANY EXISTING OUTLET COVERPLATES REMAINING AFTER DEMOLITION ARE TO BE REPLACED WITH NEW TO MATCH THE ADJACENT NEW WORK.
- REFER TO ARCHITECTURAL REFLECTED CEILING PLANS FOR EXACT LOCATION OF LIGHTING FIXTURES AND GRID COORDINATION. VERIFY THAT ADEQUATE CLEARANCE FOR INSTALLATION, MAINTENANCE AND HEAT DISSIPATION IS AVAILABLE BEFORE ORDERING LIGHTING FIXTURES.
- VERIFY ALL LOCATIONS, AMPERES AND VOLTAGES OF MECHANICAL EQUIPMENT WITH MECHANICAL CONTRACTOR PRIOR TO ROUGH-IN.
- SEAL ALL CONDUIT PENETRATIONS THROUGH FIRE RATED WALLS AND CEILINGS TO MAINTAIN FIRE INTEGRITY. REFER TO ARCHITECTURAL DRAWINGS FOR FIRE RATED WALLS AND DRYWALL CEILINGS. SEAL ALL PENETRATIONS BY SURFACE MOUNTED AND RECESSED LIGHTING FIXTURES TO MAINTAIN FIRE RATING.
- ALL BRANCH CIRCUITS SHALL BE RUN CONCEALED IN EXISTING AND NEW WALLS. CUT AND PATCH EXISTING WALLS AND SURFACES AS REQUIRED.
- WHERE WALLS ARE INDICATED TO REMAIN BUT ARE TO BE PROVIDED WITH NEW FINISHES, PROVIDE FOR THE REMOVAL AND REINSTALLATION OF ALL EXISTING DEVICES THAT ARE NOTED TO REMAIN.
- GROUNDLED CONDUCTORS SHALL BE PIG-TAILED IN OUTLET BOXES OR MULTI-OUTLET ASSEMBLY FOR RECEPTACLES SO THE REMOVAL OF SUCH DEVICES DOES NOT INTERRUPT CONTINUITY.
- ALL CORE DRILL LOCATIONS THROUGHOUT THE AREA OF WORK TO BE COORDINATED WITH THE TENANT/FURNITURE VENDOR.
- LABEL EACH RECEPTACLE IN LEGIBLE PERMANENT MARKER ON THE BACK OF THE COVERPLATE AS TO WHERE THE RECEPTACLE IS SERVED FROM. IDENTIFY ANY DEDICATED CIRCUITS AS SUCH.
- USE CONDULET SEALING FITTINGS WITH APPROVED SEALING COMPOUND ON ALL CONDUITS PASSING FROM INTERIOR TO EXTERIOR OF BUILDING.
- SUPPORT RECESSED LIGHT FIXTURES FROM BUILDING STRUCTURE.
- FOR INSULATED CEILINGS, PROVIDE NOTICE TO ARCHITECT FOR SUBSTITUTED LIGHT FIXTURES TO BE ISSUED BY ENGINEER PRIOR TO ORDERING ANY FIXTURES.

GENERAL DEMOLITION NOTES

- EXISTING CONDITIONS INDICATED ON THIS DRAWING HAVE BEEN OBTAINED FROM EXISTING DRAWINGS OR GENERAL FIELD OBSERVATIONS AND MAY NOT INDICATE ACTUAL EXISTING CONDITIONS IN DETAIL OR DIMENSION. CONTRACTOR IS RESPONSIBLE FOR DETERMINING THE ACTUAL CONDITIONS AND EFFECT ON HIS WORK. SHOULD CONDITIONS BE DISCOVERED THAT PREVENT EXECUTION OF THE WORK AS INDICATED, IMMEDIATELY NOTIFY THE ARCHITECT IN WRITING FOR DIRECTION BEFORE PROCEEDING WITH THE WORK.
- REMOVE ALL EQUIPMENT INDICATED, INCLUSIVE OF ASSOCIATED CONDUIT, WIRING, BOXES, SUPPORTS, ETC. BACK TO SOURCE OR LAST REMAINING DEVICE ON SAME CIRCUIT, UNLESS NOTED OTHERWISE.
- EXISTING CIRCUITS INTERRUPTED BY DEMOLITION OR RELOCATED WORK, BUT SERVING ITEMS INDICATED TO REMAIN, SHALL BE MADE CONTINUOUS.
- DEMOLITION SHALL INCLUDE REMOVAL OF ELECTRICAL EQUIPMENT AND ASSOCIATED COMPONENTS AND MATERIALS. DO NOT ABANDON IN PLACE ANY ITEMS UNLESS NOTED ON THE DRAWINGS. EQUIPMENT REMOVED SHALL BE OFFERED TO THE OWNER PRIOR TO DISPOSAL AND IF DESIRED, SHALL BE STORED ON SITE WHERE INSTRUCTED. ALL MATERIALS NOT RETAINED BY THE OWNER SHALL BE REMOVED FOR OFF-SITE DISPOSAL.
- THE EXISTING FACILITY SHALL REMAIN IN OPERATION DURING CONSTRUCTION. ALL INTERRUPTIONS TO THE UTILITIES OR SERVICES MUST BE COORDINATED WITH THE OWNER TO MINIMIZE DISRUPTIONS. PROVIDE NOTICE TO THE OWNER 15 DAYS IN ADVANCE OF PLANNED OUTAGES.
- WHENEVER THE BUILDING IS OCCUPIED DURING THE WORK, EXISTING FIRE ALARM AND LIFE SAFETY SYSTEMS SHALL BE KEPT IN OPERATION.
- NOTIFY OWNER OF ANY DAMAGED OR NON-WORKING ITEMS PRIOR TO REMOVAL. ANY EQUIPMENT DAMAGED DURING REMOVAL AND/OR RELOCATION SHALL BE REPLACED AT THE CONTRACTORS EXPENSE WITH EQUIPMENT EQUAL TO EXISTING.
- WHERE SITE DEMOLITION WORK REQUIRES REMOVAL OF LIGHT POLES, PAD MOUNTED EQUIPMENT, ETC, REMOVE ASSOCIATED POLE BASES, CONCRETE PADS, ETC. DOWN TO 36" BELOW FINAL GRADE.
- ANY OPENINGS LEFT IN CEILINGS/WALLS/FLOORS SHALL BE PATCHED AND FINISHED TO MATCH EXISTING ADJACENT SURFACES. WHERE THE DEVICES ARE REMOVED FROM CEILING TILES, PROVIDE REPLACEMENT TILES TO MATCH EXISTING.
- DISCONNECT AND REMOVE ALL ASSOCIATED ELECTRICAL CONNECTIONS FOR EXISTING HVAC AND PLUMBING EQUIPMENT BEING REMOVED, INCLUDING: CONDUIT, WIRING, OUTLETS, DISCONNECTING MEANS, STARTERS, SWITCHES, ETC. REFER TO MECHANICAL DRAWINGS FOR ADDITIONAL INFORMATION.
- "REL" ADJACENT TO EQUIPMENT INDICATES EQUIPMENT IS TO BE RELOCATED.
- EQUIPMENT SHOWN THIN/SOLID IS EXISTING TO REMAIN. EQUIPMENT SHOWN HEAVY/DASHED IS EXISTING TO BE REMOVED OR RELOCATED AS INDICATED.

NOTICE TO CONTRACTORS

PRIOR TO BID SUBMISSION PROCESS, ALL CONTRACTORS SHALL VISIT PROPOSED WORK SITE AND FIELD VERIFY ALL EXISTING CONDITIONS. ANY CONDITIONS THAT DIFFER FROM THAT SHOWN ON THESE PLANS SHALL BE REPORTED TO ARCHITECT/ENGINEER SO THAT NEW AND REVISED BID DRAWINGS OR INFORMATION MAY BE ISSUED. MODIFICATIONS TO SCOPE OF WORK WHICH RESULT FROM CONTRACTORS NEGLECT TO VISIT THE SITE PRIOR TO SUBMITTING BID, SHALL BE THE CONTRACTORS SOLE RESPONSIBILITY.

ELECTRICAL SYMBOLS

NOTE: ALL MOUNTING HEIGHTS ARE TO CENTER LINE OF THE OUTLET BOX UNLESS OTHERWISE INDICATED.

SYMBOL	DESCRIPTION
	2X4, 2X2, 1X4 LIGHTING FIXTURE. LETTER ADJACENT TO FIXTURE INDICATES FIXTURE TYPE. REFER TO LIGHTING SCHEDULE
	INDICATES FIXTURE ON EMERGENCY OR NIGHT LIGHT CIRCUIT
	LIGHTING FIXTURE - DOWNLIGHT, WALL BRACKET, WALLWASHER. LETTER ADJACENT TO FIXTURE INDICATES FIXTURE TYPE. REFER TO LIGHTING SCHEDULE
	EXIT LIGHT - CEILING, WALL, WITH DIRECTIONAL ARROWS
	COMBINATION EXIT LIGHT/BATTERY UNIT - WALL MOUNTED
	EMERGENCY BATTERY UNIT, REMOTE HEAD
	SWITCH - LOW VOLTAGE MOMENTARY CONTACT TYPE
	SWITCH - LINE VOLTAGE WALL VACANCY SENSOR TYPE
	SWITCH - LINE VOLTAGE WALL VACANCY SENSOR TYPE WITH DIMMER
	SWITCH - DIMMER WITH SINGLE MOMENTARY CONTACT SWITCH
	SWITCH - SINGLE POLE, THREE WAY, FOUR WAY
	SWITCH - DIMMER, OCCUPANCY SENSOR
	SWITCH - MOTOR RATED WITH THERMAL ELEMENT
	CEILING VACANCY LIGHTING CONTROL SENSOR
	PHOTOCELL, TIMECLOCK
	RECEPTACLE - 20A, 125 VOLTS - DUPLEX, DOUBLE DUPLEX
	RECEPTACLE - 20A, 125 VOLTS - DUPLEX - COUNTER HEIGHT AT 44" AFF
	SPECIAL RECEPTACLE AS NOTED
	FLUSH FLOOR BOX - COMBINATION POWER AND TELEPHONE/DATA, POWER ONLY
	COMMUNICATION OUTLET - TELEPHONE/DATA - 11H, 1'-8"
	COMMUNICATION OUTLET - TELEPHONE/DATA - COUNTER HEIGHT AT 44"
	TELEPHONE TERMINAL BACKBOARD
	PANELBOARD - 11H, 6'-6" TO TOP - SURFACE MOUNT, FLUSH MOUNT
	METER
	JUNCTION BOX
	DISCONNECT SWITCH - UNFUSED, FUSED - 11H, 5'-6" TO TOP
	MOTOR - HORSEPOWER AS NOTED
	HEATING ELEMENT - CAPACITY AS NOTED
	GROUND CONNECTION
	BRANCH CIRCUIT - IN CEILING OR WALLS. 2 #12 # 1 #12 GROUND IN 1/2" CONDUIT UNLESS NOTED OTHERWISE
	BRANCH CIRCUIT - BELOW GRADE/SUBSLAB. 2 #12 # 1 #12 GROUND IN 1/2" CONDUIT UNLESS NOTED OTHERWISE
	HOMERUN TO PANEL - LETTER INDICATES PANEL AND NUMBER INDICATES CIRCUIT NUMBER. NUMBER OF CROSSLINES INDICATES NUMBER OF CONDUCTORS WHEN MORE THAN 2. WITHOUT CROSSLINES - 2 #12 + #12 GROUND IN 1/2" CONDUIT
	FIRE ALARM - PULL STATION 11H, 3'-10"
	FIRE ALARM - AUDIBLE SIGNAL AND VISUAL FLASHER ON WALL WITH MINIMUM 1 CANELADAS NOTED
	FIRE ALARM - VISUAL FLASHER ON WALL WITH MINIMUM 1 CANELADAS NOTED
	DRAWING NOTE, SPECIAL EQUIPMENT NUMBER
	POWER POLE

ABBREVIATIONS


A	- AMPS, AMPERE	MLO	- MAIN LUGS ONLY
AFF	- ABOVE FINISHED FLOOR	MCB	- MAIN CIRCUIT BREAKER
AFG	- ABOVE FINISHED GRADE	MH	- MOUNTING HEIGHT
cd	- CANDELA	MTD	- MOUNTED
CDT	- CONDUIT	NEC	- NATIONAL ELECTRIC CODE
CH	- COUNTER HEIGHT	NFSS	- NON FUSED SAFETY SWITCH
DC	- DIRECT CURRENT	NIC	- NOT IN CONTRACT
DN	- DOWN	NL	- NIGHT LIGHT
DWG	- DRAWING	PC	- PHOTOCELL
EF	- EXHAUST FAN	REL	- RELOCATE/RELOCATED
EX	- EXISTING	SE	- SERVICE ENTRANCE
FLA	- FULL LOAD AMPS	TC	- TIME CLOCK
FSS	- FUSED SAFETY SWITCH	U.O.N.	- UNLESS OTHERWISE NOTED
GND	- GROUND	V	- VOLTS
GFI	- GROUND FAULT INTERRUPTER	WP	- WEATHERPROOF
HP	- HORSEPOWER		

FARMERS & MERCHANTS

BANK

25 WESTMINSTER PIKE
REISTERTOWN, MARYLAND, 21136

INTERIOR ALTERATION

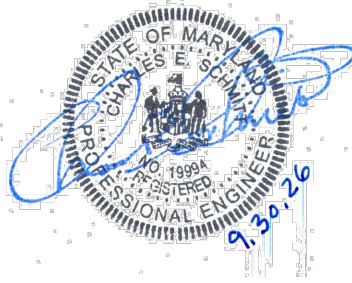

I CERTIFY THAT THESE DOCUMENTS WERE PREPARED OR APPROVED BY ME AND THAT I AM A DULY LICENSED PROFESSIONAL ENGINEER UNDER THE LAWS OF THE STATE OF MARYLAND.

LICENSE NO.: 19994

EXP. DATE: 3/31/2027

THESE DRAWINGS ARE NOT PERMITTED TO BE COPIED OR REPRODUCED, EITHER WHOLLY OR PARTIALLY, UNLESS WRITTEN PERMISSION IS FIRST OBTAINED FROM SANDERS DESIGNS, P.A.

MECHANICAL & ELECTRICAL
DESIGN CONSULTANTS, INC.

1907 N. Fountain Green Road
Bel Air, Maryland 21015-1411
410-869-2828 • Fax 410-869-0442
Web Site: www.jrsdesign.net



SANDERS | DESIGNS
ARCHITECTS PLANNERS

WWW.SANDERSDESIGNS.COM
MAILBOX@SANDERSDESIGNS.COM
9727 GREENSIDE DRIVE, SUITE 202, COCKEYSVILLE, MARYLAND 21030
T: (410) 660 2624

No.	Date	Revision

Project No.:

Date:

Scale:

Edition:


PERMIT

SET


Drawing Name:
NOTES &
SYMBOLS

Drawing Number:


E-1

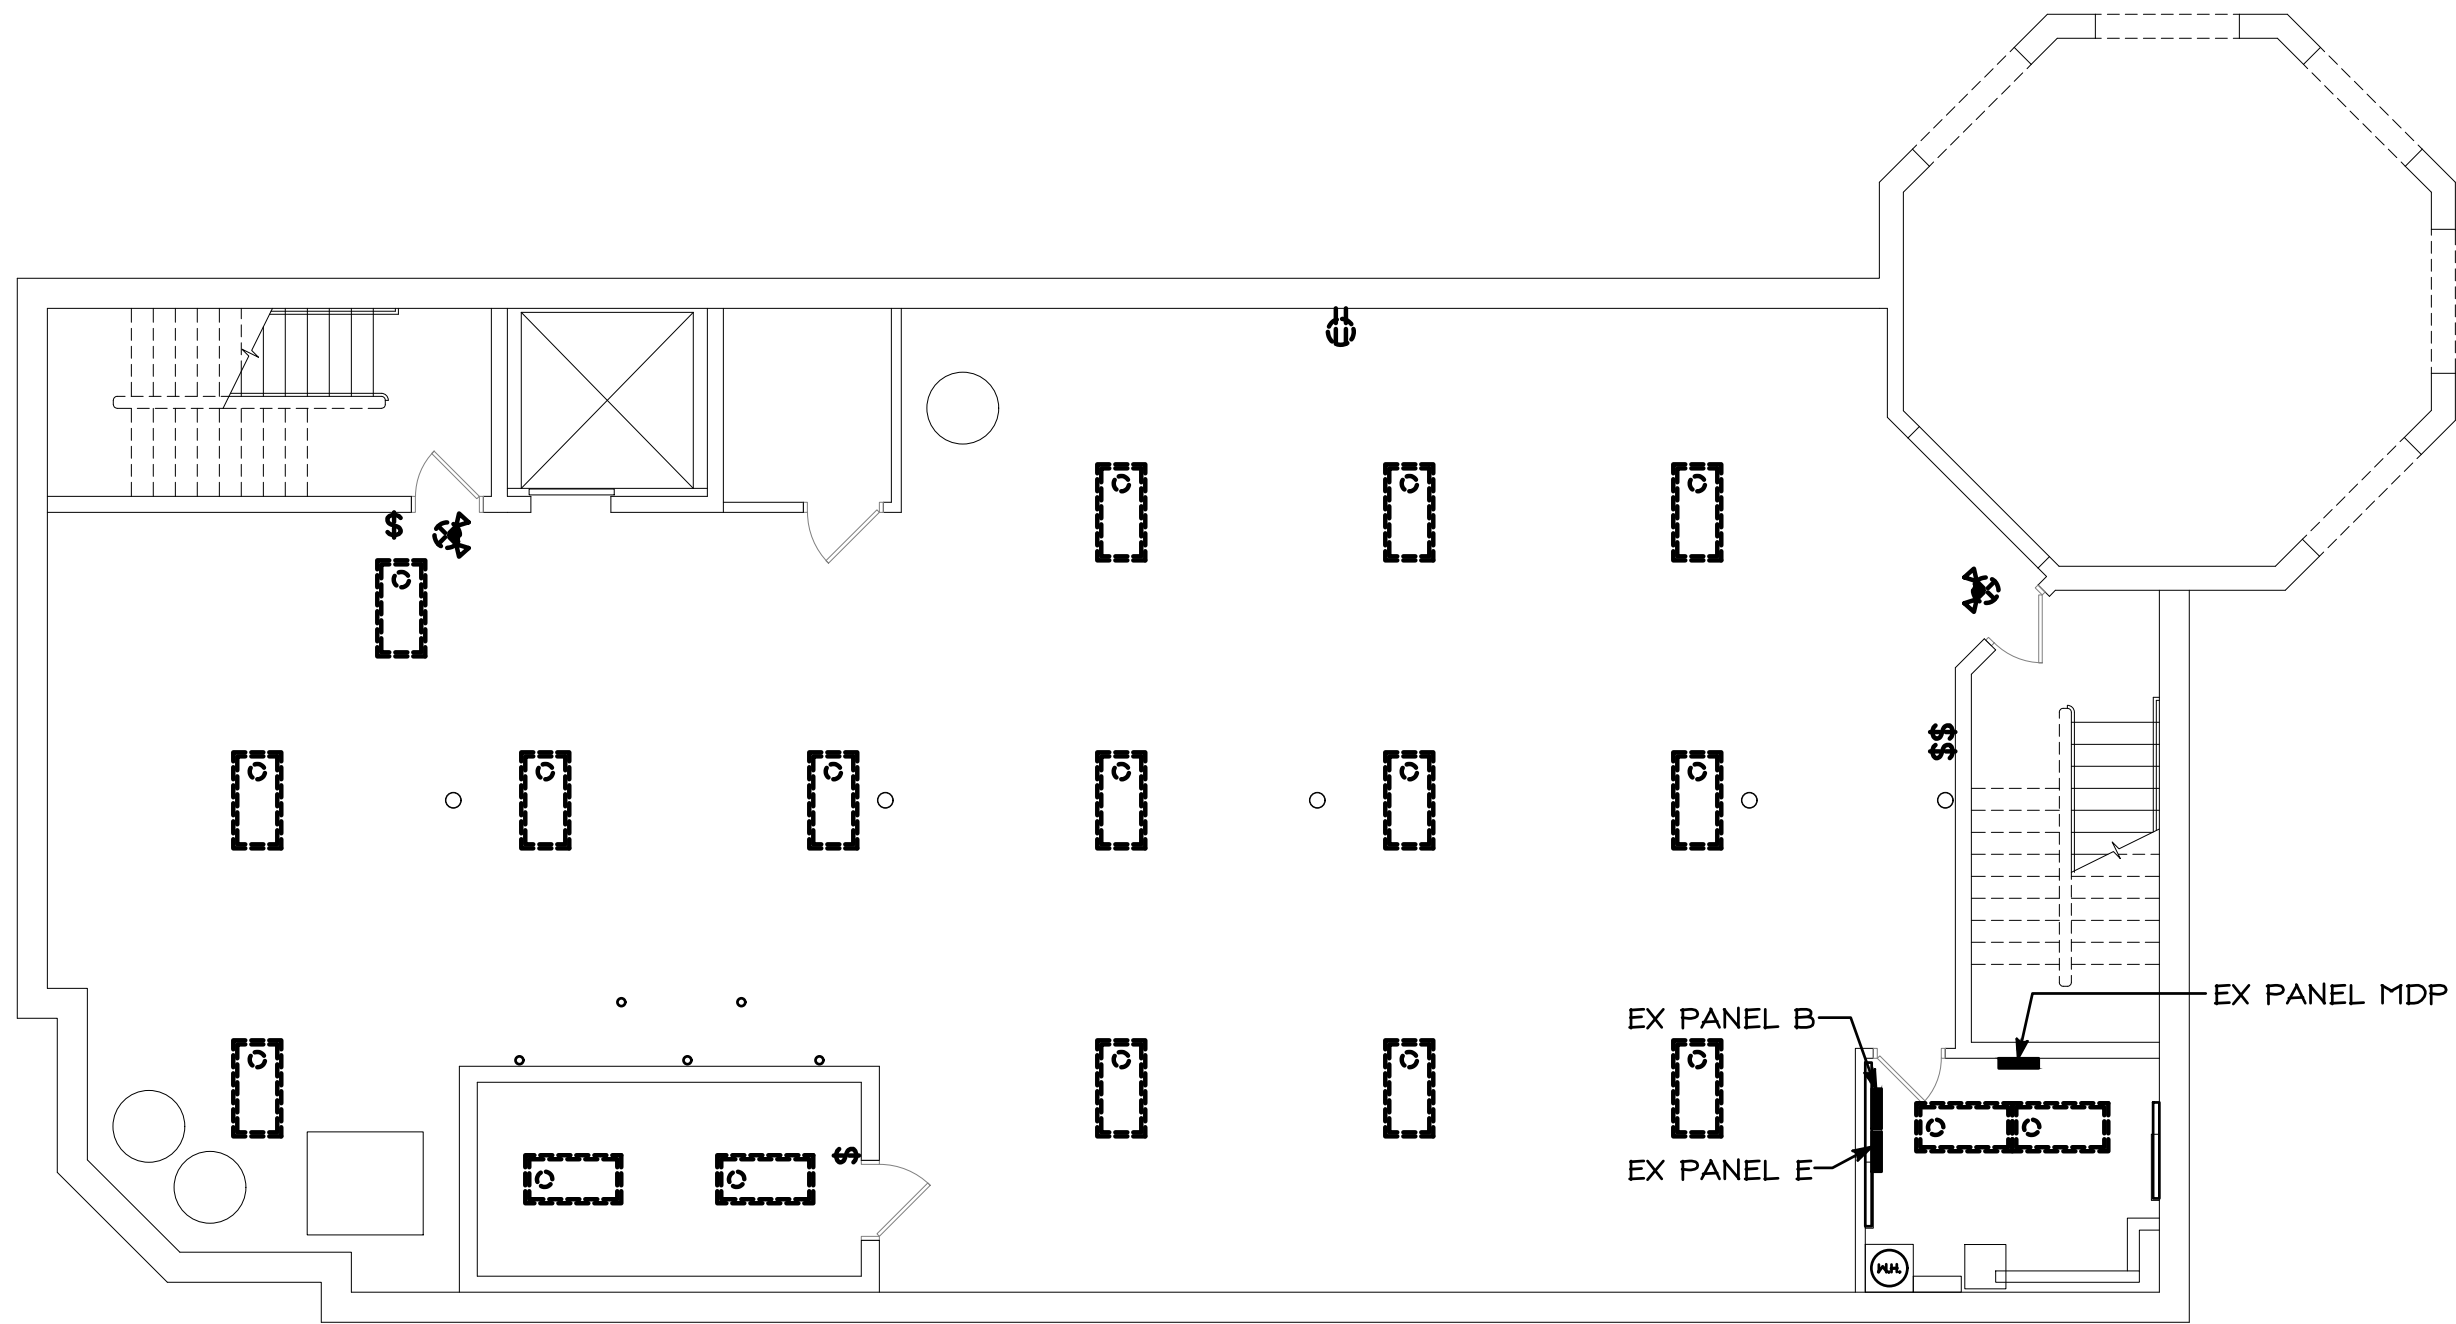

DEMO - BASEMENT - LIGHTING
SCALE: 1/8"=1'-0"

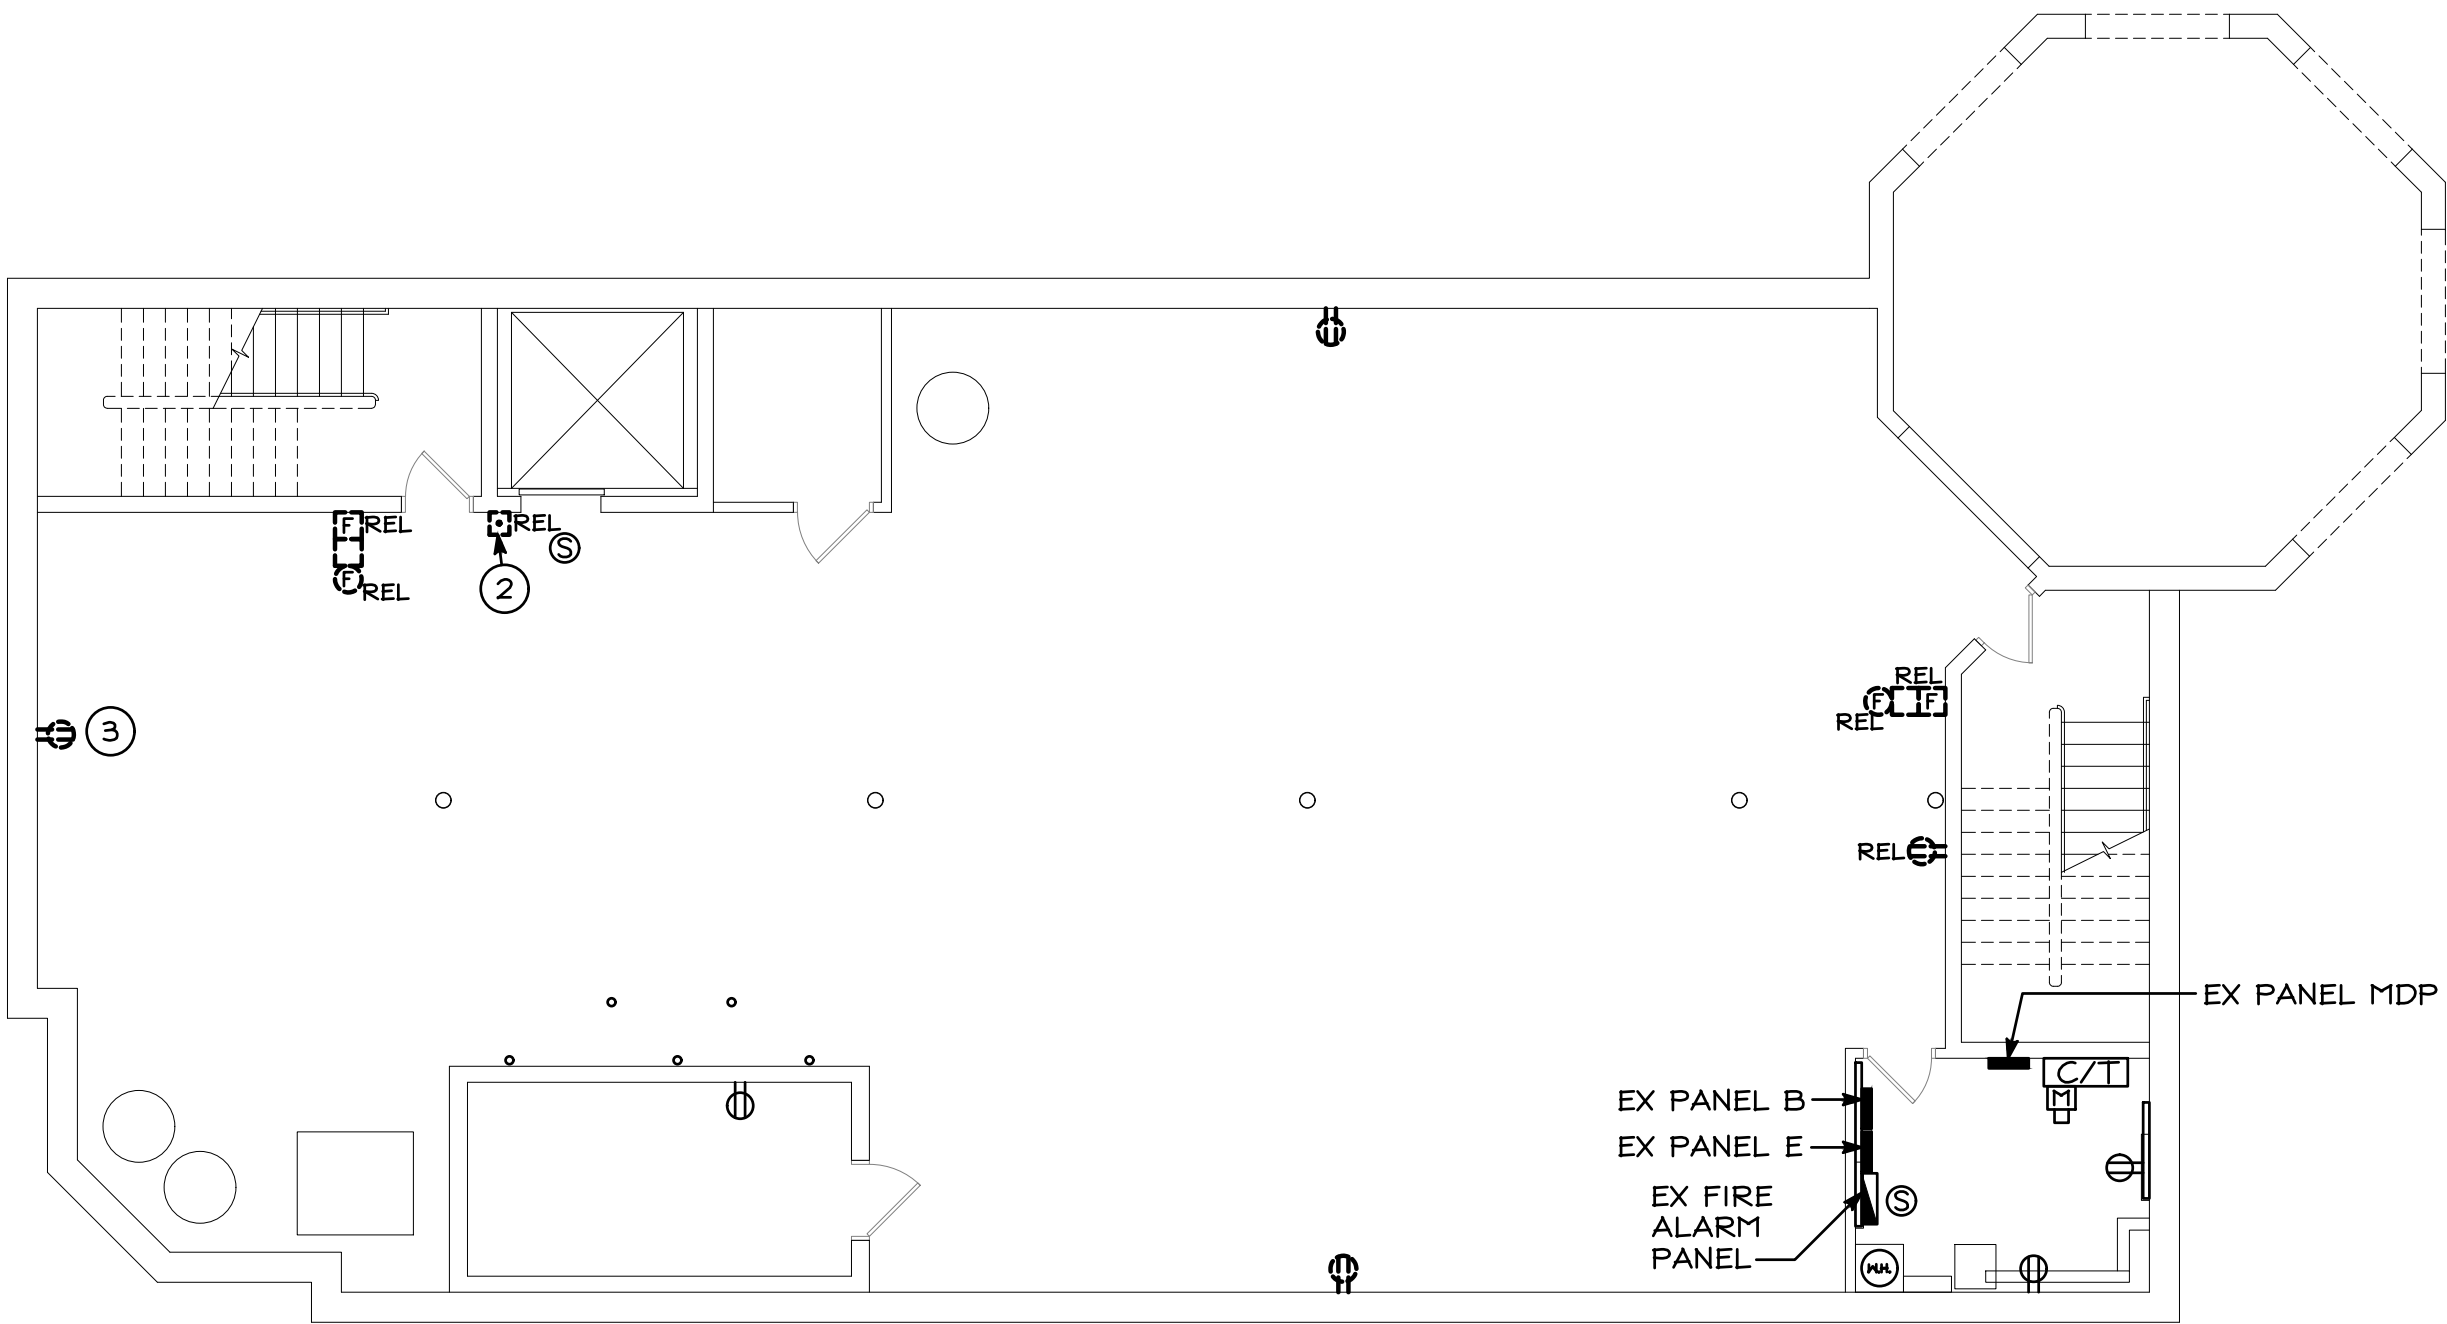

DEMO - BASEMENT - POWER
SCALE: 1/8"=1'-0"

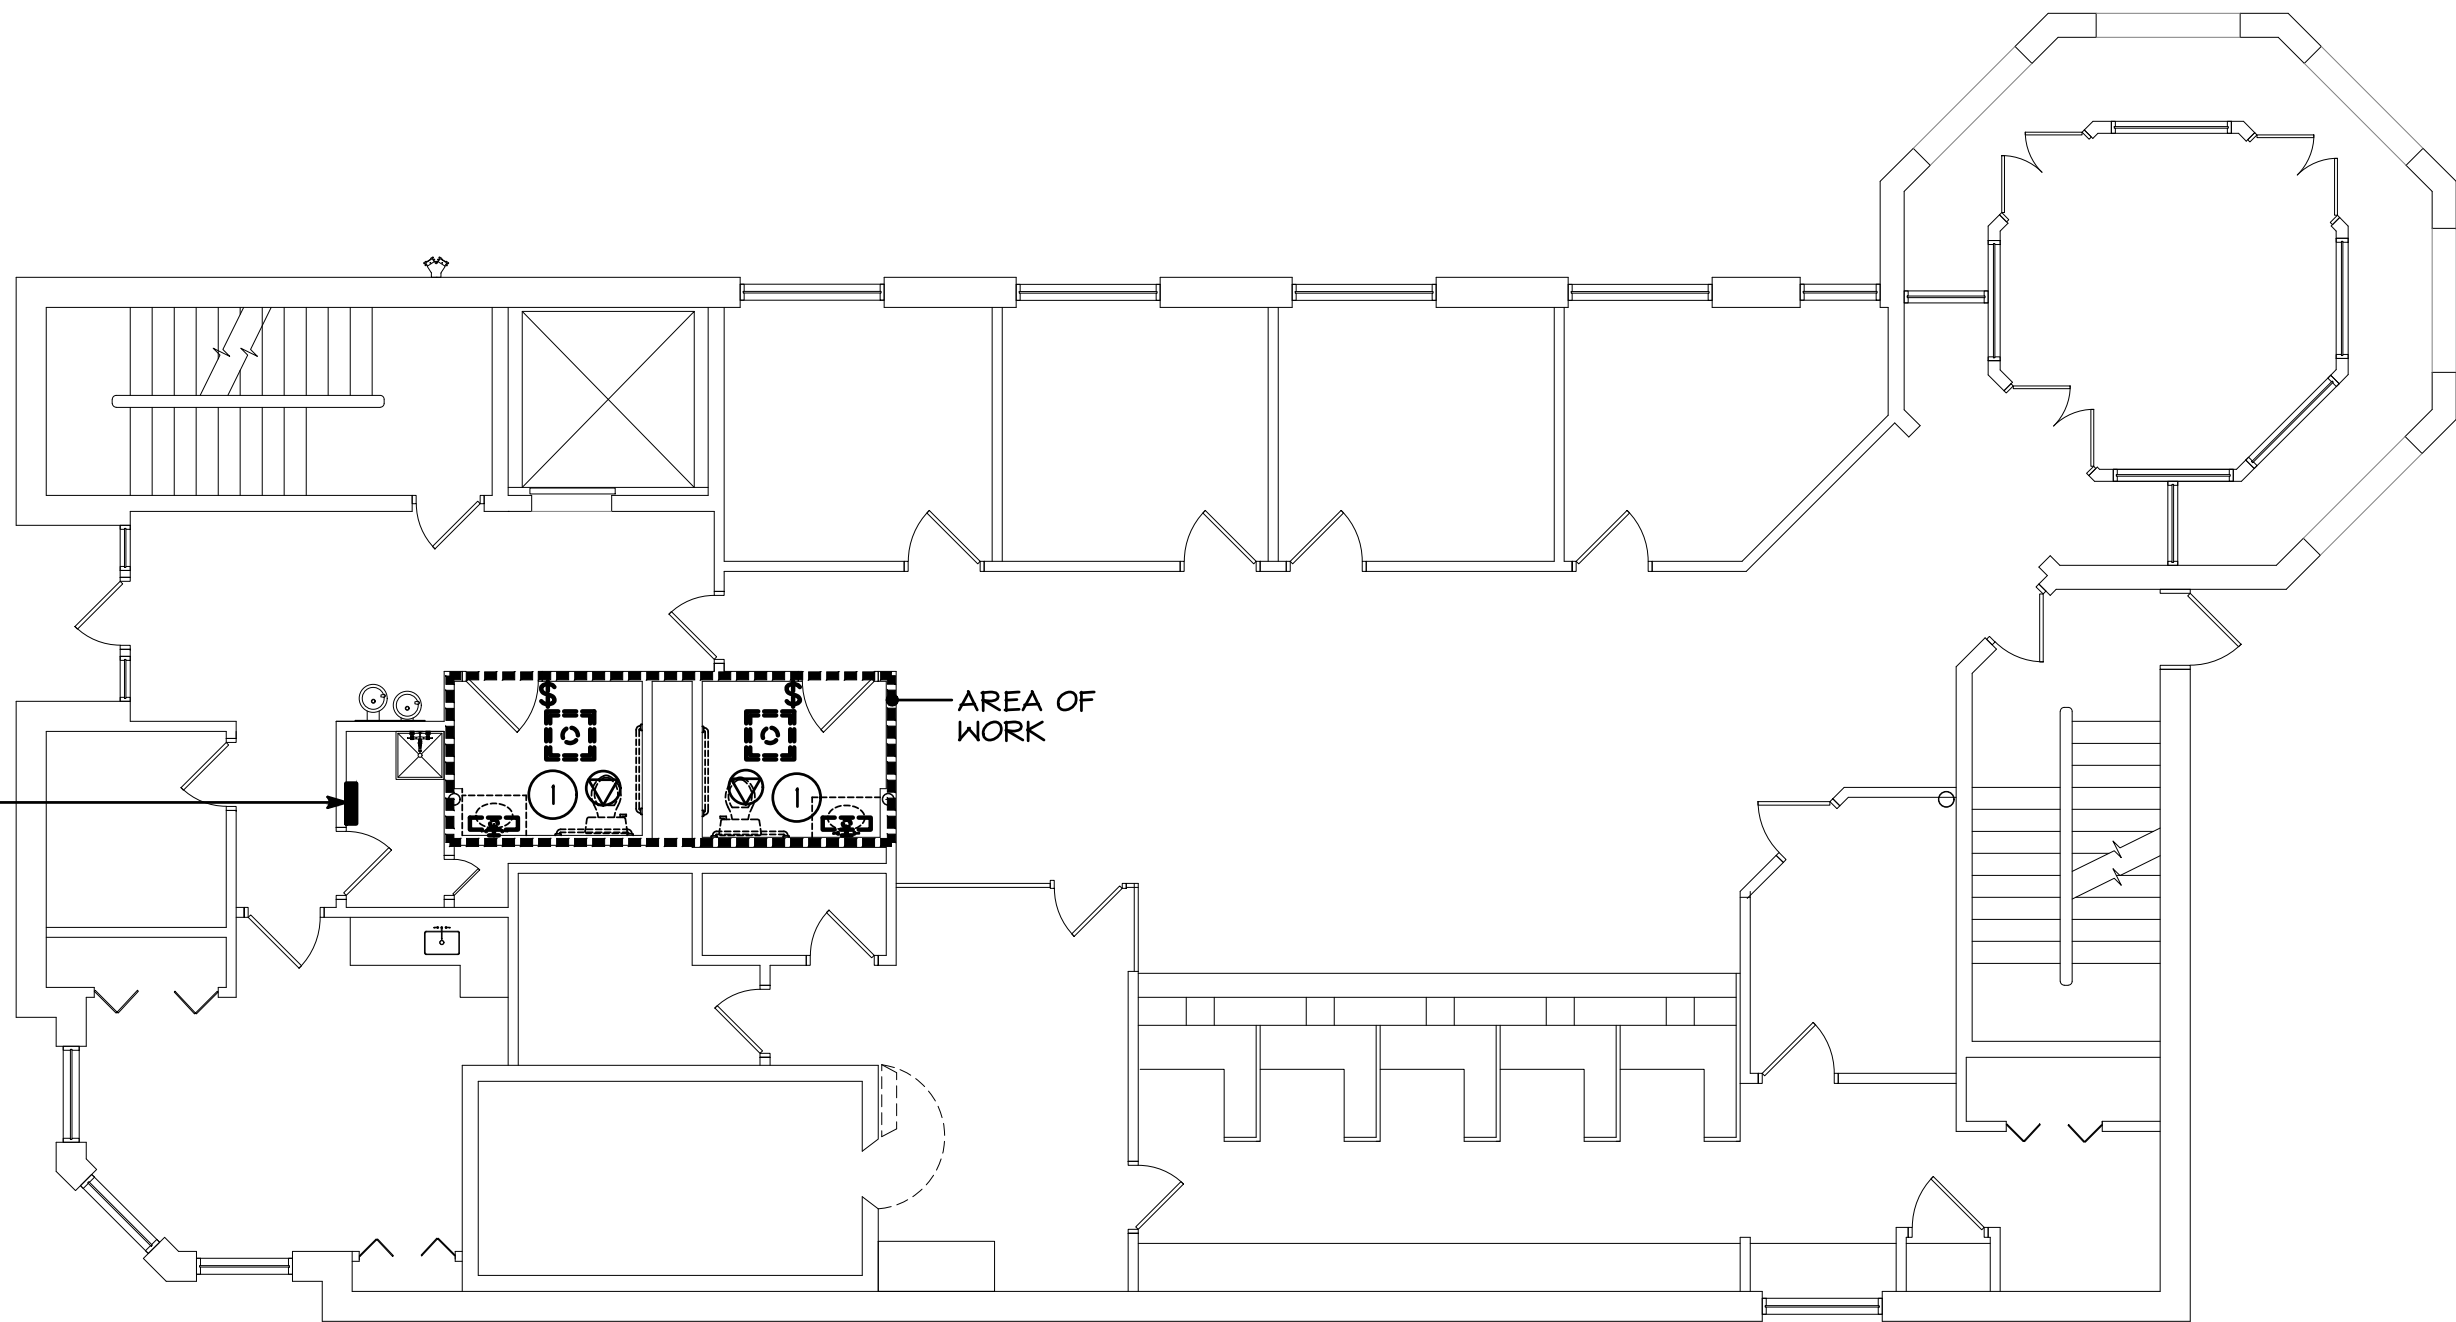


DEMO - FIRST FLOOR - LIGHTING
SCALE: 1/8"=1'-0"

GENERAL NOTES


- WHERE LIGHTING FIXTURES ARE SHOWN TO BE REMOVED, EXISTING CIRCUITING IS TO REMAIN. REFER TO NEW WORK PLAN, E-4.
- EQUIPMENT SHOWN THIN/SOLID IS EXISTING. EQUIPMENT SHOWN HEAVY/DASHED IS DEMO.

DRAWING NOTES

- DISCONNECT EXISTING EXHAUST FAN TO REMAIN FROM LIGHTING CIRCUIT.
- EXISTING ELEVATOR CONTROLS TO BE DISCONNECTED AND RELOCATED PER FURRING OUT OF WALL.
- REMOVE EXISTING RECEPTACLE. RETAIN CIRCUIT FOR NEW QUAD RECEPTACLE.

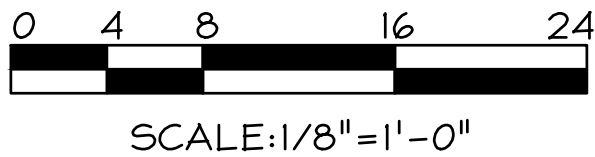

**FARMERS & MERCHANTS
BANK**
25 WESTMINSTER PIKE
REISTERTOWN, MARYLAND, 21136
INTERIOR ALTERATION

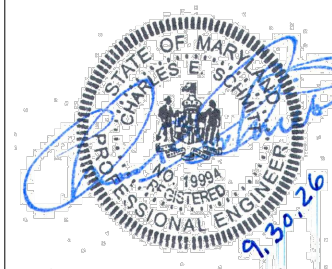

I CERTIFY THAT THESE DOCUMENTS WERE PREPARED OR APPROVED BY ME AND THAT I AM A DULY LICENSED PROFESSIONAL ENGINEER UNDER THE LAWS OF THE STATE OF MARYLAND.

LICENSE NO.: 19994
EXP. DATE: 3/31/2027

THESE DRAWINGS ARE NOT PERMITTED TO BE COPIED OR REPRODUCED, EITHER WHOLLY OR PARTIALLY, UNLESS WRITTEN PERMISSION IS FIRST OBTAINED FROM SANDERS DESIGNS, P.A.

**MECHANICAL & ELECTRICAL
DESIGN CONSULTANTS, INC.**
1907 N. Fountain Green Road
Bel Air, Maryland 21015-1411
410-869-2822 • Fax 410-869-0442
Web Site: www.jrdesign.net


**SANDERS | DESIGNS
ARCHITECTS PLANNERS**
WWW.SANDERDESIGNS.COM
9727 GREENSIDE DRIVE, SUITE 202, COCKEYSVILLE, MARYLAND 21030
MAILBOX@SANDERDESIGNS.COM
T: (410) 660 2624

No.	Date	Revision


Project No.:
Date:
Scale:
Edition:
PERMIT
SET

Drawing Name:
**DEMO BASEMENT & FIRST
FLOOR - LIGHTING &
POWER PLANS**
Drawing Number:

E-2

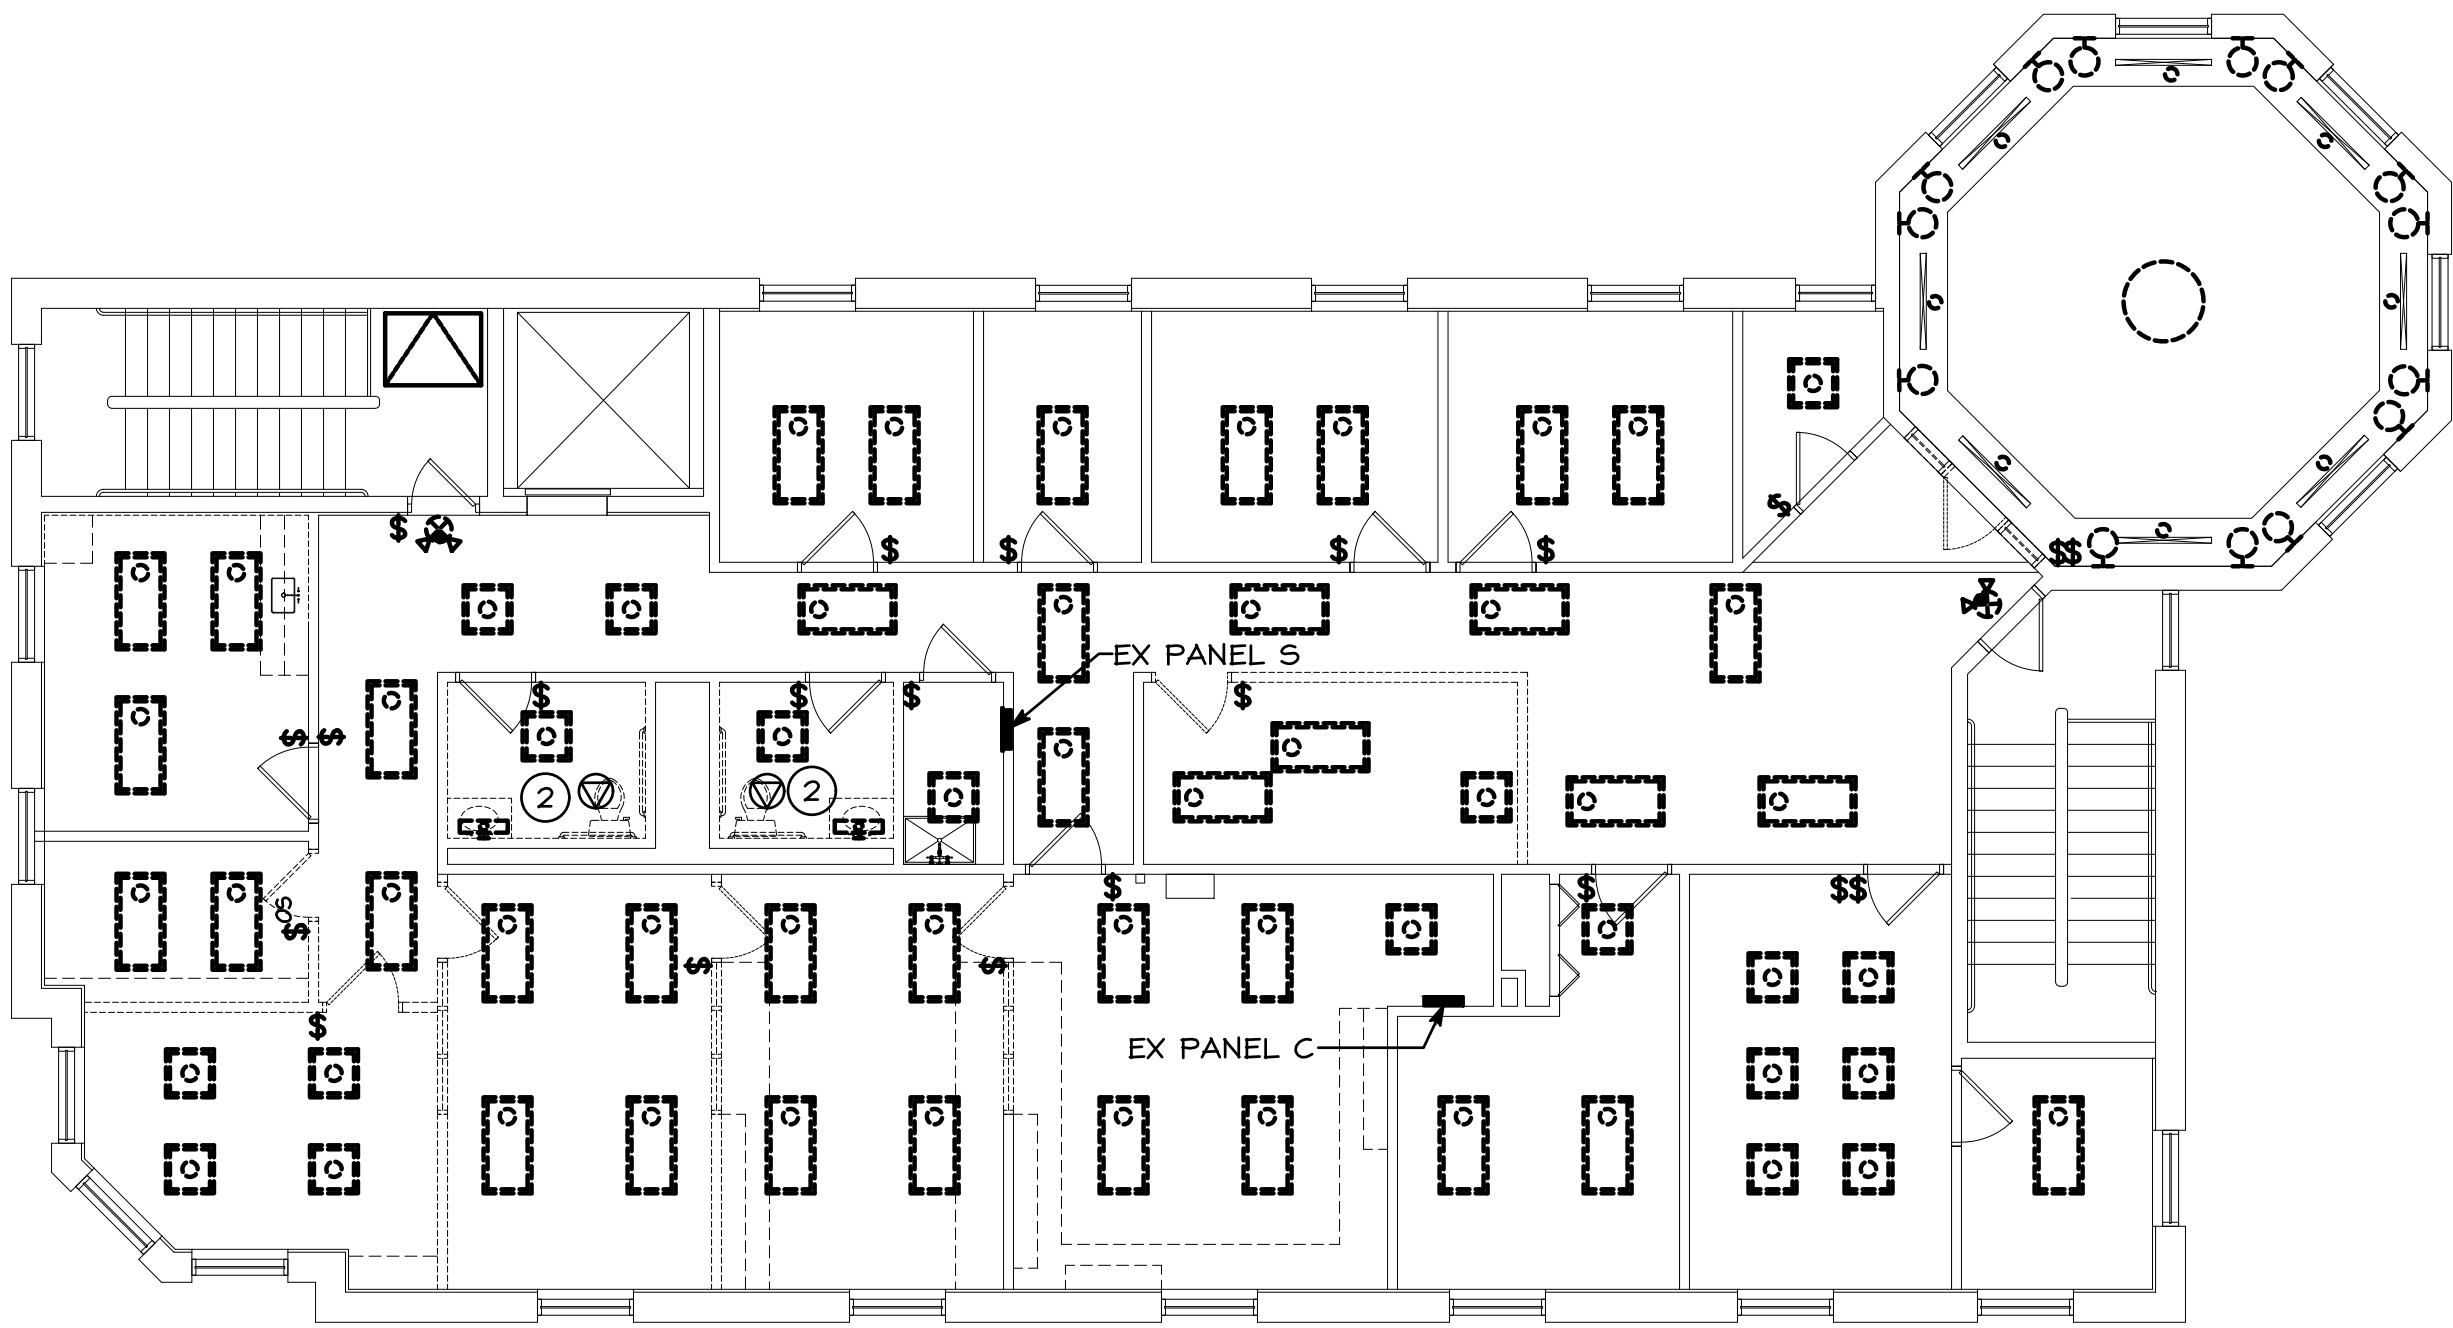

DEMO - SECOND FLOOR - LIGHTING
SCALE: 1/8"=1'-0"

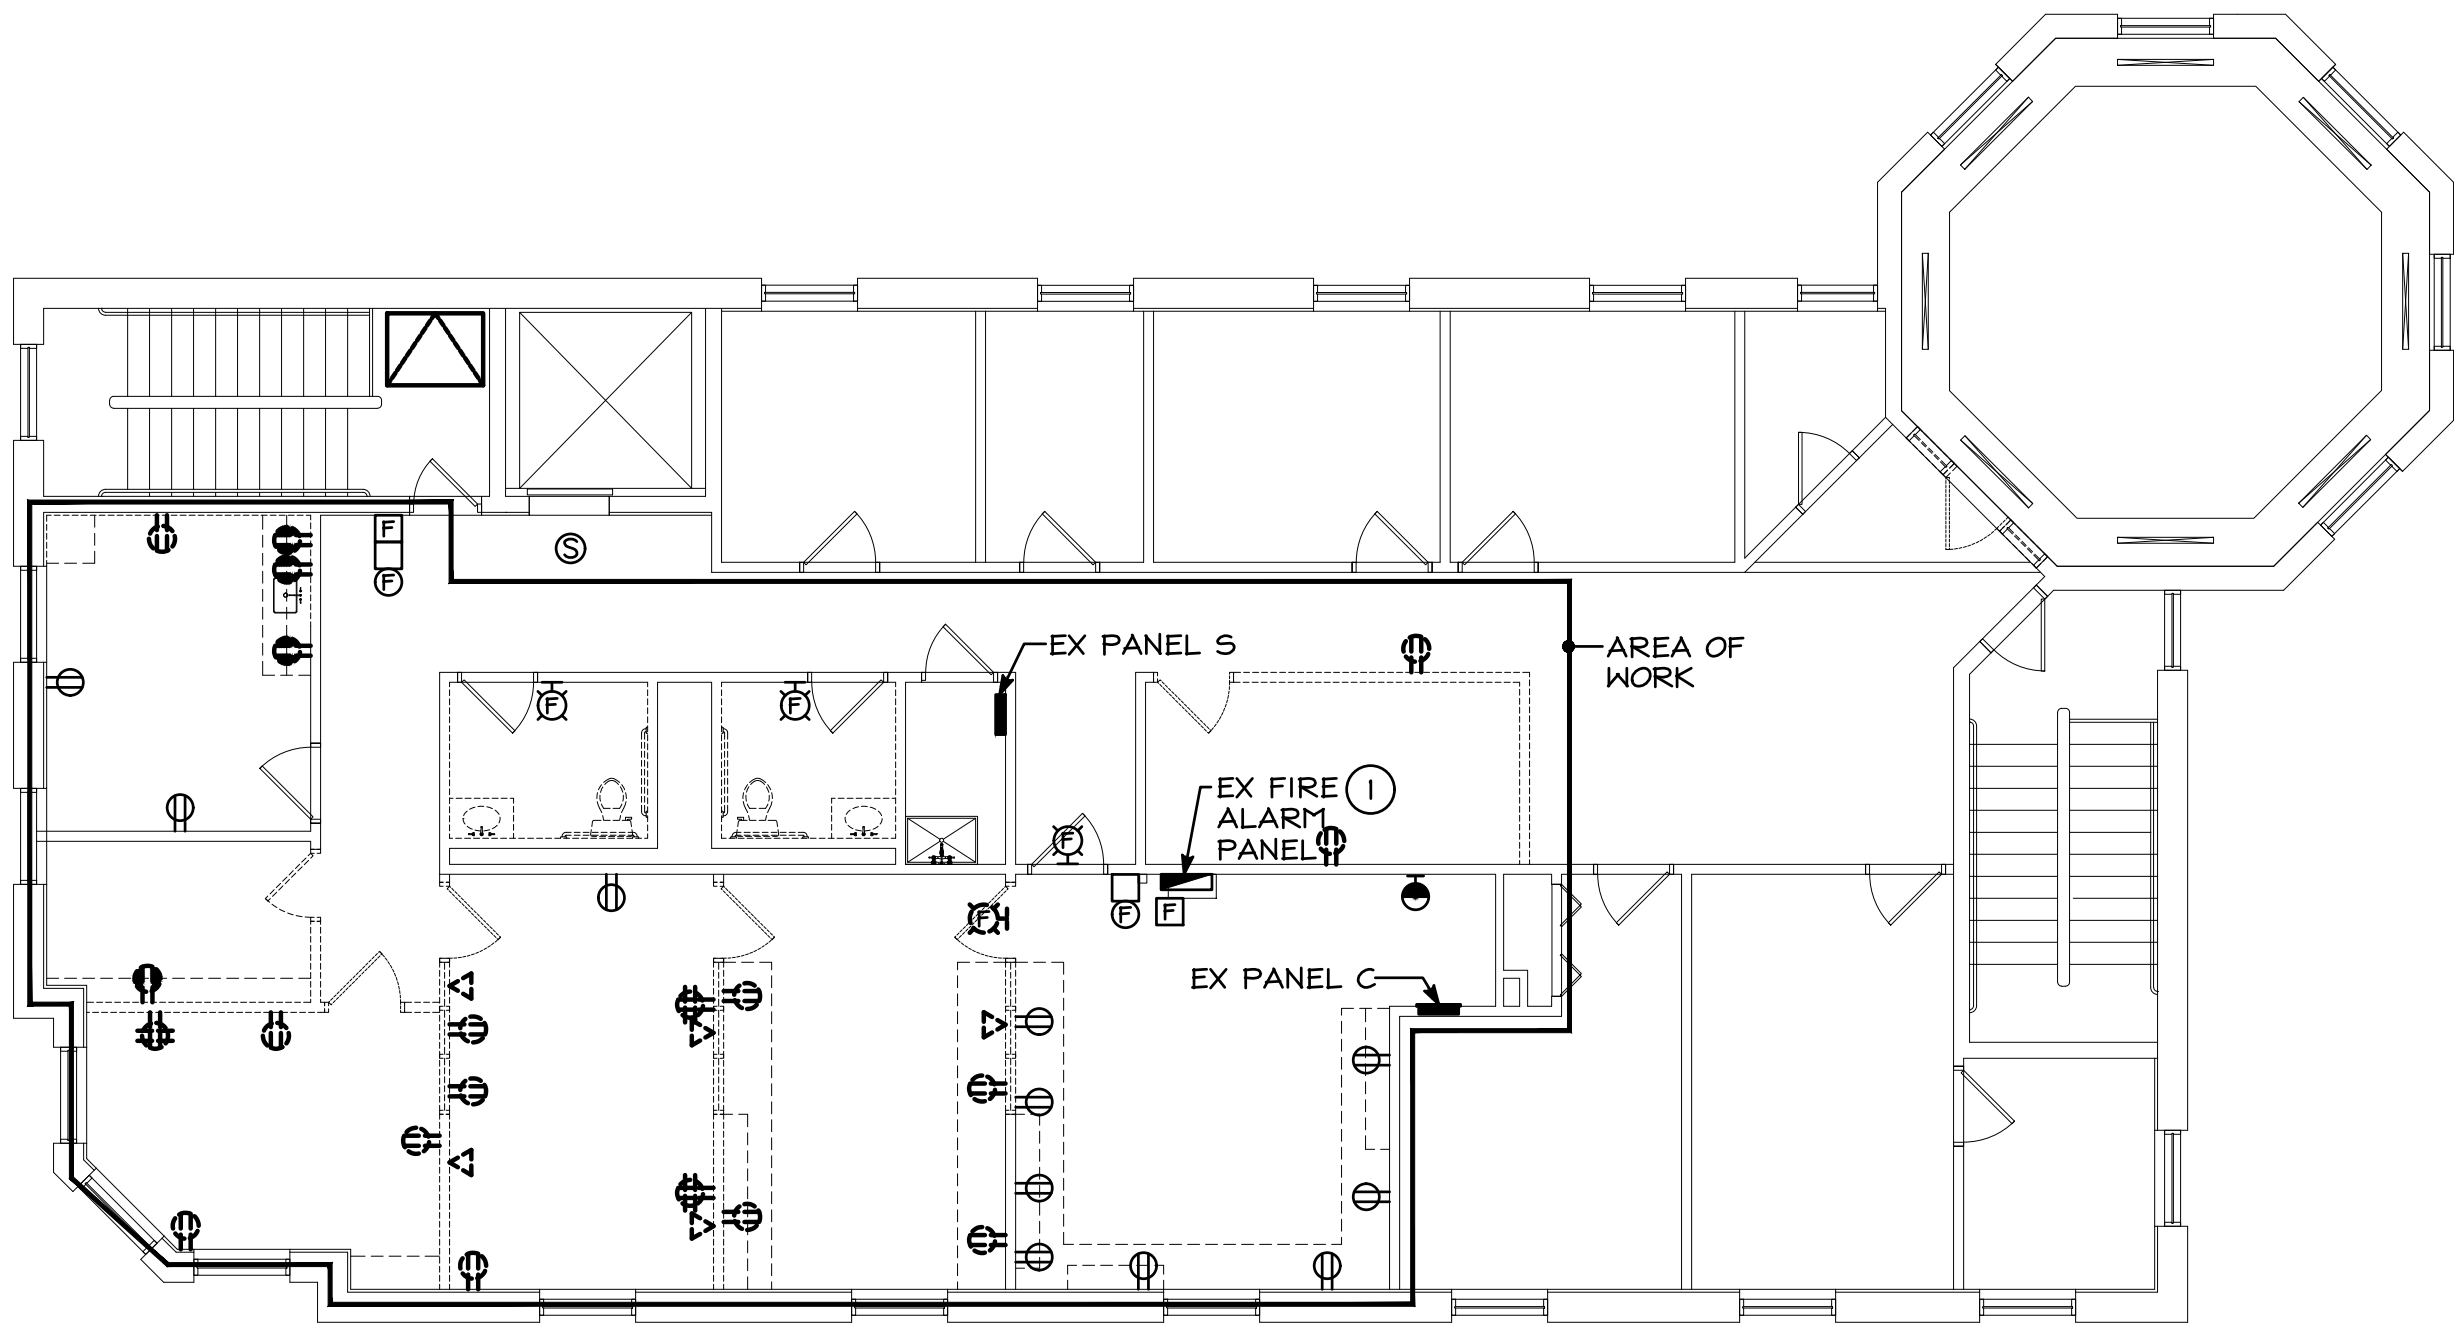



DEMO - SECOND FLOOR - POWER
SCALE: 1/8"=1'-0"

GENERAL NOTES

- WHERE LIGHTING FIXTURES ARE SHOWN TO BE REMOVED, EXISTING CIRCUITING IS TO REMAIN. REFER TO NEW WORK PLAN, E-4.
- EQUIPMENT SHOWN THIN/SOLID IS EXISTING. EQUIPMENT SHOWN HEAVY/DASHED IS DEMO.

DRAWING NOTES

- EXISTING FIRE SUPPRESSION SYSTEM AND ALL ASSOCIATED DEVICES (UNLESS NOTED OTHERWISE) TO REMAIN.
- DISCONNECT EXISTING EXHAUST FAN TO REMAIN FROM LIGHTING CIRCUIT.

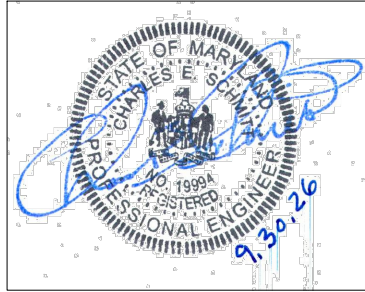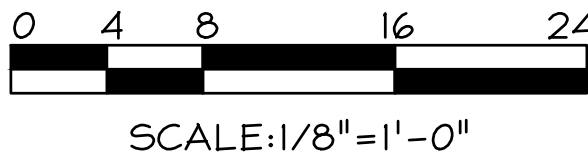

I CERTIFY THAT THESE DOCUMENTS WERE PREPARED OR APPROVED BY ME AND THAT I AM A DULY LICENSED PROFESSIONAL ENGINEER UNDER THE LAWS OF THE STATE OF MARYLAND.

LICENSE NO.: 19994
EXP. DATE: 3/31/2027

THESE DRAWINGS ARE NOT PERMITTED TO BE COPIED OR REPRODUCED, EITHER WHOLLY OR PARTIALLY, UNLESS WRITTEN PERMISSION IS FIRST OBTAINED FROM SANDERS DESIGNS, P.A.

MECHANICAL & ELECTRICAL DESIGN CONSULTANTS, INC.
1907 N. Fountain Green Road
Bel Air, Maryland 21015-1411
410-869-2822 • Fax 410-869-0442
web site: www.jrdesign.net

SANDERS | DESIGNS
ARCHITECTS PLANNERS
WWW.SANDERSDESIGNS.COM
9727 GREENSIDE DRIVE, SUITE 202, COCKEYSVILLE, MARYLAND 21030 T: (410) 660 2624

No.	Date	Revision


Project No.:
Date:
Scale:
Edition:
PERMIT SET

Drawing Name:
DEMO SECOND FLOOR - LIGHTING & POWER PLANS


Drawing Number:

E-3


FARMERS & MERCHANTS BANK
25 WESTMINSTER PIKE
REISTERTOWN, MARYLAND, 21136
INTERIOR ALTERATION

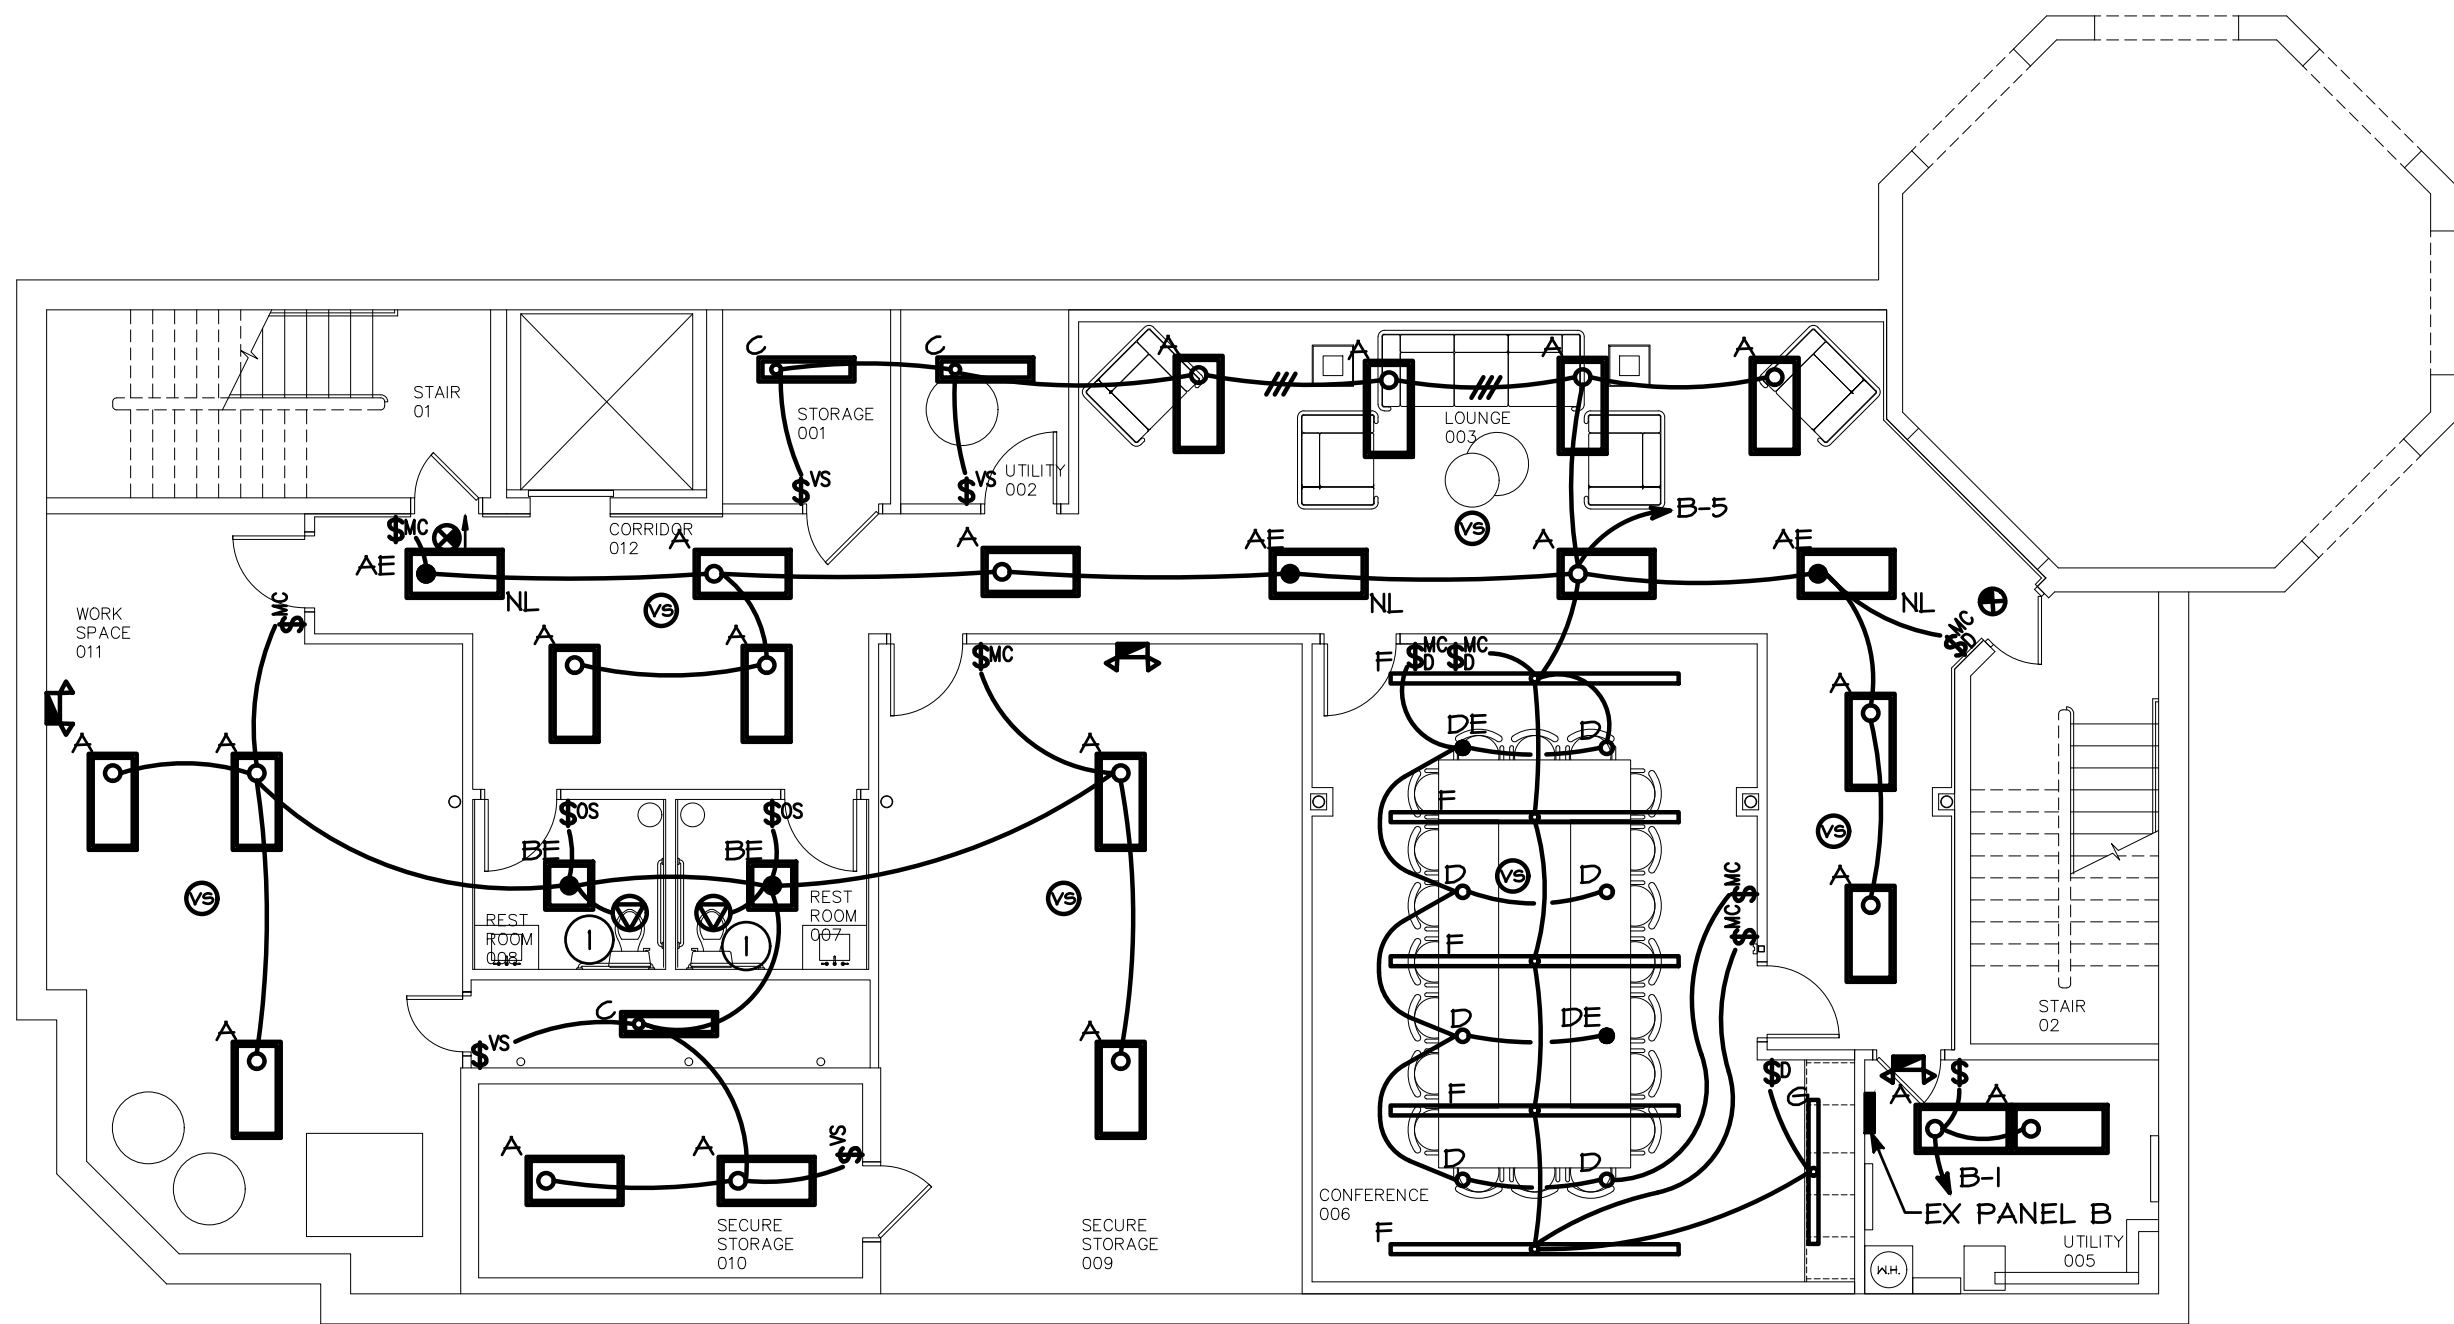

NEW WORK - BASEMENT FLOOR - LIGHTING
SCALE: 1/8"=1'-0"

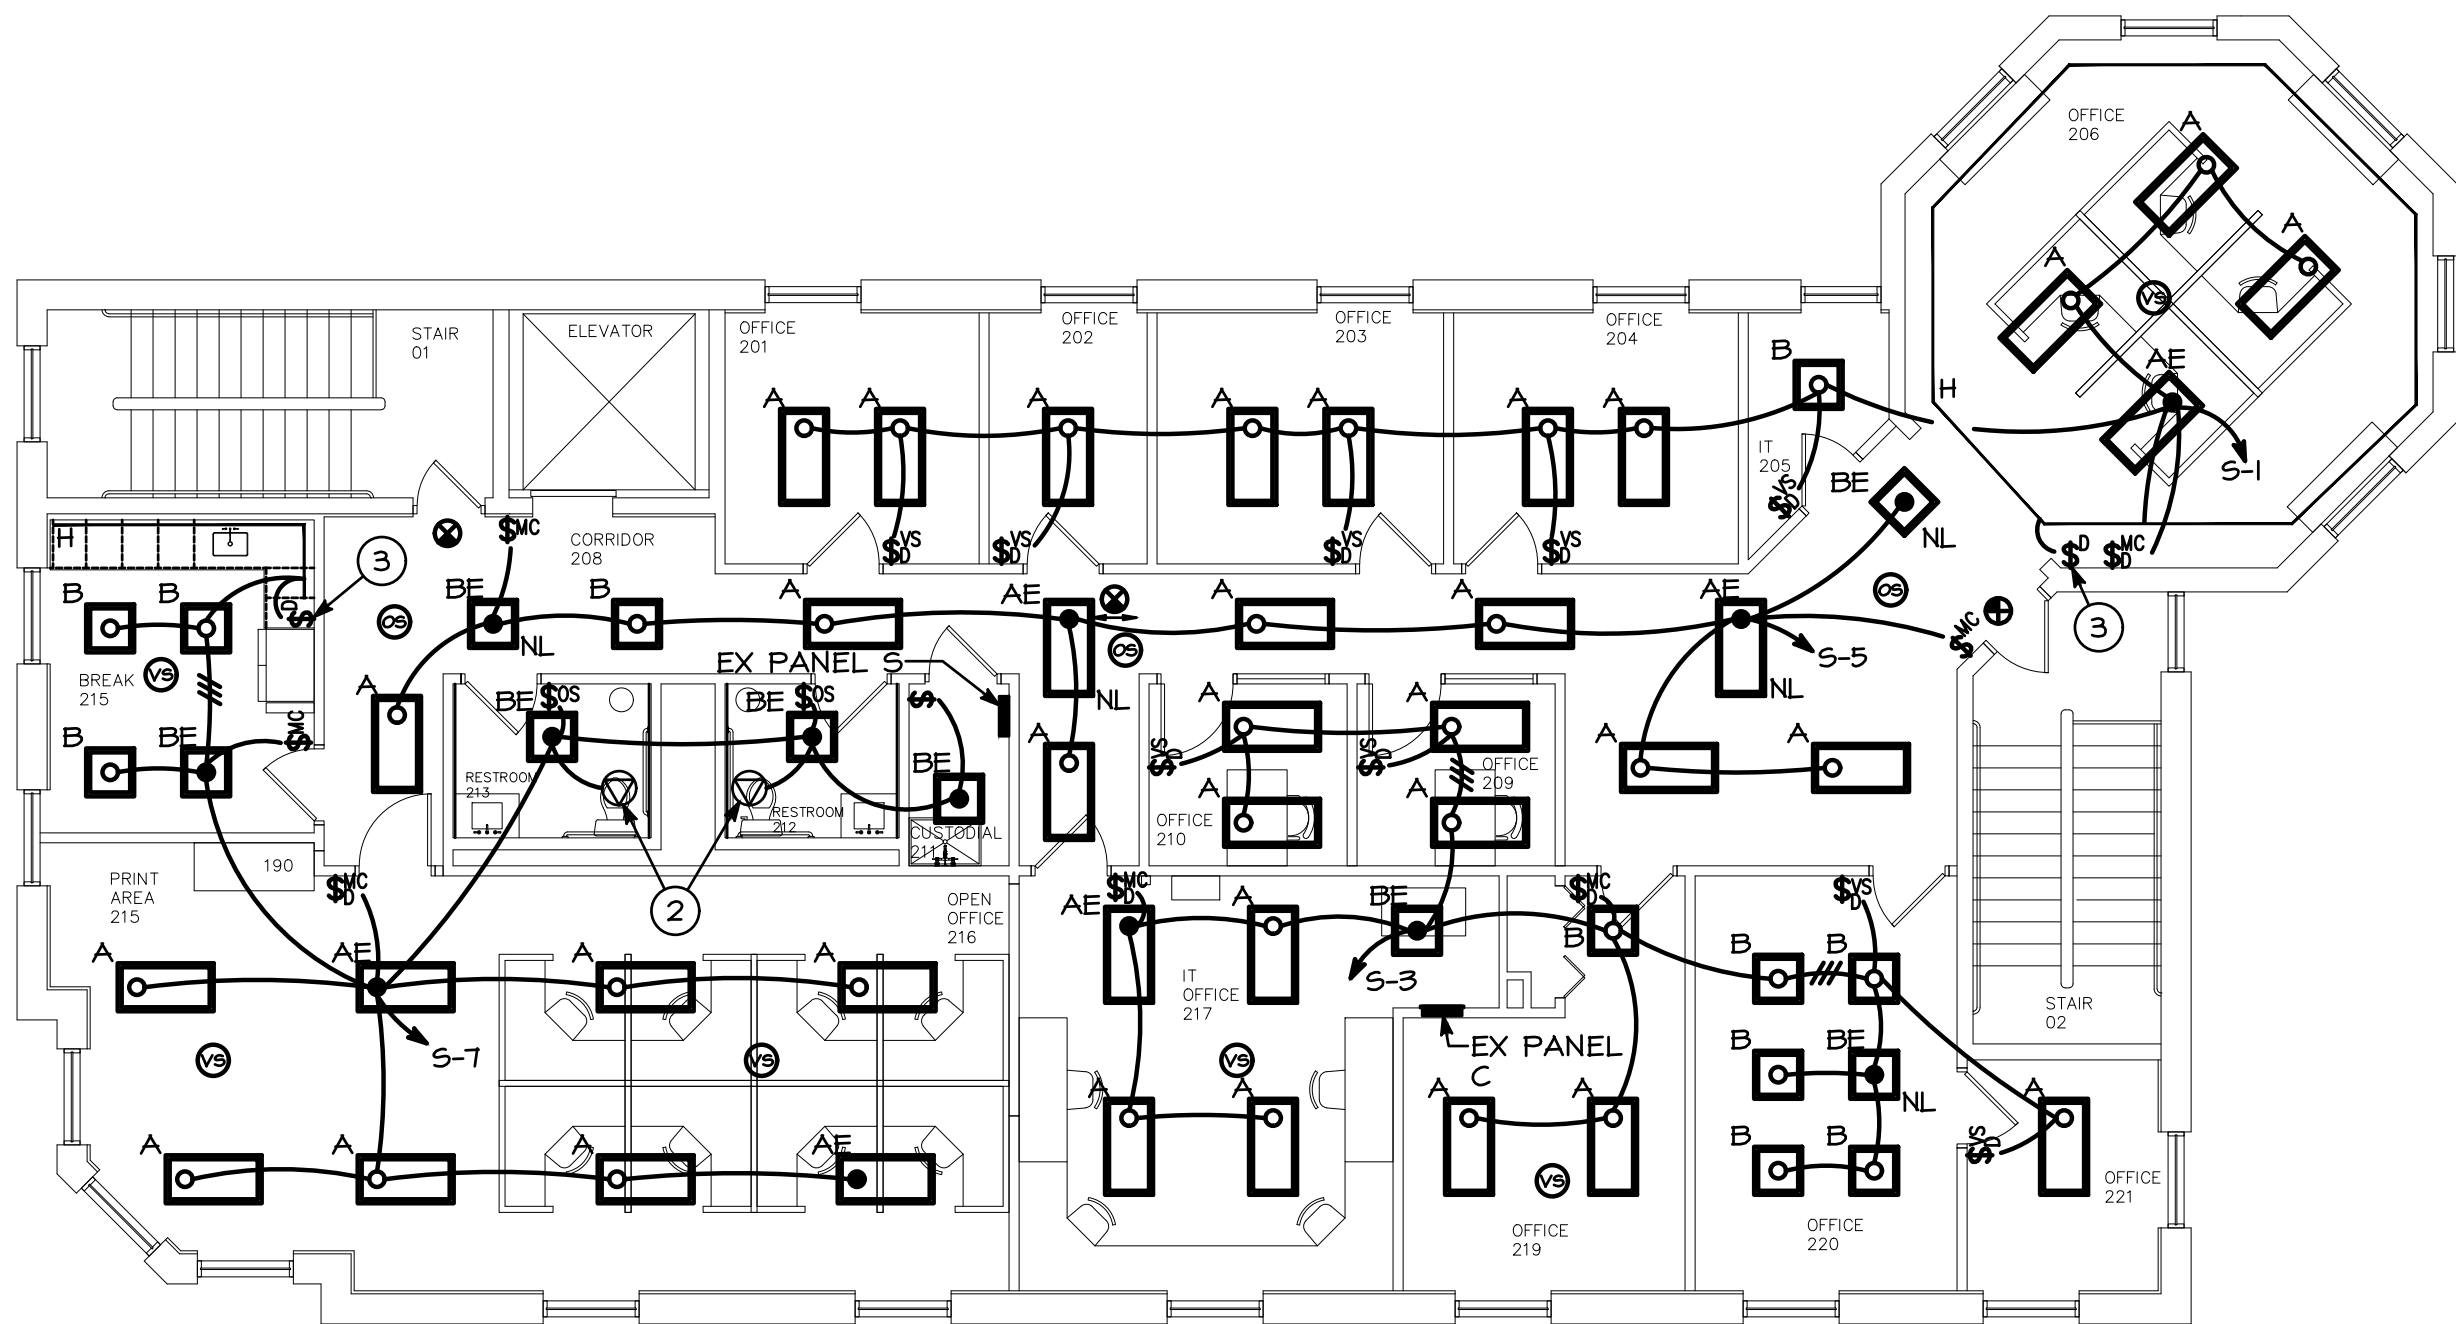

NEW WORK - SECOND FLOOR - LIGHTING
SCALE: 1/8"=1'-0"

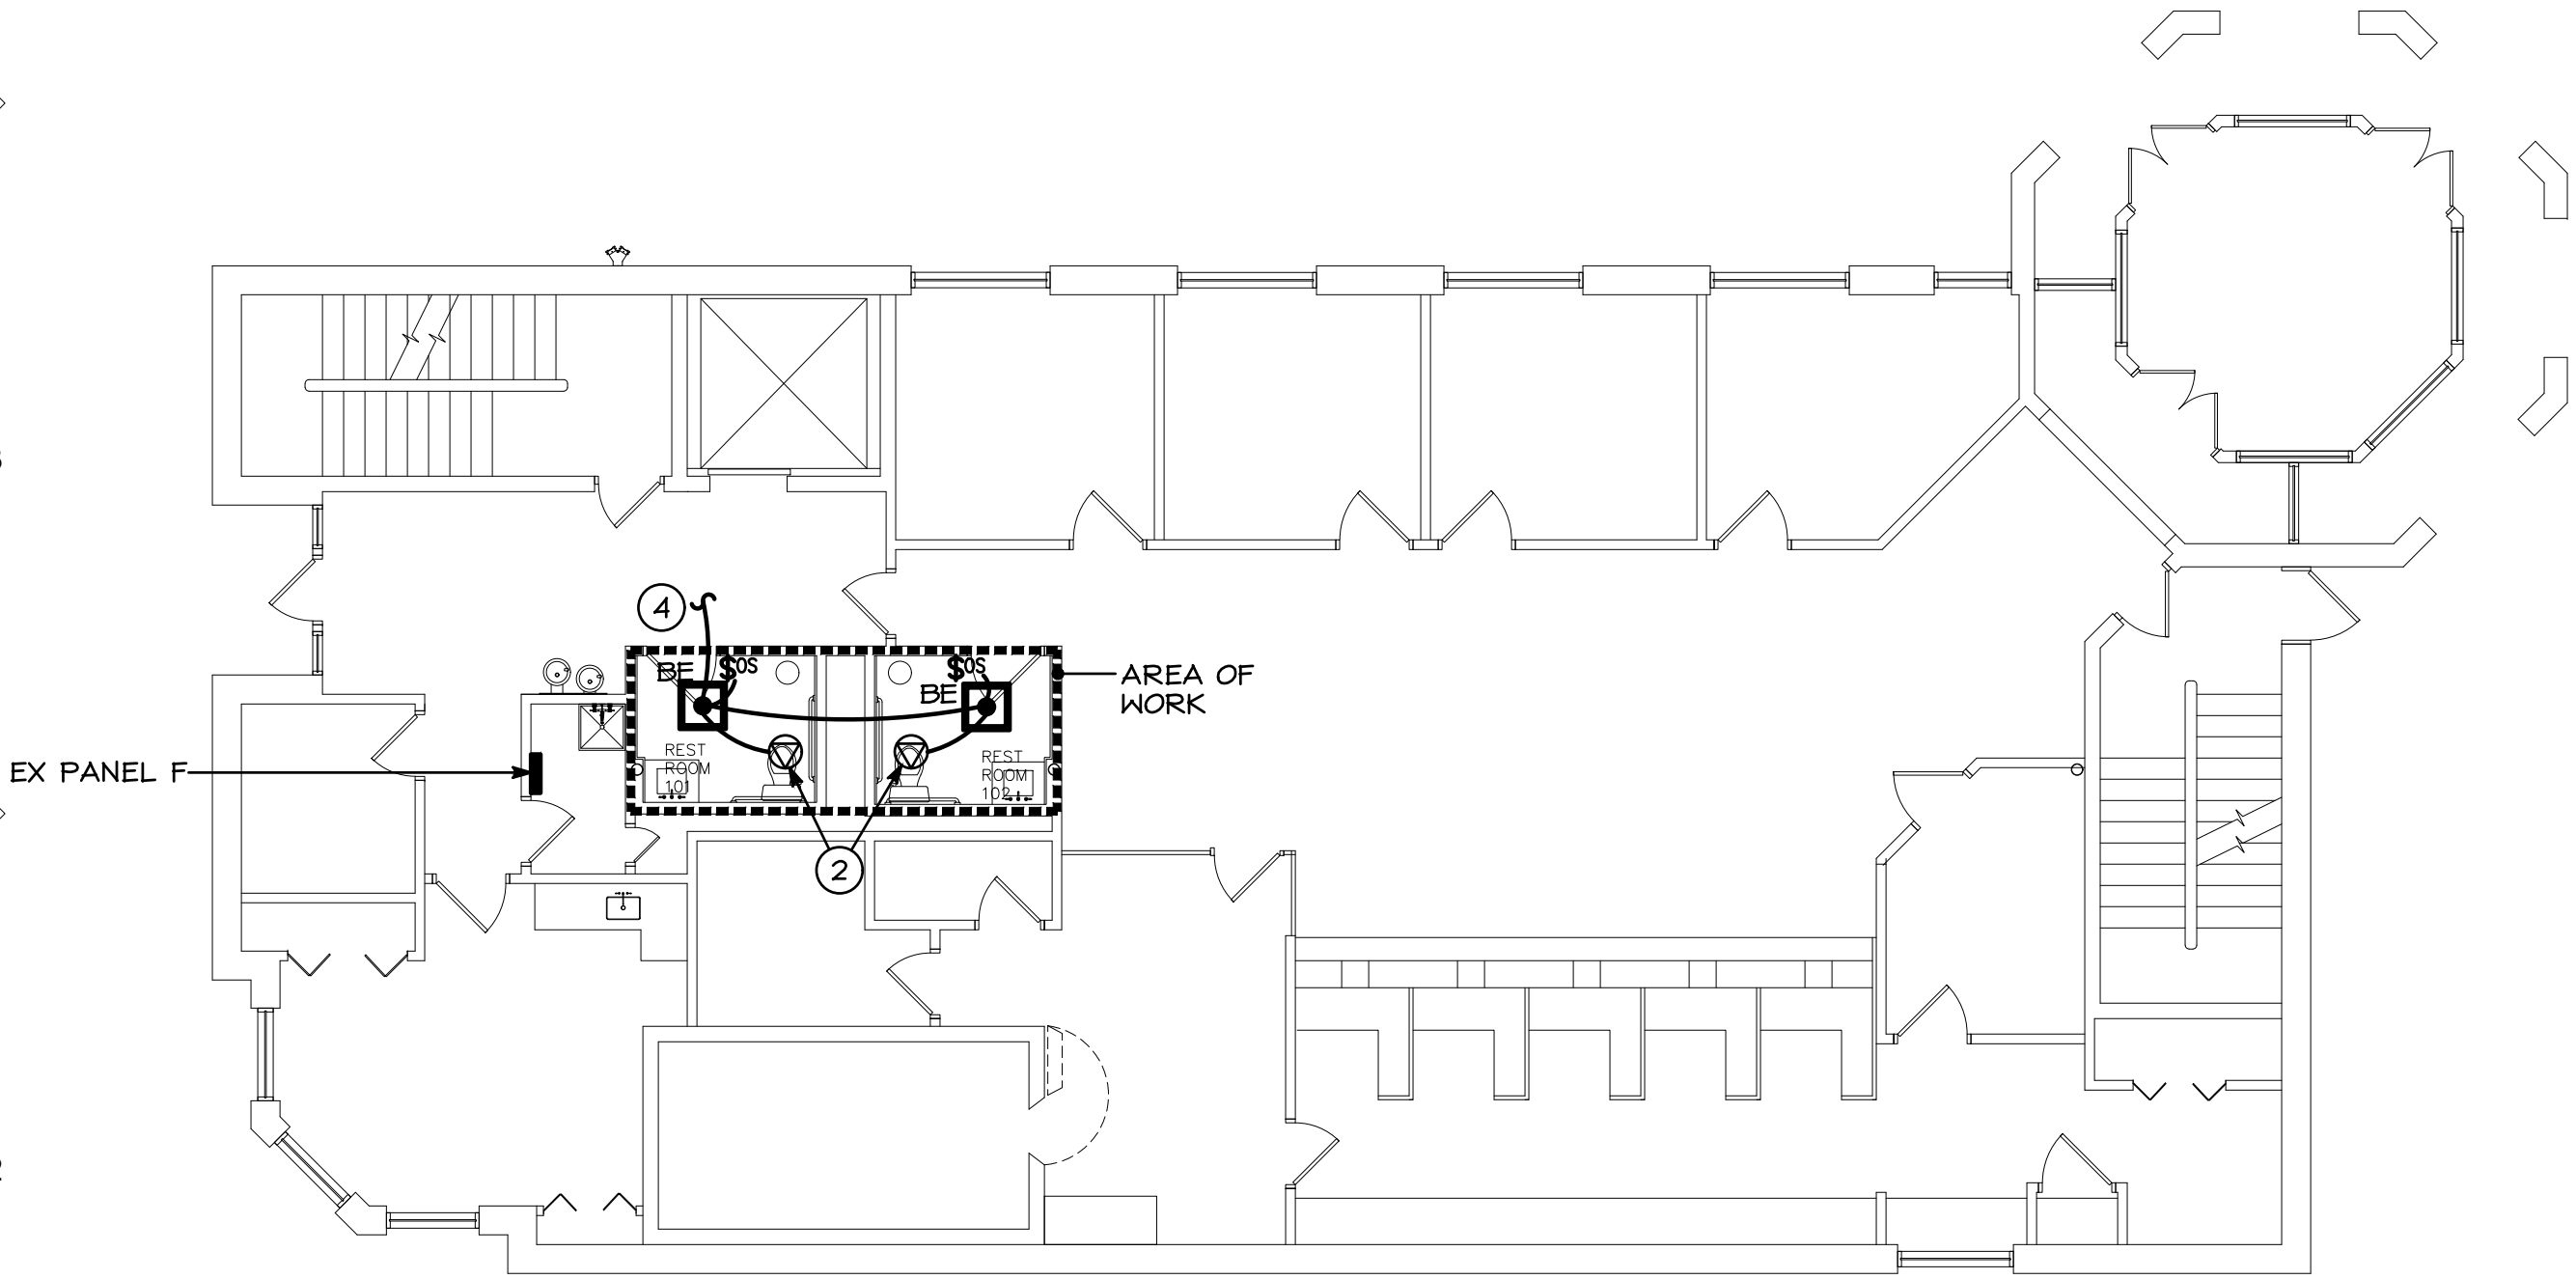

NEW WORK - FIRST FLOOR - LIGHTING
SCALE: 1/8"=1'-0"

GENERAL NOTES


- CONNECT EXIT SIGNS, EMERGENCY BATTERY UNITS AND NIGHT LIGHTS (NL) TO THE UNSWITCHED PORTION OF THE LIGHTING CIRCUIT SERVING THAT RESPECTIVE AREA.
- COORDINATE FINAL LOCATION OF ALL LIGHTS AND SWITCHES WITH THE TENANT PRIOR TO ROUGH-IN.
- REFER TO ARCHITECTURAL REFLECTED CEILING PLAN FOR GRID COORDINATION AND EXACT LOCATION OF LIGHT FIXTURES.
- ALL AREAS INDICATED WITH VACANCY SENSORS (VS) ARE TO BE WIRED FOR "MANUAL ON / AUTO OFF" (20 MINUTE MAX) OPERATION.

DRAWING NOTES

- EXHAUST FAN: 120V, 40.5W. CONNECT TO LIGHTING CIRCUIT.
- CONNECT EXISTING EXHAUST FAN TO LIGHTING CIRCUIT.
- 100W CONSTANT VOLTAGE LED DRIVER WITH INTEGRATED DIMMER FOR SINGLE GAN BOX. xDRIVE #AL-97-02-24100
- CONNECT TO EXISTING LIGHTING CIRCUIT SERVING THIS AREA.


LIGHT FIXTURE SCHEDULE					
TYPE	LAMPS/WATTS	MOUNTING	VOLTS	DESCRIPTION	CATALOG NO.
A	LED 38W	RECESSED	120	2'x4' LED TROFFER WITH CURVED ACRYLIC DIFFUSER AND DIMMING DRIVER, 5,100 LUMENS	HE WILLIAMS DIL-G-S-24-L51-835-AD-DIM-120
AE	LED 38W	RECESSED	120	SAME AS "A" BUT WITH EMERGENCY BATTERY	
B	LED 31W	RECESSED	120	2'x2' LED TROFFER WITH CURVED ACRYLIC DIFFUSER AND DIMMING DRIVER, 4,500 LUMENS	HE WILLIAMS DIL-G-S-22-L45-835-A-D-DIM-120
BE	LED 31W	RECESSED	120	SAME AS "B" BUT WITH EMERGENCY BATTERY	
C	LED 42W	SUSPENDED	120	4' STRIP, 4,800 LUMENS, DIMMING DRIVER	HE WILLIAMS FS4-L5-8CS
D	LED 16W	RECESSED	120	6" DOWNLIGHT, DIMMING DRIVER, 2,000 LUMENS	HE WILLIAMS 6DR-TL-L20-835-DIM-UNV-OW-OF-CS
DE	LED 16W	RECESSED		SAME AS "D" BUT WITH EMERGENCY BATTERY	
F	LED 48W	PENDANT	120	12', LINEAR, DIMMING DRIVER, 800 LUMENS	HE WILLIAMS LRX2-D-12'-L4-835-DMA-AC-**-DIM-120
G	LED 24W	PENDANT	120	6', LINEAR, DIMMING DRIVER, 800 LUMENS	HE WILLIAMS LRX2-D-6'-L4-835-DMA-AC-**-DIM-120
H	LED 100W	TAPE	120	TAPE LIGHT	ALLOY LED
	LED	UNIVERSAL	120	LED EXIT SIGN WITH RED LETTER & EMERGENCY NICKEL CADMIUM BATTERY *	LIGHT ALARMS SEN F TA GC SERIES
	LED	SURFACE WALL	120	EMERGENCY BATTERY PACK WITH WHITE CONTEMPORARY HOUSING **	LIGHT ALARMS LCA-2LEDR SERIES

* COORDINATE EXACT COLOR WITH AHJ.
** EMERGENCY OPERATION ONLY.

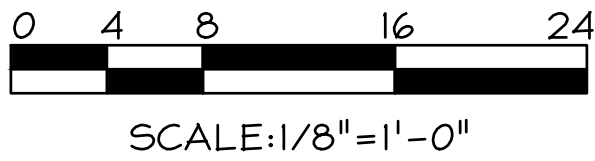

SCALE: 1/8"=1'-0"

FARMERS & MERCHANTS
BANK
25 WESTMINSTER PIKE
REISTERTOWN, MARYLAND, 21136
INTERIOR ALTERATION

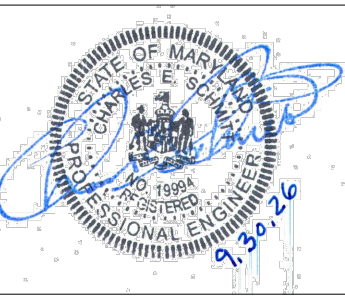


I CERTIFY THAT THESE DOCUMENTS WERE PREPARED OR APPROVED BY ME AND THAT I AM A DULY LICENSED PROFESSIONAL ENGINEER UNDER THE LAWS OF THE STATE OF MARYLAND.

LICENSE NO.: 19994
EXP. DATE: 3/31/2027

THESE DRAWINGS ARE NOT PERMITTED TO BE COPIED OR REPRODUCED, EITHER WHOLLY OR PARTIALLY, UNLESS WRITTEN PERMISSION IS FIRST OBTAINED FROM SANDERS DESIGNS, P.A.

MECHANICAL & ELECTRICAL
DESIGN CONSULTANTS, INC.
1907 N. Fountain Green Road
Bel Air, Maryland 21015-1411
410-869-2822 • Fax 410-869-0442
web site: www.jrsdesign.net

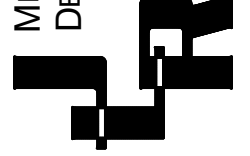


SANDERS | DESIGNS
ARCHITECTS PLANNERS
WWW.SANDERSDESIGNS.COM
MAILBOX@SANDERSDESIGNS.COM
9727 GREENSIDE DRIVE, SUITE 202, COCKEYSVILLE, MARYLAND 21030
T: (410) 660 2624

No.	Date	Revision


Project No.:
Date:
Scale:
Edition:
PERMIT SET
Drawing Name:
BASEMENT, FIRST, SECOND FLOOR - LIGHTING PLANS
Drawing Number:

E-4

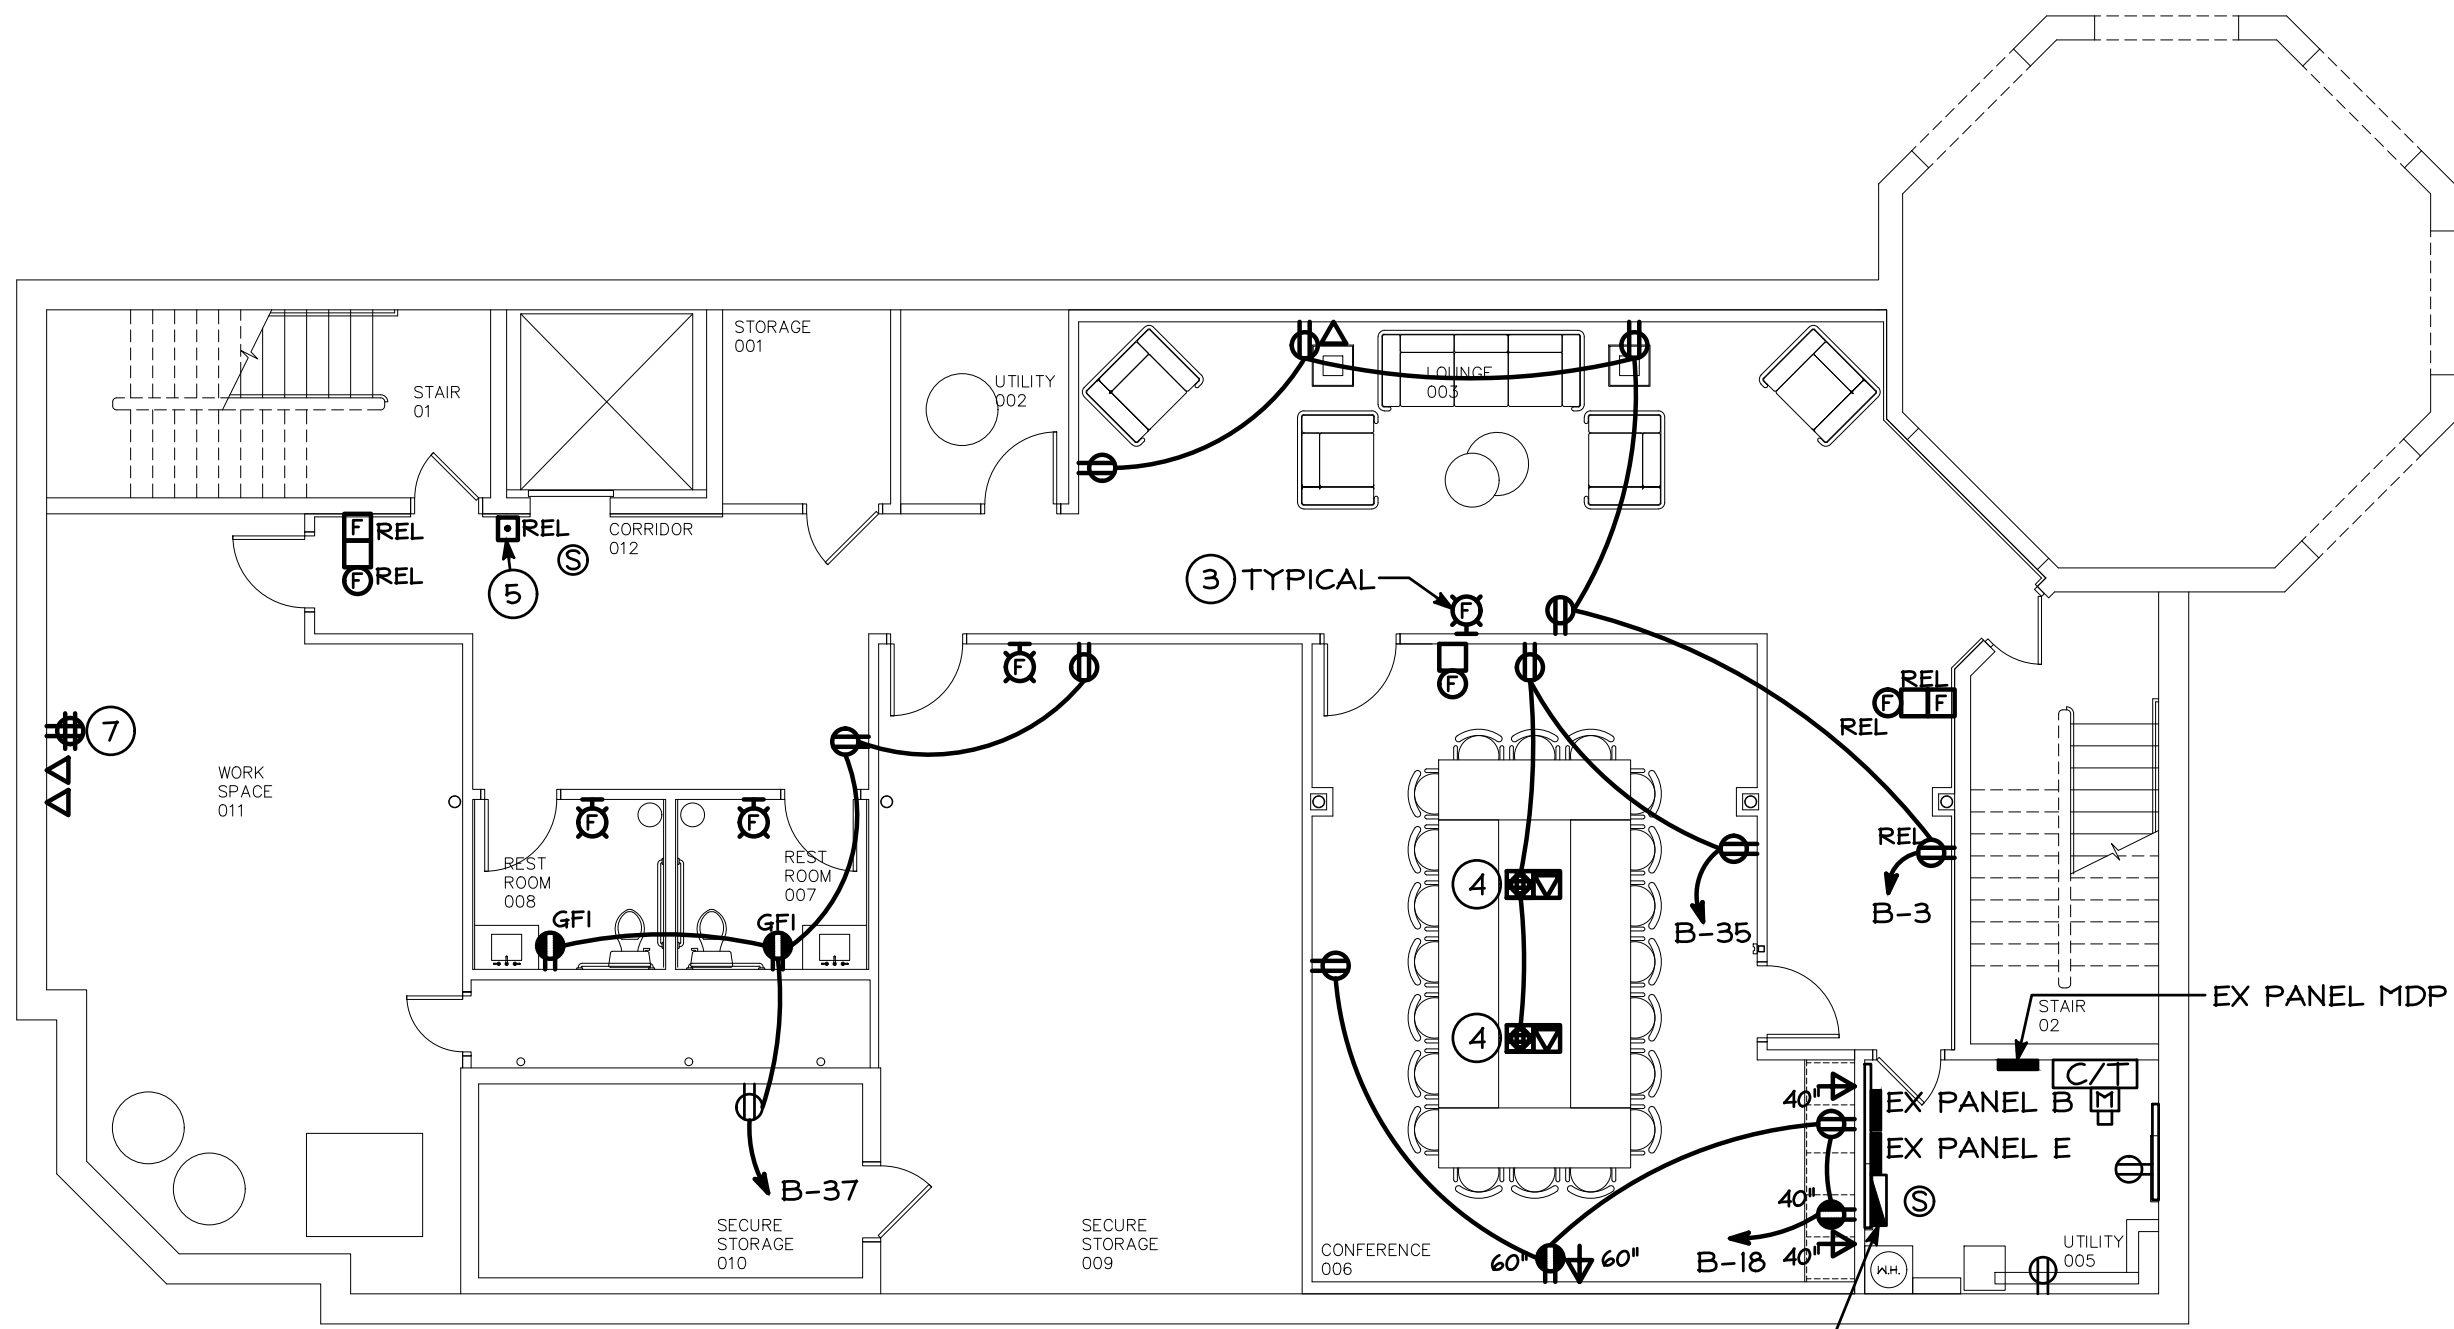

NEW WORK - BASEMENT FLOOR - POWER

SCALE: 1/8"=1'-0"

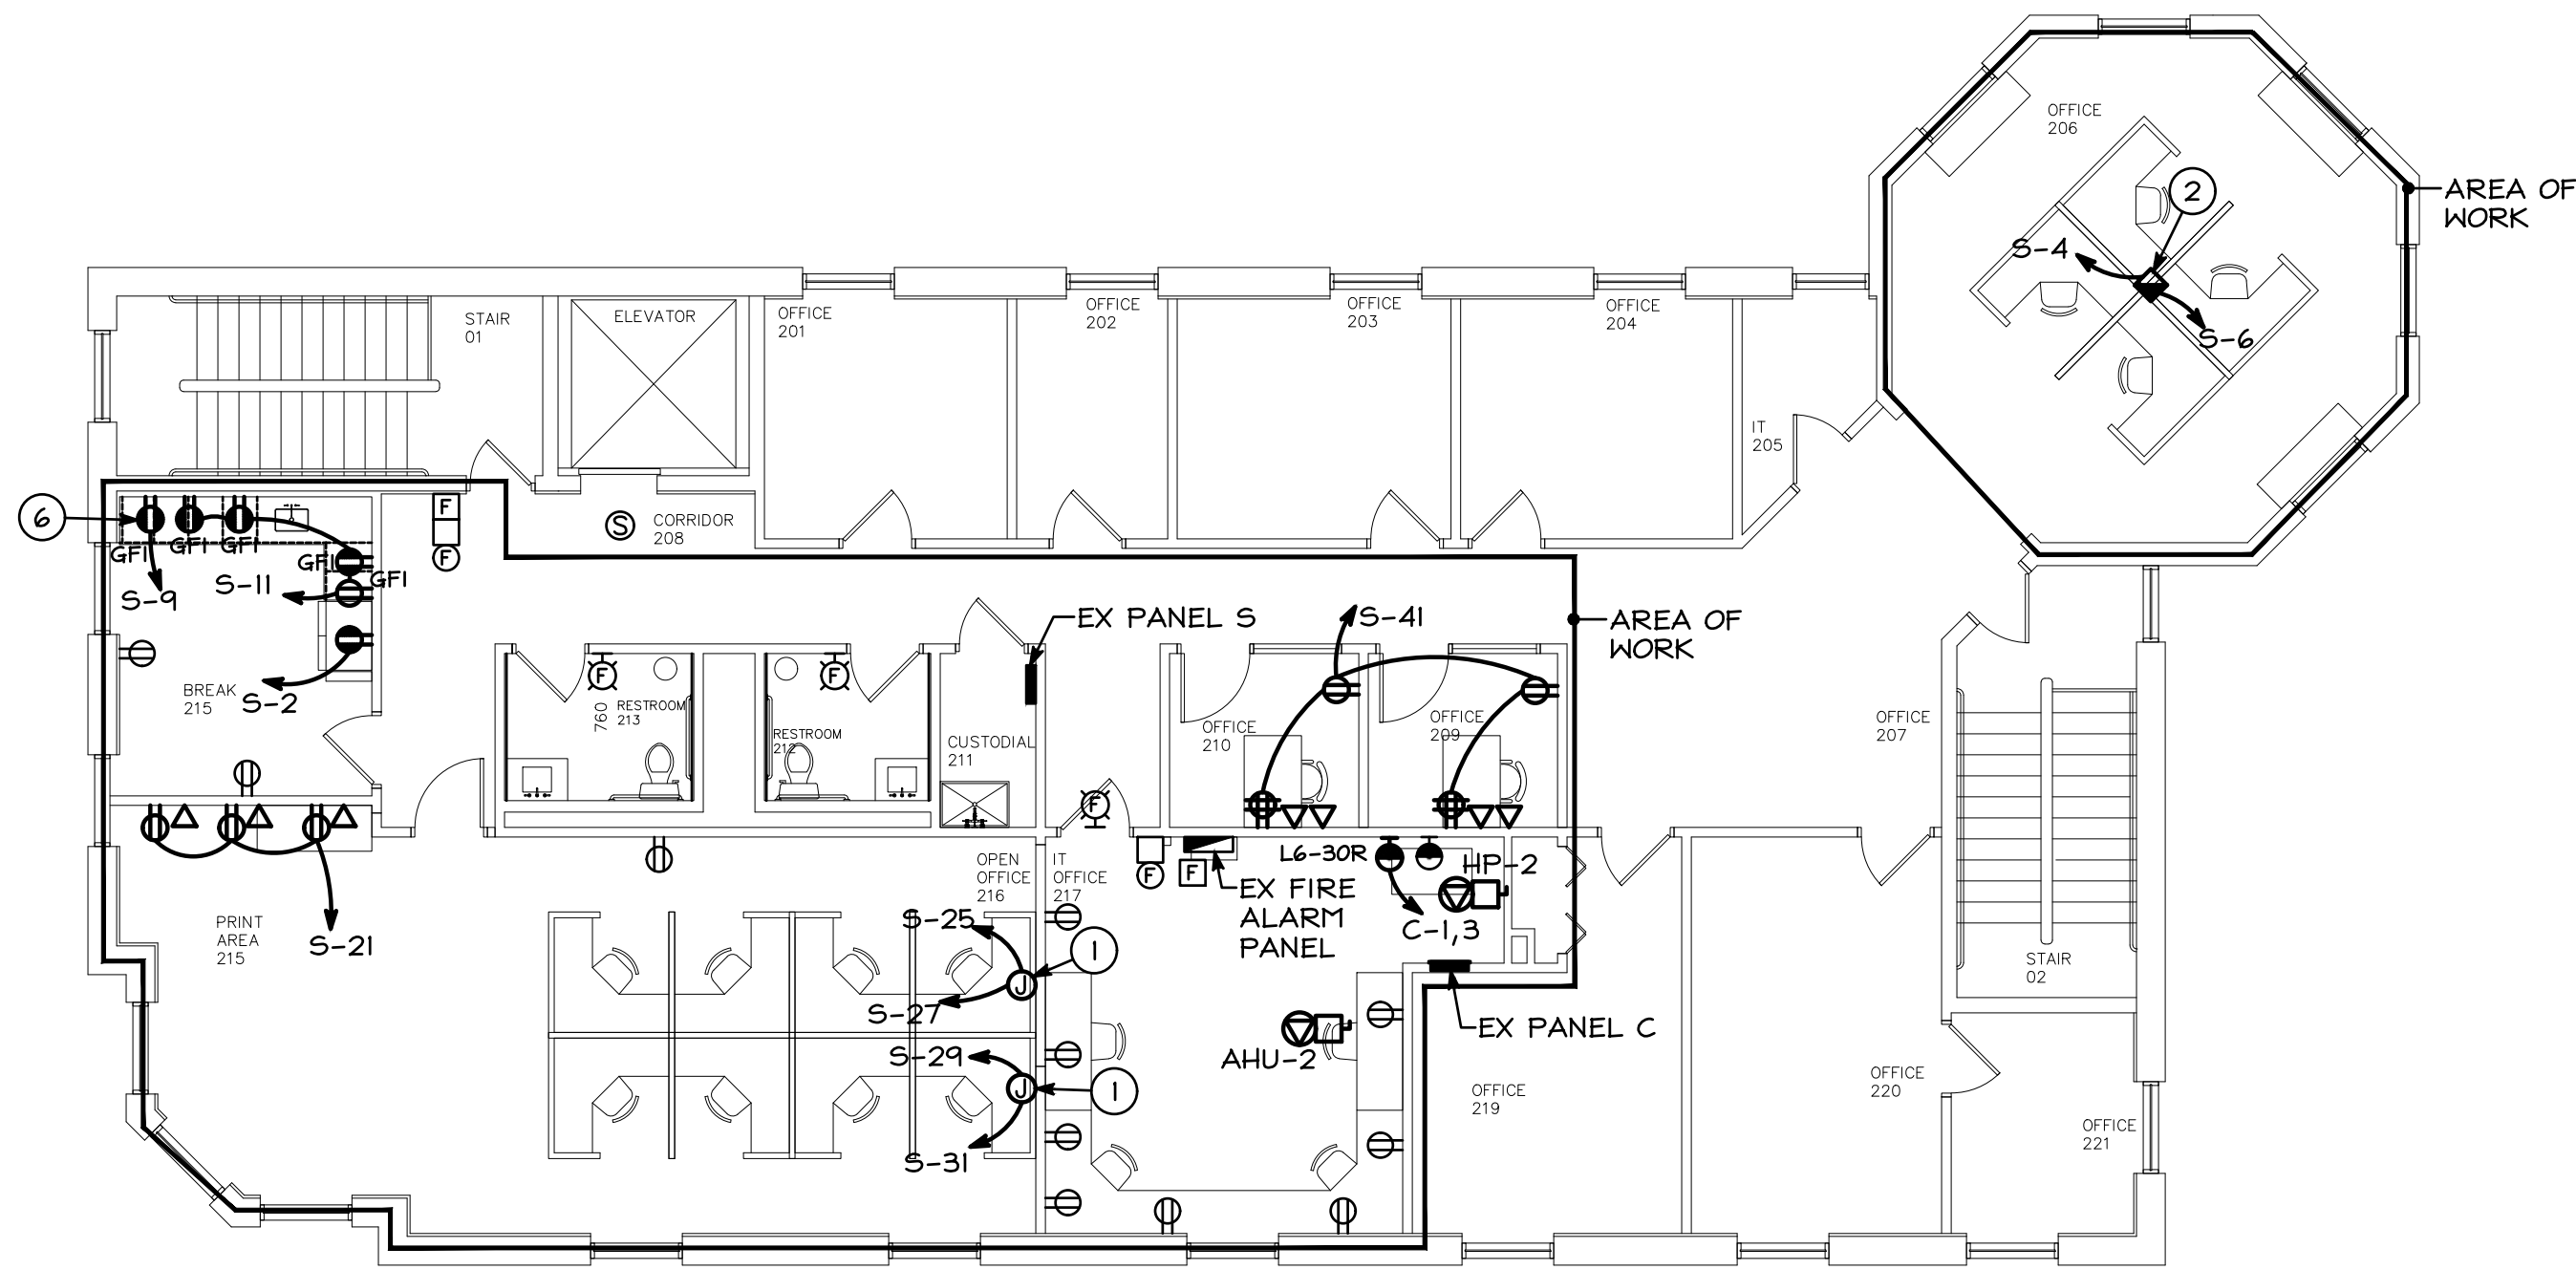

NEW WORK - SECOND FLOOR - POWER

SCALE: 1/8"=1'-0"

GENERAL NOTES

- RECEPTACLES INSTALLED IN ENCLOSED OFFICES, CONFERENCE ROOMS, COPY ROOMS, BREAK ROOMS, AND WORKSTATIONS, SHALL BE CONTROLLED SPLIT TYPE RECEPTACLE. RECEPTACLE TO BE CONTROLLED VIA WALL/CEILING VACANCY SENSOR. PROVIDE ADDITIONAL RELAYS AS REQUIRED.
- 25% OF BRANCH CIRCUIT FEEDERS FOR MODULAR FURNITURE SHALL BE CONTROLLED VIA CONTACTOR/TIME CLOCK.
- COORDINATE EXACT LOCATION/MOUNTING HEIGHT OF RECEPTACLES/DATA BOXES WITH OWNER PRIOR TO ROUGH-IN.
- CONNECT MOTOR OPERATED DAMPERS (MOD'S) LOCATED IN BASEMENT TO B-42. REFER TO MECHANICAL PLANS FOR EXACT LOCATIONS/QUANTITIES.

FIRE ALARM SYSTEM LAYOUT AND ZONING IS SCHEMATIC FOR BIDDING PURPOSES ONLY. ELECTRICAL CONTRACTORS FIRE ALARM VENDOR SHALL PREPARE COMPLETE SYSTEM SHOP DRAWINGS AND SUBMIT TO FIRE MARSHALL FOR APPROVAL


DRAWING NOTES

- TWO JUNCTION BOXES FOR MODULAR FURNITURE FEED. (1 POWER # 1 TELECOMMUNICATION). CONNECT POWER TO FURNITURE BY MANUFACTURER'S CABLE WHIP. PROVIDE 1" EMT TO CEILING FROM TELECOMMUNICATION BOX AND 1" FLEXIBLE CONDUIT TO FURNITURE FOR TELECOMMUNICATION CABLES. PROVIDE TWO 20A CIRCUITS, (1) CONTROLLED, (1) NON CONTROLLED.
- TWO CEILING MOUNTED JUNCTION BOXES FOR SERVICE TO POWER POLE TO SERVE WORKSTATIONS. (POWER # 1 TELECOMMUNICATION) PROVIDE TWO 20 AMP CIRCUITS, (1) CONTROLLED, (1) NOT CONTROLLED.
- PROVIDE NEW FIRE ALARM DEVICES THAT MATCH EXISTING DEVICES AND ARE COMPATIBLE WITH THE EXISTING FIRE ALARM SYSTEM. EXTEND AND CONNECT TO EXISTING FIRE ALARM PANEL PER MANUFACTURERS RECOMMENDATIONS. MAKE ALL MODIFICATIONS AND ADDITIONS AS NECESSARY TO THE EXISTING FIRE ALARM SYSTEM THAT PROVIDE A WORKING SYSTEM THAT MEETS ALL NFPA REQUIREMENTS.
- FLOOR BOX WITH (1) QUAD AND (1) DATA BOX. TRENCH FLOOR AND PROVIDE (1) 3/4" CONDUIT FOR POWER AND (1) 1" CONDUIT FOR DATA UP TO AND ABOVE ACCESSIBLE CEILING. COORDINATE EXACT REQUIREMENTS WITH OWNER PRIOR TO ROUGH IN.
- RELOCATED ELEVATOR CONTROLS, EXTEND AND RECONNECT TO CIRCUIT PREVIOUSLY SERVING.
- MOUNTED ABOVE COUNTER FOR MICROWAVE. COORDINATE EXACT LOCATION/HEIGHT IN FIELD.
- CONNECT TO EXISTING RECEPTACLE CIRCUIT PREVIOUSLY SERVING.

MECHANICAL UNIT SCHEDULE

UNIT NUMBER	UNIT MCA	UNIT MOCF	UNIT VOLTS/Ø	CIRCUIT NUMBER	NOTES
AHU-2	5	15	208V/1Ø	C-2,4	1, 2
HP-2	15	20	208V/1Ø	C-47,49	1, 2

- NOTE:
- SEE PANEL SCHEDULE FOR CONDUCTOR SIZES
 - AHU-2/HP-2 IS A BACKUP SYSTEM THAT WILL ONLY RUN IF EX AHU-1/ EX HP-1 GOES DOWN. REFER TO MECHANICAL PLANS FOR ADDITIONAL INFORMATION.

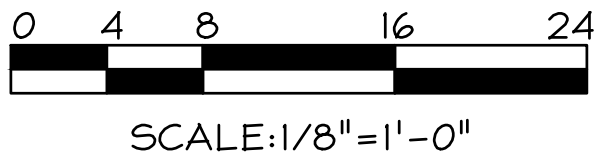

FARMERS & MERCHANTS
BANK
25 WESTMINSTER PIKE
REISTERTOWN, MARYLAND, 21136
INTERIOR ALTERATION



I CERTIFY THAT THESE DOCUMENTS WERE PREPARED OR APPROVED BY ME AND THAT I AM A DULY LICENSED PROFESSIONAL ENGINEER UNDER THE LAWS OF THE STATE OF MARYLAND.

LICENSE NO.: 19994
EXP. DATE: 3/31/2027

THESE DRAWINGS ARE NOT PERMITTED TO BE COPIED OR REPRODUCED, EITHER WHOLLY OR PARTIALLY, UNLESS WRITTEN PERMISSION IS FIRST OBTAINED FROM SANDERS DESIGNS, P.A.

MECHANICAL & ELECTRICAL
DESIGN CONSULTANTS, INC.
1907 N. Fountain Green Road
Bel Air, Maryland 21015-1411
410-869-2822 • Fax 410-869-0442
web site: www.jrsdesign.net

SANDERS | DESIGNS
ARCHITECTS PLANNERS
WWW.SANDERSDESIGNS.COM
9727 GREENSIDE DRIVE, SUITE 202, COCKEYSVILLE, MARYLAND 21030
T: (410) 860 2624

No.	Date	Revision

Project No.:
Date:
Scale:
Edition:
PERMIT SET

Drawing Name:
BASEMENT & SECOND FLOOR POWER PLANS

Drawing Number:

E-5

G				F				E							
CKT	QTY			NON/	PNL	SUBPNL	DEMAND	TOTAL							
				DEMANC	CONT	KVA	KVA	KVA							
1	Lighting [L]	1	C	4.0	15.8	19.8	24.8		PANEL CONNECTED LOAD	182.8 KVA	@ 400 AMPS				
	Receptacles [R] *	0.5	N		77.1	43.6	43.6		PANEL DEMAND LOAD	135.8 KVA	144.1 CB MAX KVA				
	Motors [M]	1	<M/H>						TOTAL PANEL LOAD	141.8 KVA					
	Motors (alternate) [M2]	1	<M/H>							393.6 AMPS					
	Multimotor/Combination [MM]	1	<M/H>												
	Heating [H] **	1	<M/H>	13.5		**	**		SPARE CAPACITY =	2.3 KVA					
	Air Conditioning [A] **	1	<M/H>	47.1	47.1	47.1	47.1		(BASED ON CB)	6.4 AMPS					
3	Other (appliances, etc.) [O]	1	N	18.2	2.6	20.8	20.8			1.6 %					
	Auxiliary [X]	1	C		4.5	4.5	5.6								
	Kitchen [K]	0.65	N												
FOR CONT. LOADS (C), TOTAL KVA=DEMAND KVA*1.25; FOR NONCONT. (N) & MOTOR/HEATING <M/H> LOADS, TOTAL KVA=DEMAND KVA															
* IF RECEPTACLE LOAD IS >10KVA, RECEPTACLE DEMAND LOAD IS (CONNECTED LOAD - 10KVA) * .5 + 10KVA															
** INDICATES GREATER OF HEATING OR COOLING. GREATEST SEASONAL LOAD SAME															
EXISTING															
SURFACE MOUNTED PANEL MDP 120/208 VOLT 3 PHASE 4 WIRE 800 AMP BUS 400 AMP MAIN BREAKER EXISTING A.I.C.															
CKT NO.	FOR	BRANCH FRAME	BREAKERS P	# TRIP	WIRING SETS	# SIZE	COND. GND	CKT NO.	FOR	BRANCH FRAME	BREAKERS P	# TRIP	WIRING SETS	# SIZE	COND. GND
1	EX PANEL C	100	3	100	EX	EX	EX	2	EX PANEL S	100	3	100	EX	EX	EX
3	-----	-----	-----	-----	-----	-----	-----	4	-----	-----	-----	-----	-----	-----	-----
5	-----	-----	-----	-----	-----	-----	-----	6	-----	-----	-----	-----	-----	-----	-----
7	EX PANEL F	225	3	125	EX	EX	EX	8	EX PANEL B	225	3	125	EX	EX	EX
9	-----	-----	-----	-----	-----	-----	-----	10	-----	-----	-----	-----	-----	-----	-----
11	-----	-----	-----	-----	-----	-----	-----	12	-----	-----	-----	-----	-----	-----	-----
13	EX 2ND FLOOR PANEL "R"	225	3	200	EX	EX	EX	EX	14	EX ELEVATOR CB	225	3	200	EX	EX
15	-----	-----	-----	-----	-----	-----	-----	16	-----	-----	-----	-----	-----	-----	-----
17	-----	-----	-----	-----	-----	-----	-----	18	-----	-----	-----	-----	-----	-----	-----
19	EX PANEL E	100	3	60	EX	EX	EX	EX	20	SPACE	100	1	-----	-----	-----
21	-----	-----	-----	-----	-----	-----	-----	22	EX FIRE ALARM	100	1	20	EX	EX	EX
23	-----	-----	-----	-----	-----	-----	-----	24	EX CKT	100	1	20	EX	EX	EX
L	4.0														

CKT	QTY		NON/	PNL	SUBPNL	DEMAND	TOTAL		
			DEMANC	KVA	KVA	KVA	KVA		
13	Lighting [L]	1	C	5.9	5.9	7.4		PANEL CONNECTED LOAD	32.4 KVA
9	Receptacles [R] *	0.5	N	6.4	6.4	6.4		PANEL DEMAND LOAD	32.4 KVA
	Motors [M]	1	<M/H>						@ 125 AMPS
	Motors (alternate) [M2]	1	<M/H>						45.0 CB MAX KVA
	Multimotor/Combination [MM]	1	<M/H>					TOTAL PANEL LOAD	35.0 KVA
	Heating [H] **	1	<M/H>	13.5	13.5	13.5			97.2 AMPS
	Air Conditioning [A] **	1	<M/H>					SPARE CAPACITY =	10.0 KVA
	Other (appliances, etc.) [O]	1	N	2.1	2.1	2.1		(BASED ON CB)	27.8 AMPS
5	Auxiliary [X]	1	C	4.5	4.5	5.6			22.3 %
1	Kitchen [K]	0.65	N						

FOR CONT. LOADS (C), TOTAL KVA=DEMAND KVA*1.25; FOR NONCONT. (N) & MOTOR/HEATING <M/H> LOADS, TOTAL KVA=DEMAND KVA

* IF RECEPTACLE LOAD IS >10KVA, RECEPTACLE DEMAND LOAD IS (CONNECTED LOAD - 10KVA) * .5 + 10KVA

** INDICATES GREATER OF HEATING OR COOLING. GREATEST SEASONAL LOAD SAME

EXISTING																	
SURFACE MOUNTED PANEL B 120/208 VOLT 3 PHASE 4 WIRE 200 AMP BUS MAIN LUGS ONLY 10,000 A.I.C.																	
TYPE	KVA	HP	CKT NO.	FOR	BRANCH BREAKERS	#	WIRING	COND.	CKT NO.	FOR	BRANCH BREAKERS	#	WIRING	COND.	TYPE	KVA	HP
					FRAME	P	TRIP	SETS	#	SIZE	GND						
L	0.1		1	BLK RM LIGHTS	100	1	20	1	2	12	12	3/4"	2	EX ELEVATOR MACHINE RM	100	1	20 EX EX EX EX
R	1.0		3	BASEMENT RECEPTS	100	1	20	1	2	12	12	3/4"	4	EX ELEVATOR PIT	100	1	20 EX EX EX EX
L	1.6		5	BASEMENT LIGHTS	100	1	20	1	2	12	12	3/4"	6	EX ELEVATOR LTG	100	1	20 EX EX EX EX
R	0.2		7	EX PANEL WALL RECEPT	100	1	20	EX	EX	EX	EX	EX	8	EX RECEPT SOUTH WALL	100	1	20 EX EX EX EX
O	0.5		9	EX SUMP	100	1	20	EX	EX	EX	EX	EX	10	EX REAR REAR WALL	100	1	20 EX EX EX EX
R	0.4		11	EX TELE RECEPT	100	1	20	EX	EX	EX	EX	EX	12	EX LTG/RECEPT VAULT	100	1	20 EX EX EX EX
L	0.3		13	EX STAIRWELL LTG FRONT	100	1	20	EX	EX	EX	EX	EX	14	EX SUMP PUMP	100	1	20 EX EX EX EX
L	0.1		15	EX TIME CLOCK/PHOTO CELL	100	1	20	EX	EX	EX	EX	EX	16	EX SUMP PUMP	100	1	20 EX EX EX EX
L	0.3		17	EX CANOPY LTG	100	1	20	EX	EX	EX	EX	EX	18	BASEMENT RECEPTS	100	1	20 1 2 12 12 3/4"
L	0.3		19	EX DRIVE THRU	100	1	20	EX	EX	EX	EX	EX	20	EX WINDOW HTR	100	2	20 EX EX EX EX
H	0.5		21	EX GEN JACKET HEATER	100	1	20	EX	EX	EX	EX	EX	22	-----	-----	-----	-----
H	7.0		23	EX BASEMENT HTR	100	2	60	EX	EX	EX	EX	EX	24	EX WINDOW HTR	100	2	20 EX EX EX EX
			25	-----	-----	-----	-----	-----	-----	-----	-----	-----	26	-----	-----	-----	-----
			27	SPARE	100	2	20	-----	-----	-----	-----	-----	28	EX WINDOW HTR	100	2	20 EX EX EX EX
			29	-----	-----	-----	-----	-----	-----	-----	-----	-----	30	-----	-----	-----	-----
L	0.3		31	EX REAR STAIRWELL LTG	100	1	20	EX	EX	EX	EX	EX	32	EX WINDOW HTR	100	2	20 EX EX EX EX
R	0.2		33	EX ATM	100	1	20	EX	EX	EX	EX	EX	34	-----	-----	-----	-----
R	1.2		35	BASEMENT RECEPTS	100	1	20	1	2	12	12	3/4"	36	EX WATER HTR	100	2	30 EX EX EX EX
R	1.0		37	BASEMENT RECEPTS	100	1	20	1	2	12	12	3/4"	38	-----	-----	-----	-----
L	1.2		39	EX FRONT SIGN	100	1	20	EX	EX	EX	EX	EX	40	EX DRIVE TUBE	100	1	20 EX EX EX EX
L	0.5		41	EX DRIVE THRU	100	1	20	EX	EX	EX	EX	EX	42	MOTOR OPERATED DAMPER	100	1	20 1 2 12 12 3/4"

NOTES:

• BOLD INDICATES NEW WORK

NOTES:
• BOLD INDICATES NEW WORK

CKT			NON/	PNL	SUBPNL	DEMAND	TOTAL		
QTY			DEMANC	CONT	KVA	KVA	KVA		
5	Lighting [L]	1	C	2.8		2.8	3.5		
34	Receptacles [R] *	0.5	N	24.0		17.0	17.0		
	Motors [M]	1	<M/H>						
	Motors (alternate) [M2]	1	<M/H>						
	Multimotor/Combination [MM]	1	<M/H>						
	Heating [H] **	1	<M/H>						
	Air Conditioning [A] **	1	<M/H>						
	Other (appliances, etc.) [O]	1	N						
	Auxiliary [X]	1	C						
	Kitchen [K]	0.65	N						

PANEL CONNECTED LOAD26.8 KVA@ 100 AMPS

PANEL DEMAND LOAD19.8 KVA36.0 CB MAX KVA

TOTAL PANEL LOAD20.5 KVA56.9 AMPS

SPARE CAPACITY =15.5 KVA43.1 AMPS

(BASED ON CB)43.1 %

FOR CONT. LOADS (C), TOTAL KVA=DEMAND KVA*1.25; FOR NONCONT. (N) & MOTOR/HEATING <M/H> LOADS, TOTAL KVA=DEMAND KVA

* IF RECEPTACLE LOAD IS >10KVA, RECEPTACLE DEMAND LOAD IS (CONNECTED LOAD - 10KVA) * .5 + 10KVA


** INDICATES GREATER OF HEATING OR COOLING. GREATEST SEASONAL LOAD SAME

EXISTING																																																																																																																																																																																																																																																																																																																																																																																																																																																																																																																																																																																																																																																																																																																																																																																																																																																																																																																																																																																																																																																																																																																																																																																																																																																																															
SURFACE MOUNTED PANEL S 120/208 VOLT 3 PHASE 4 WIRE 200 AMP BUS MAIN LUGS ONLY 10,000 A.I.C.																																																																																																																																																																																																																																																																																																																																																																																																																																																																																																																																																																																																																																																																																																																																																																																																																																																																																																																																																																																																																																																																																																																																																																																																																																																																															
TYPE	KVA	HP	CKT NO.	FOR	BRANCH BREAKERS			#	WIRING			COND.	CKT NO.	FOR	BRANCH BREAKERS			#	WIRING			COND.	TYPE	KVA	HP																																																																																																																																																																																																																																																																																																																																																																																																																																																																																																																																																																																																																																																																																																																																																																																																																																																																																																																																																																																																																																																																																																																																																																																																																																																						
					FRAME	P	TRIP	SETS	SIZE	GND						FRAME	P	TRIP	SETS	SIZE	GND																																																																																																																																																																																																																																																																																																																																																																																																																																																																																																																																																																																																																																																																																																																																																																																																																																																																																																																																																																																																																																																																																																																																																																																																																																																										

NOTES:
• BOLD INDICATES NEW WORK
• (GFI) INDICATES BREAKER TO BE GFI TYPE

DRAWING NOTES

- EXISTING INCOMING SERVICE FROM UTILITY COMPANY TO REMAIN.
- EXISTING PANEL TO REMAIN, REFER TO SCHEDULE THIS SHEET.
- EXISTING PANEL TO REMAIN, (NO NEW WORK IN THIS PANEL).

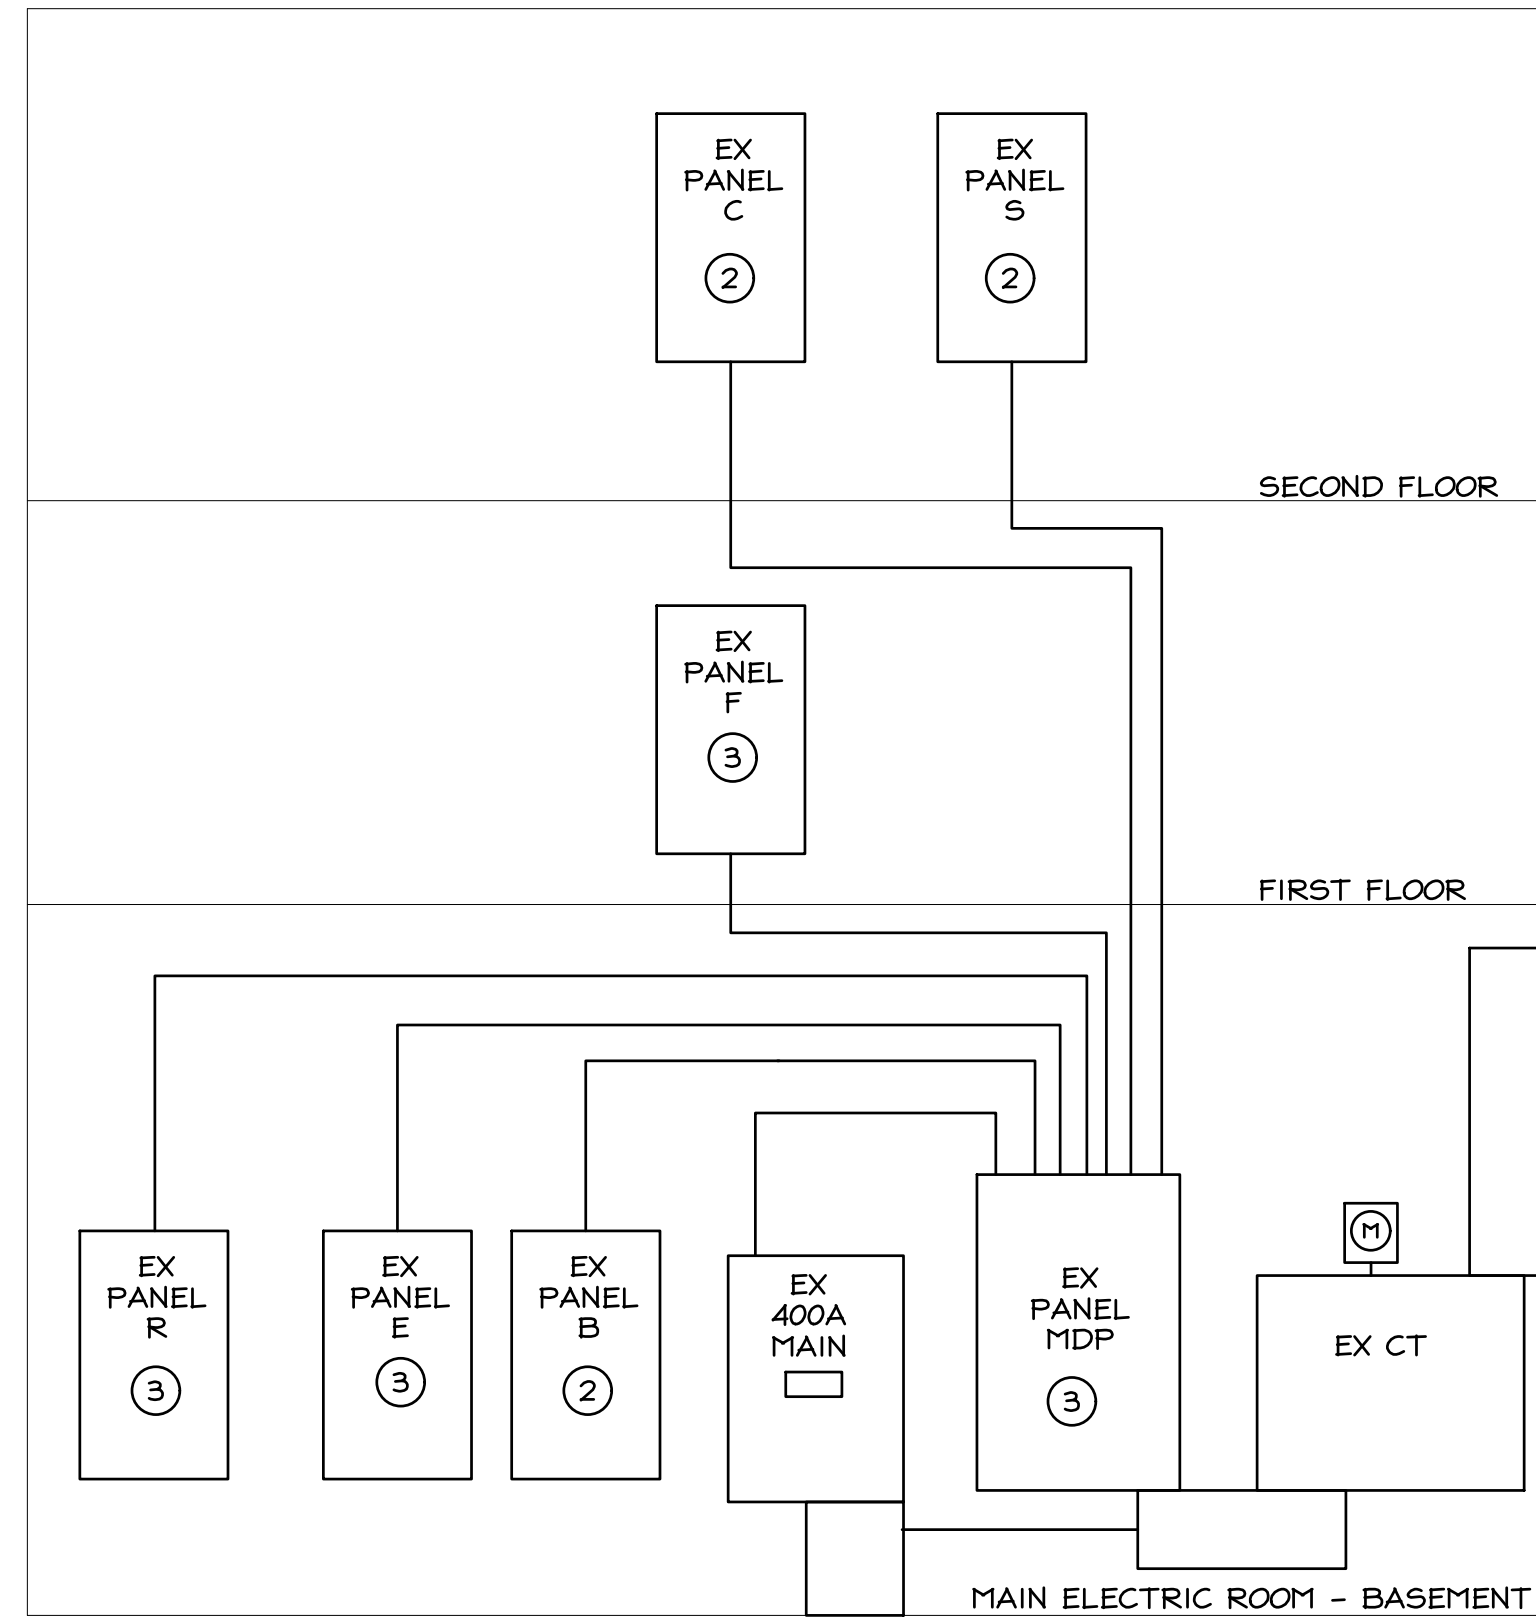

EXISTING POWER RISER DIAGRAM

NO SCALE

CKT	QTY		NON/	PNL	SUBPNL	DEMAND	TOTAL	
			DEMANC	CONT	KVA	KVA	KVA	
35		Lighting [L]	1	C				
		Receptacles [R] *	0.5	N	29.0	19.5	19.5	
		Motors [M]	1	<M/H>				
		Motors (alternate) [M2]	1	<M/H>				
		Multimotor/Combination [MM]	1	<M/H>				
		Heating [H] **	1	<M/H>		**	**	
		Air Conditioning [A] **	1	<M/H>	2.1	2.1	2.1	
		Other (appliances, etc.) [O]	1	N	0.5	0.5	0.5	
		Auxiliary [X]	1	C				
		Kitchen [K]	0.65	N				
PANEL CONNECTED LOAD 31.6 KVA PANEL DEMAND LOAD 22.1 KVA @ 100 AMPS 36.0 CB MAX KVA TOTAL PANEL LOAD 22.1 KVA 61.3 AMPS SPARE CAPACITY = 13.9 KVA (BASED ON CB) 38.7 AMPS 38.7 %								
FOR CONT. LOADS (C), TOTAL KVA=DEMAND KVA*1.25; FOR NONCONT. (N) & MOTOR/HEATING <M/H> LOADS, TOTAL KVA=DEMAND KVA * IF RECEPTACLE LOAD IS >10KVA, RECEPTACLE DEMAND LOAD IS (CONNECTED LOAD - 10KVA) * .5 + 10KVA ** INDICATES GREATER OF HEATING OR COOLING. GREATEST SEASONAL LOAD SAME								

EXISTING																						
RUSH MOUNTED PANEL C 120/208 VOLT 3 PHASE 4 WIRE 100 AMP BUS 100 AMP MAIN IN BREAKER 10,000 A.I.C.																						
TYPE	KVA	HP	CKT NO.	FOR	BRANCH BREAKERS	#	WIRING	COND.	CKT NO.	FOR	BRANCH BREAKERS	#	WIRING	COND.	TYPE	KVA	HP					
					FRAME	P	TRIP	SETS	#	SIZE	GND											
			1	IT RECEPT	100	2	10	1	2	10	3/4"	2	HP-2 (BACKUP UNIT)	100	2	20	1	2	12	12	3/4"	
			3	*****	100	2	10	1	2	10	3/4"	4	*****	100	2	20	1	2	12	12	3/4"	
R	2.5		5	EX IT RECEPT	100	1	30	EX	EX	EX	EX	6	EX RTU	100	2	30	EX	EX	EX	EX		
O	0.1		7	EX SURGE SUPPRESSOR	100	3	20	EX	EX	EX	EX	8	*****	100	2	20	1	2	12	12	3/4"	
			9	*****	100	3	20	EX	EX	EX	EX	8	*****	100	2	20	1	2	12	12	3/4"	
			11	*****	100	3	20	EX	EX	EX	EX	8	*****	100	2	20	1	2	12	12	3/4"	
R	2.5		13	EX 30A RECEPT	100	1	30	EX	EX	EX	EX	14	EX 1ST FLR WIREMOLD	100	1	20	EX	EX	EX	EX	R	0.6
R	0.6		15	EX RECEPT	100	1	20	EX	EX	EX	EX	16	EX RECEPTS	100	1	20	EX	EX	EX	EX	R	0.6
R	0.6		17	EX RECEPT	100	1	20	EX	EX	EX	EX	18	EX RECEPTS	100	1	20	EX	EX	EX	EX	R	0.6
R	0.6		19	EX RECEPT	100	1	20	EX	EX	EX	EX	20	EX CONDENSATE PUMP	100	1	20	EX	EX	EX	EX	O	0.2
R	0.6		21	EX RECEPT	100	1	20	EX	EX	EX	EX	22	EX RECEPTS	100	1	20	EX	EX	EX	EX	R	0.8
R	0.6		23	EX RECEPT	100	1	20	EX	EX	EX	EX	24	EX RECEPTS	100	1	20	EX	EX	EX	EX	R	0.6
R	0.6		25	EX DRIVE THRU WINDOW	100	1	20	EX	EX	EX	EX	26	EX RECEPTS	100	1	20	EX	EX	EX	EX	R	0.6
R	0.6		27	EX DRIVE THRU WINDOW	100	1	20	EX	EX	EX	EX	28	EX RECEPTS	100	1	20	EX	EX	EX	EX	R	0.6
R	0.6		29	EX 1ST FLR WIREMOLD	100	1	20	EX	EX	EX	EX	30	EX RECEPTS	100	1	20	EX	EX	EX	EX	R	0.6
R	0.6		31	EX RECEPTS	100	1	20	EX	EX	EX	EX	32	EX RECEPTS	100	1	20	EX	EX	EX	EX	R	0.6
R	0.6		33	EX RECEPTS	100	1	20	EX	EX	EX	EX	34	EX RECEPTS	100	1	20	EX	EX	EX	EX	R	0.6
R	0.6		35	EX RECEPTS	100	1	20	EX	EX	EX	EX	36	EX DRIVE THRU WINDOW	100	1	20	EX	EX	EX	EX	R	0.6
R	0.6		37	EX RECEPTS	100	1	20	EX	EX	EX	EX	38	EX RECEPTS	100	1	20	EX	EX	EX	EX	R	0.6
R	0.6		39	EX RECEPTS	100	1	20	EX	EX	EX	EX	40	EX COPIER	100	1	20	EX	EX	EX	EX	R	0.5
R	0.6		41	EX RECEPTS	100	1	20	EX	EX	EX	EX	42	EX SMOKE DAMPERS	100	1	20	EX	EX	EX	EX	O	0.1
R	0.6		43	EX RECEPTS	100	1	20	EX	EX	EX	EX	44	EX RECEPTS	100	1	20	EX	EX	EX	EX	R	0.8
R	0.6		45	EX RECEPTS	100	1	20	EX	EX	EX	EX	46	EX FIRE ALARM PANEL	100	1	20	EX	EX	EX	EX	O	0.1
			47	AHU-2(BACKUP UNIT)	100	2	15	1	2	12	12	3/4"	48	MAIN	100	3	100	EX	EX	EX	EX	
			49	*****	100	2	15	1	2	12	12	3/4"	50	*****	100	3	100	EX	EX	EX	EX	
			51	SPARE	100	1	20	*****	*****	*****	*****	52	*****	100	1	20	*****	*****	*****	*****		
			53	SPARE	100	1	20	*****	*****	*****	*****	54	SHUNT TRIP	100	1	20	*****	*****	*****	*****		

NOTES:

• BOLD INDICATES NEW WORK

